



Common Abbreviations: AFFL - DENOTES ABOVE FINISHED FLOOR LEVEL WP - DENOTES WEATHER PROOF, MINIMUM

RATING IP54 Notes

ALL MEASUREMENTS ARE IN MILLIMETERS UNLESS SPECIFIED OTHERWISE.

- 2. ELECTRICAL INSTALLATION TO COMPLY WITH SANS 10142-1 & SANS 10142-2.
- 3. ALL CONDUIT/CABLING WORK TO BE RECESSED
- MOUNTED. 4. PHOTOCELL TO SWITCH EXTERNAL LIGHTS BY MEANS
- OF 2 POLE CONTACTOR IN DB. 5. REFER TO LUMINAIRE SCHEDULE FOR LIGHT FITTING
- 6. ALL CIRCUITING TO BE WIRED AS FOLLOWS:
- 25mmØ PVC RECESSED CONDUITS IN VERTICAL
- 25mmØ GALVANIZED STEEL SURFACE MOUNTED CONDUITS BELOW SOFFITS (TYPICALLY LINKING)
- ELEMENTS TO CLOSEST TRAYS/CONDUIT) ALL EXPOSED CONDUITS TO FOLLOW A GRID FORMATION, RUNNING
- AT 90° ANGLES RELEVANT TO
- CONDUITS/WALLS. ALL EXPOSED CONDUITS TO BE GALVANIZED
- RECESSED 50mm DIAMETER PVC SLEEVE INSTALLED IN BRICK WALL CAVITY FROM BOTTOM OF DB (TERMINATED CW GLANDING) TO CABLE TRENCH OR ELECTRICAL MANHOLE, CW SLOW BEND
- 8. ALL POWER POINTS TO BE RECESSED AT 500mm AFFL CENTER OF BOX, UNLESS SPECIFIED OTHERWISE.

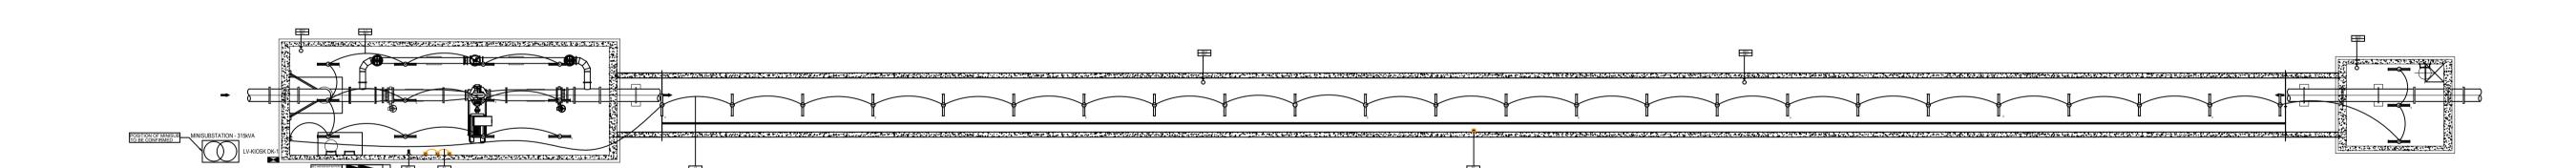

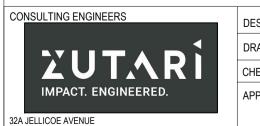

OXFORD CORNER

17 HARRISON STREET MARSHALLTOWN

SOUTH AFRICA

CLIENT

	DESIGNED	J.MUTALE	29.09.21		
ARÍ	DRAWN	J.MUTALE	29.09.21		17 HARRISON STREET
	CHECKED	L.ESTERHUIZEN	29.09.21		
NEERED.	APPROVED BY:	L.ESTERHUIZEN	28.05.21		MARSHALLTOWN
TEL: +27 11 214 4500		SIGNATURE	DATE		2107
TEE. 127 11 214 4500	ECSA REG. No.				TEL (044) 000 4400
	CHECKED BY:			Johannesburg Water	TEL: (011) 688-1400
		SIGNATURE	DATE	- Juliannesburg Water	FAX: (011) 688-1529
	ECSA REG. No.				

Joburg.

HALFWAY HOUSE SUPPLY BULK WATER PIPELINE ELECTRICAL - SMALL POWER AND LIGHTING INSTALLATION

	APPROVAL BY JW DEPOT			SCALE	AMENDMENTS		DRAWING No.								
	CHECKED			1:200	REV:	DESCRIPTION	DATE:								٦
	APPROVED BY:				ТО	FOR TENDER	28.09.21	144040	000	0 000		200		TO	1
		SIGNATURE	DATE					111242	- 000			200		T0	
								PROJECT No. DRAWING		NG No.			REV.		
APPROVAL BY JW PLANNING							A1 SHEET 01				OF	05			
	CHECKED										()1	OF	01	
	APPROVED BY:							ORIGINAL PAGE SIZE FILE No.					٦		
		SIGNATURE	DATE					EI 1307B							