




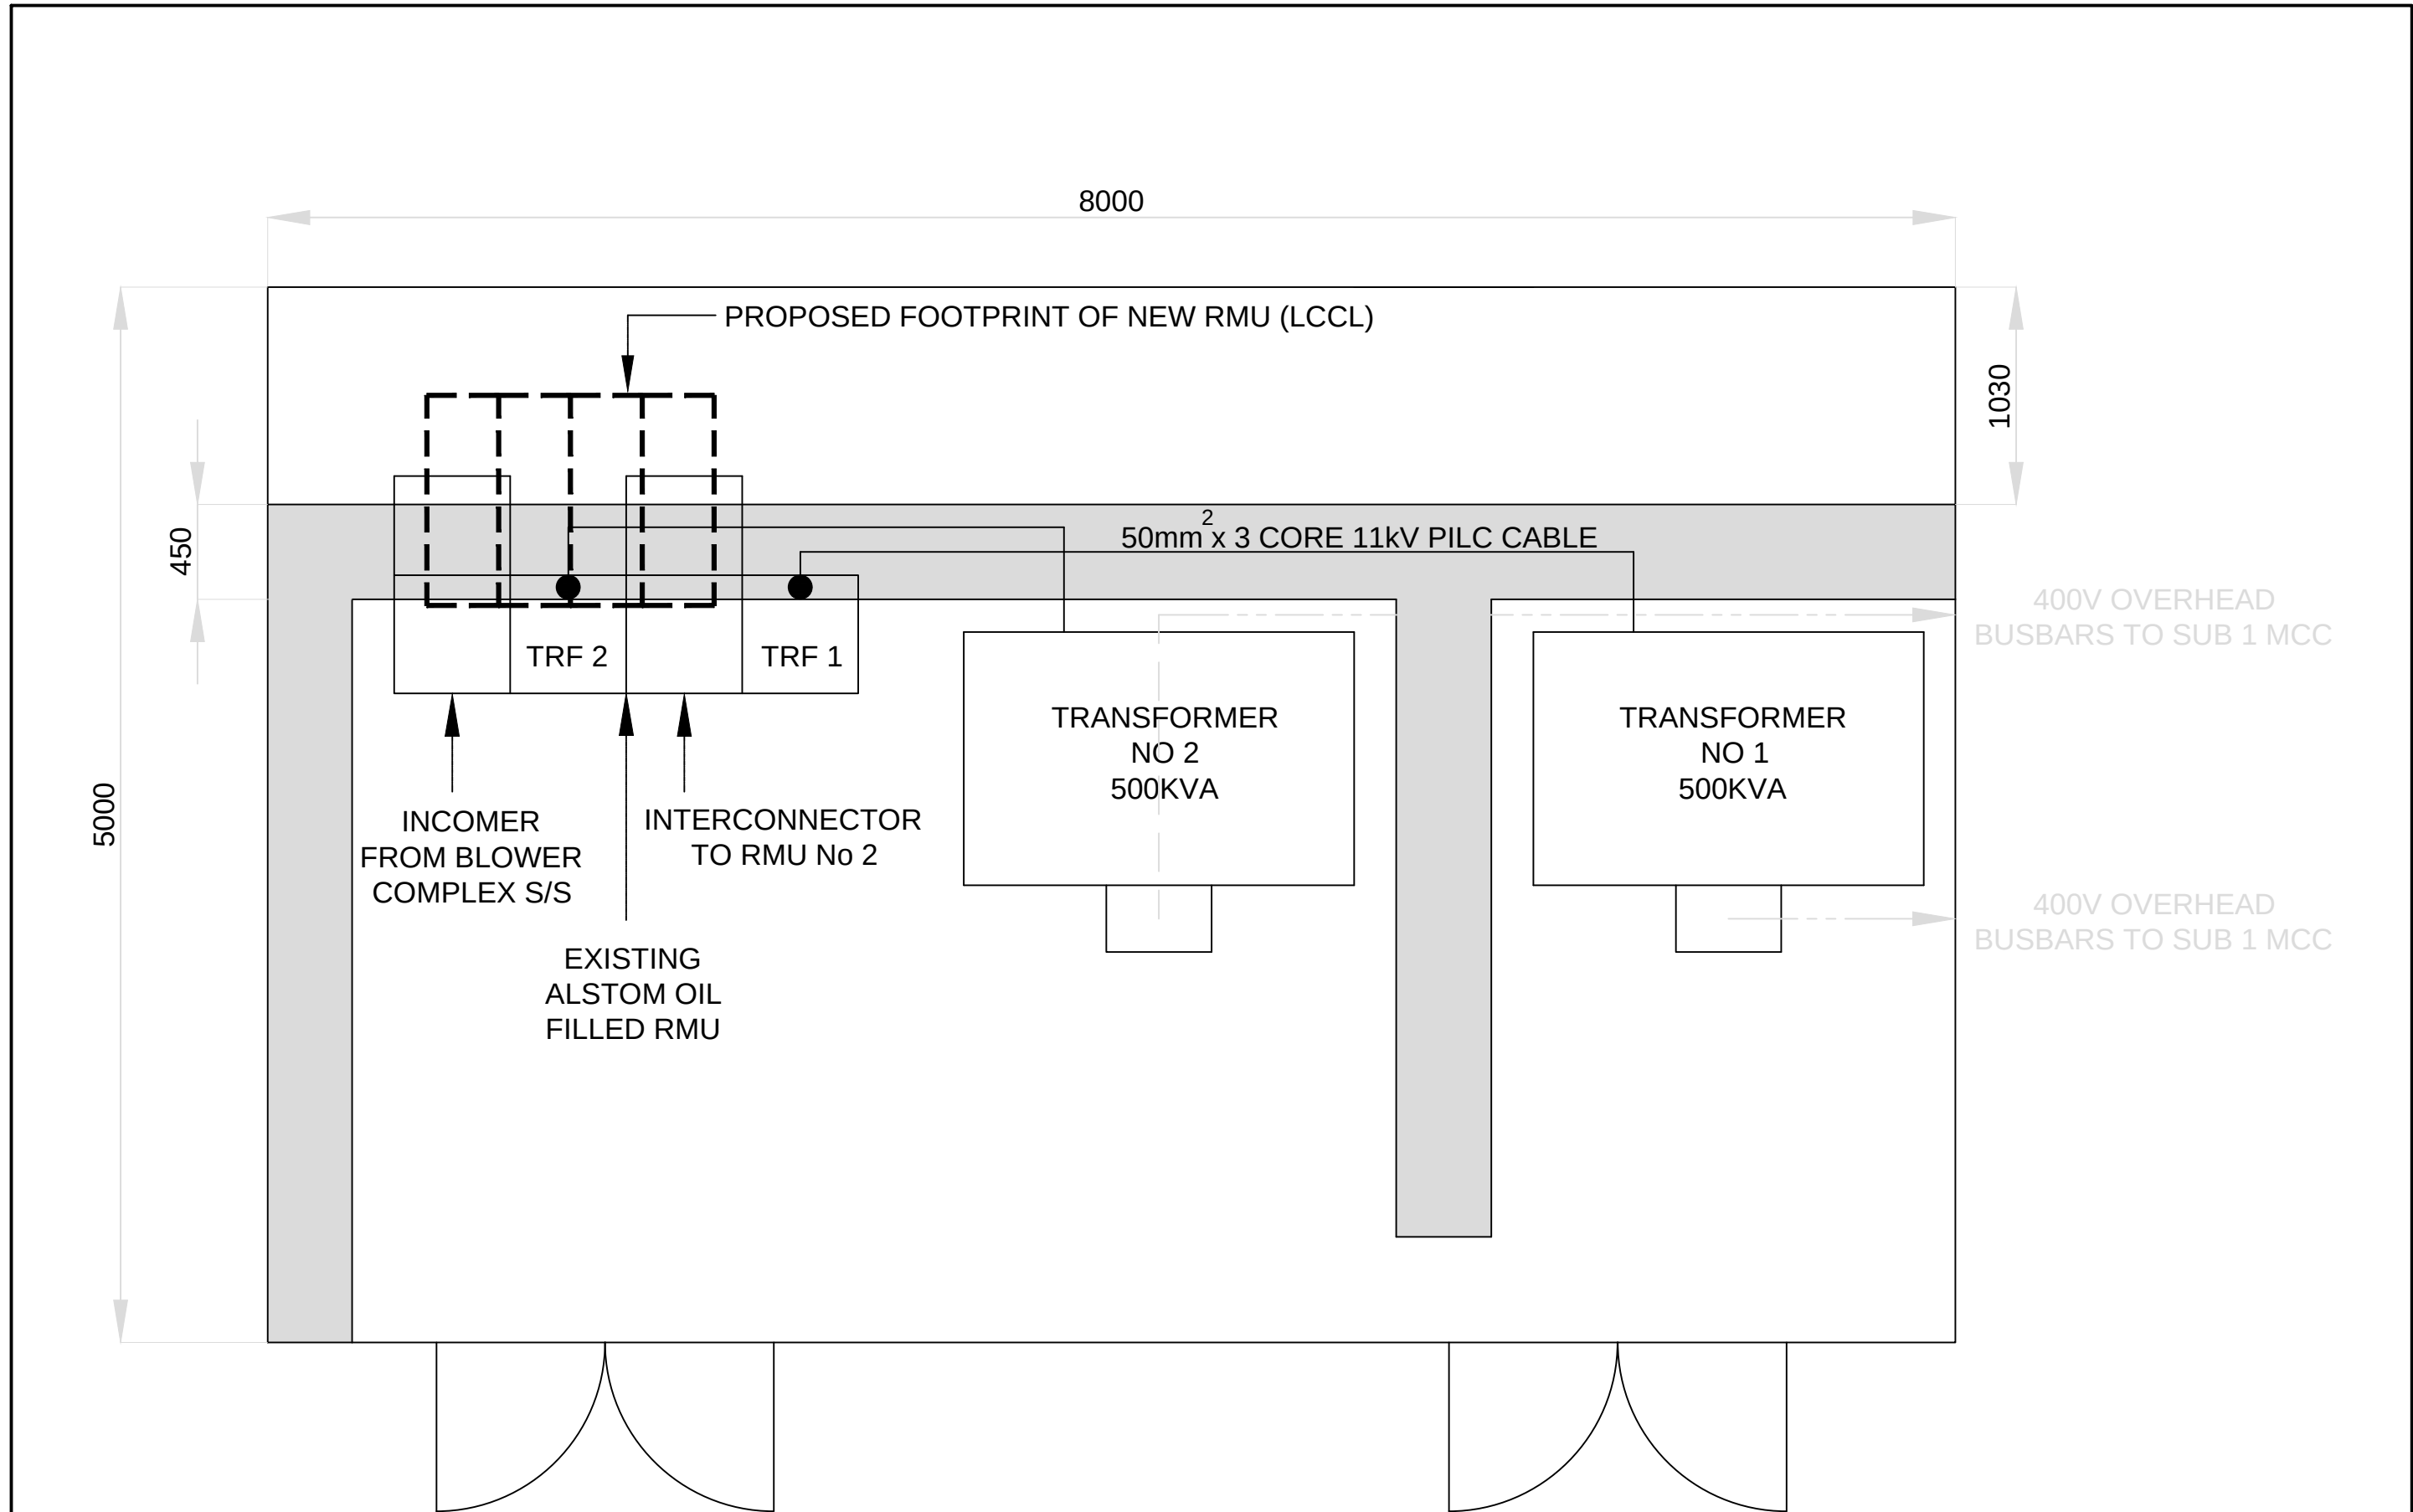

DEPARTMENT	APPROVED	DESIGNATION	DATE


CONSULTING ENGINEERS		SURVEYED DESIGNED DRAWN CHECKED SERVICES CHECKED GEOTECHNICAL INVESTIGATION SERVICES APPROVED DATE DMcD DMcD		JOHANNESBURG WATER (PTY) LTD		CITY OF JOHANNESBURG										DESIGN MANAGER	SCALE	AMENDMENTS		APPROVED	DATE	DRAWING No.			
ZITHOLELE CONSULTING		ZITHOLELE P.O. BOX 6002 HALFWAY HOUSE 1685 TEL. 011-254 4800 FAX. 011-805 2100 EMAIL mail@zitholele.co.za		 Johannesburg Water		17 HARRISON STREET MARSHALLTOWN 2107		BUSHKOPPIE WASTEWATER TREATMENT WORKS										DATE: AUG 21	1:30	T00 ISSUED FOR TENDER		DMcD	AUG 21	JW NUMBER	
								INFRASTRUCTURE RENEWAL PLAN SUBSTATION No 1 LAYOUT																CONSULTANT'S NUMBER 18056-73-12-102	
																								FILE No 18056	
																								T O O	

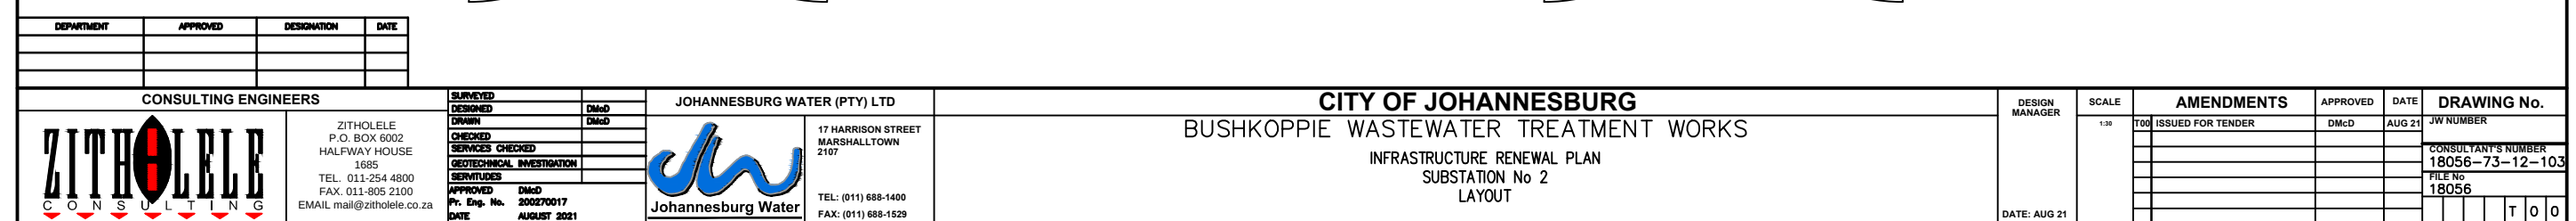

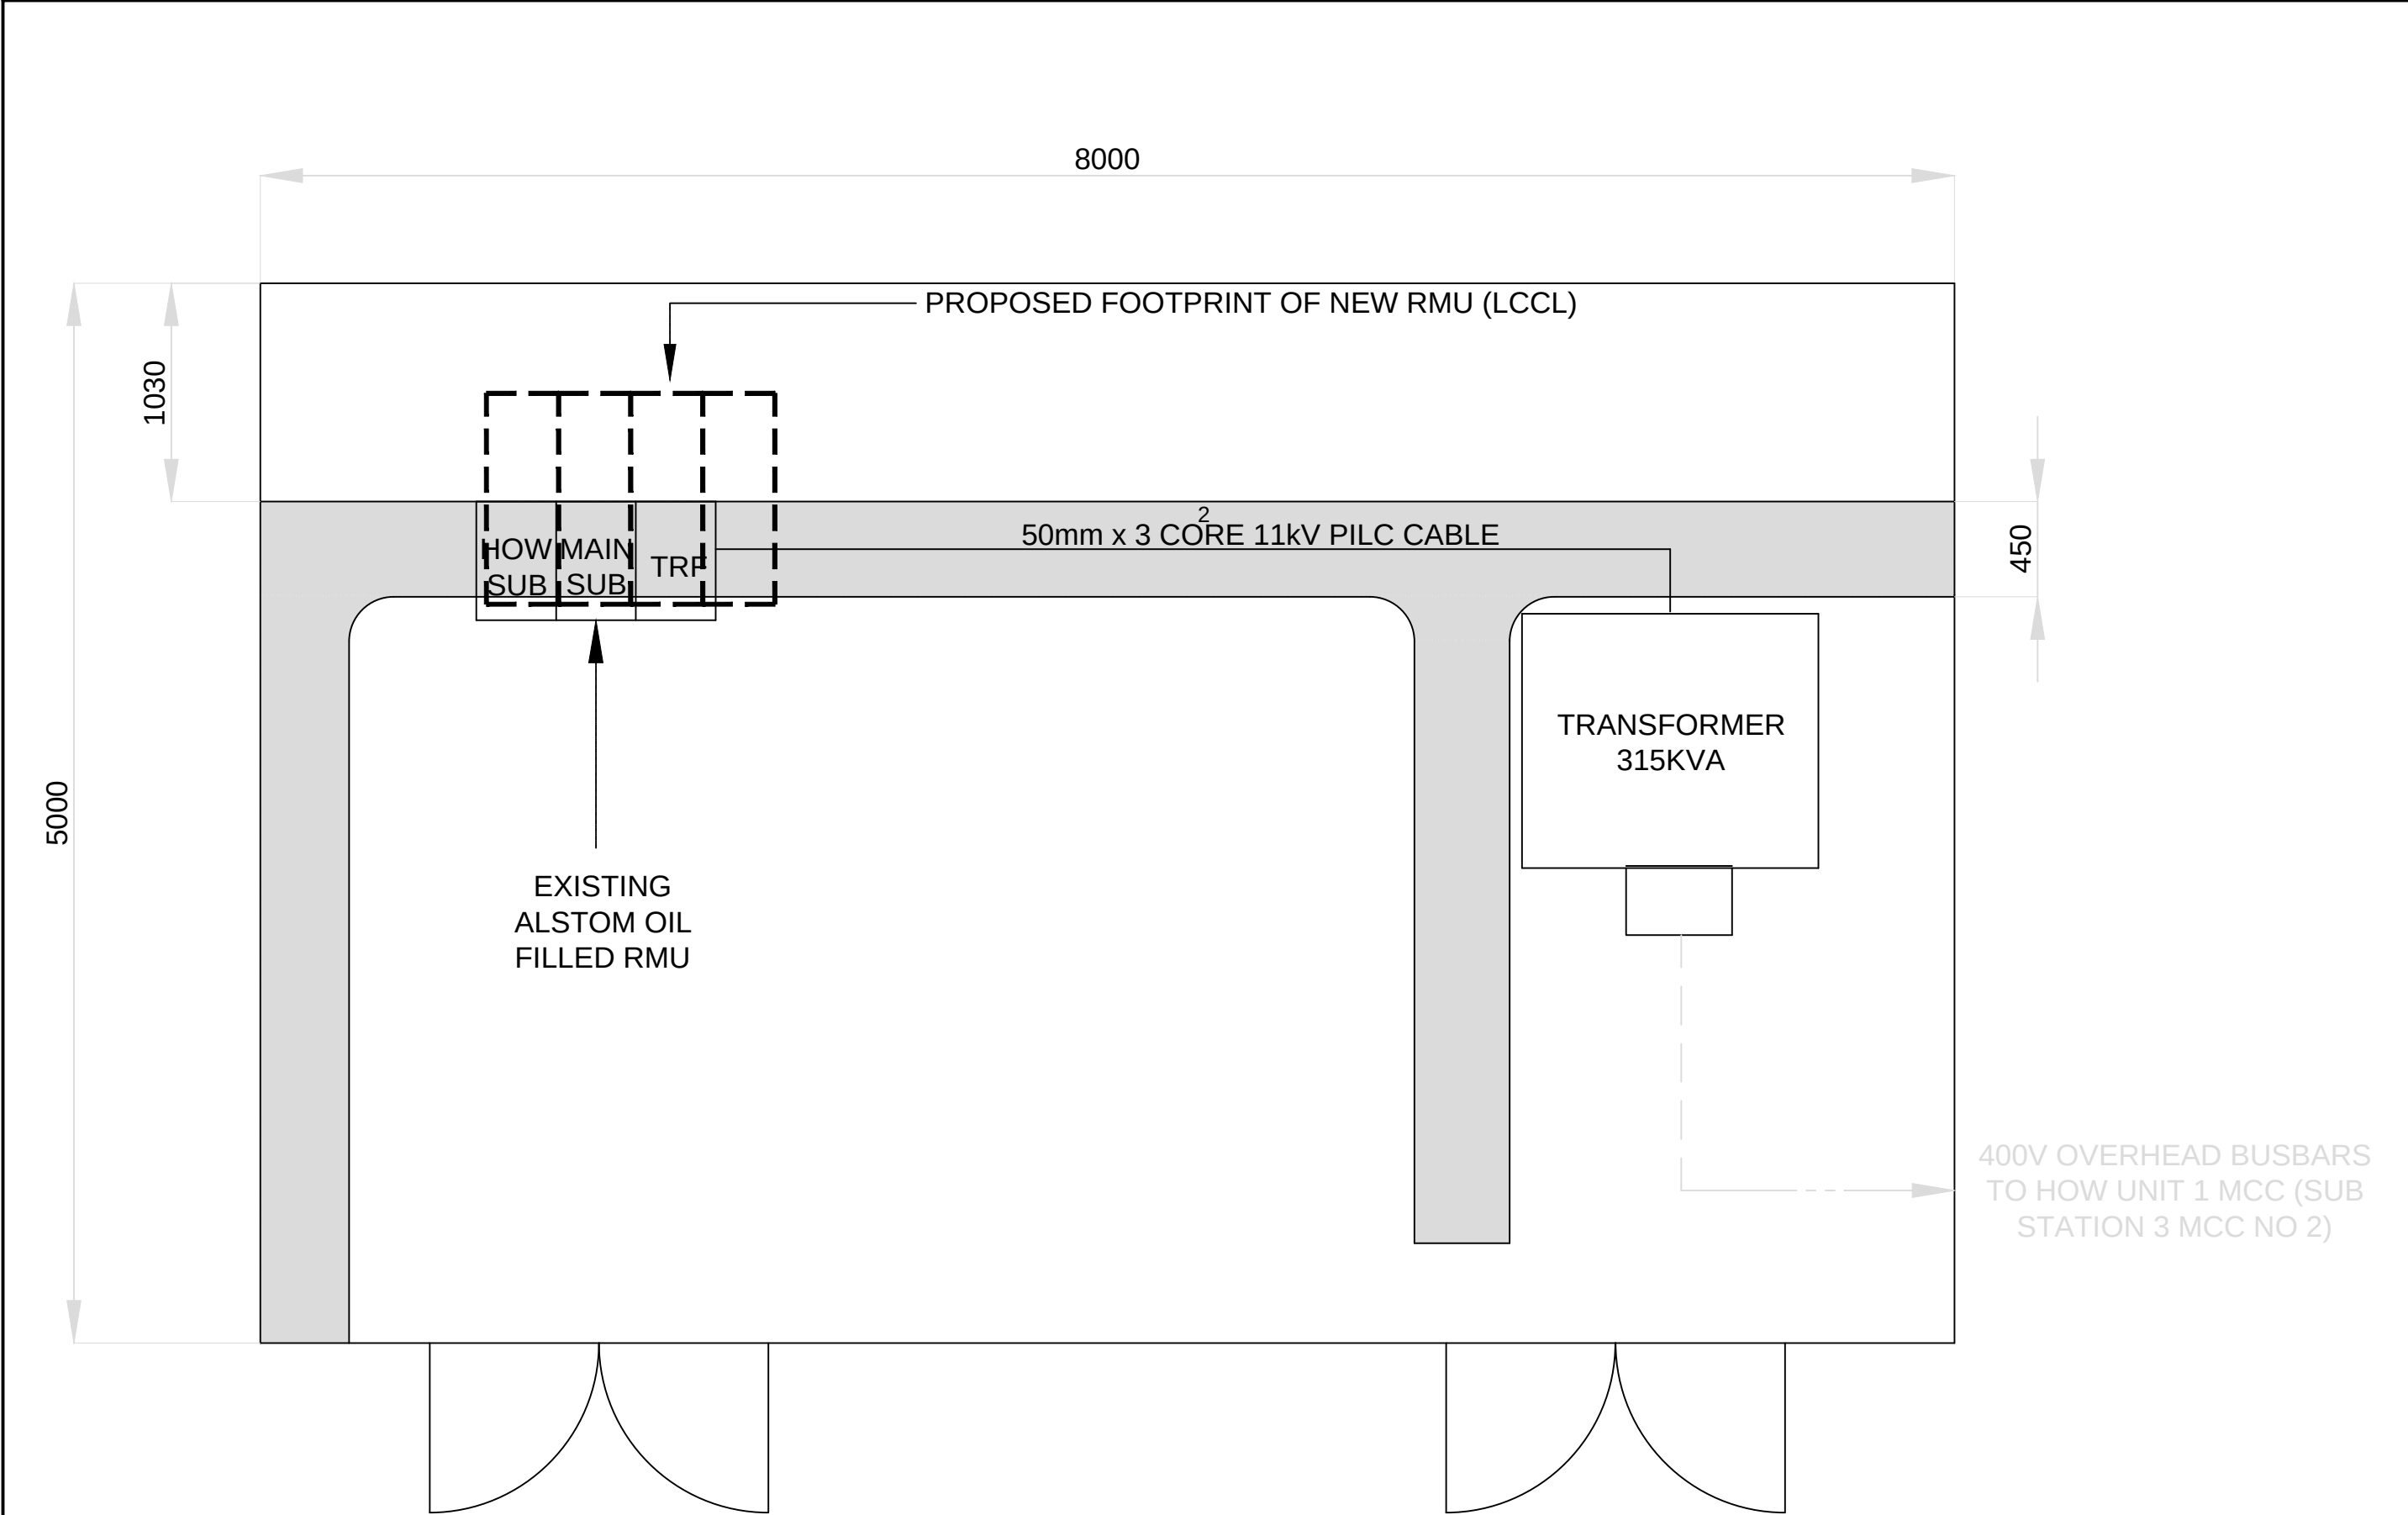


DEPARTMENT	APPROVED	DESIGNATION	DATE

CONSULTING ENGINEERS		SURVEYED DESIGNED DRAWN CHECKED SERVICES CHECKED GEOTECHNICAL INVESTIGATION SERVICES APPROVED DATE		JOHANNESBURG WATER (PTY) LTD Johannesburg Water 17 HARRISON STREET MARSHALLTOWN 2107 TEL: (011) 688-1400 FAX: (011) 688-1529		CITY OF JOHANNESBURG				DESIGN MANAGER	SCALE	AMENDMENTS		APPROVED	DATE	DRAWING No.	
ZITHOLELE CONSULTING ZITHOLELE P.O. BOX 6002 HALFWAY HOUSE 1685 TEL. 011-254 4800 FAX: 011-805 2100 EMAIL mail@zitholele.co.za				BUSHKOPPIE WASTEWATER TREATMENT WORKS				1:30	T00	ISSUED FOR TENDER		DMcD	AUG 21	JW NUMBER			
				INFRASTRUCTURE RENEWAL PLAN SUBSTATION No 3 LAYOUT										CONSULTANT'S NUMBER			
														18056-73-12-105			
														FILE No			
														18056			
														T O O			

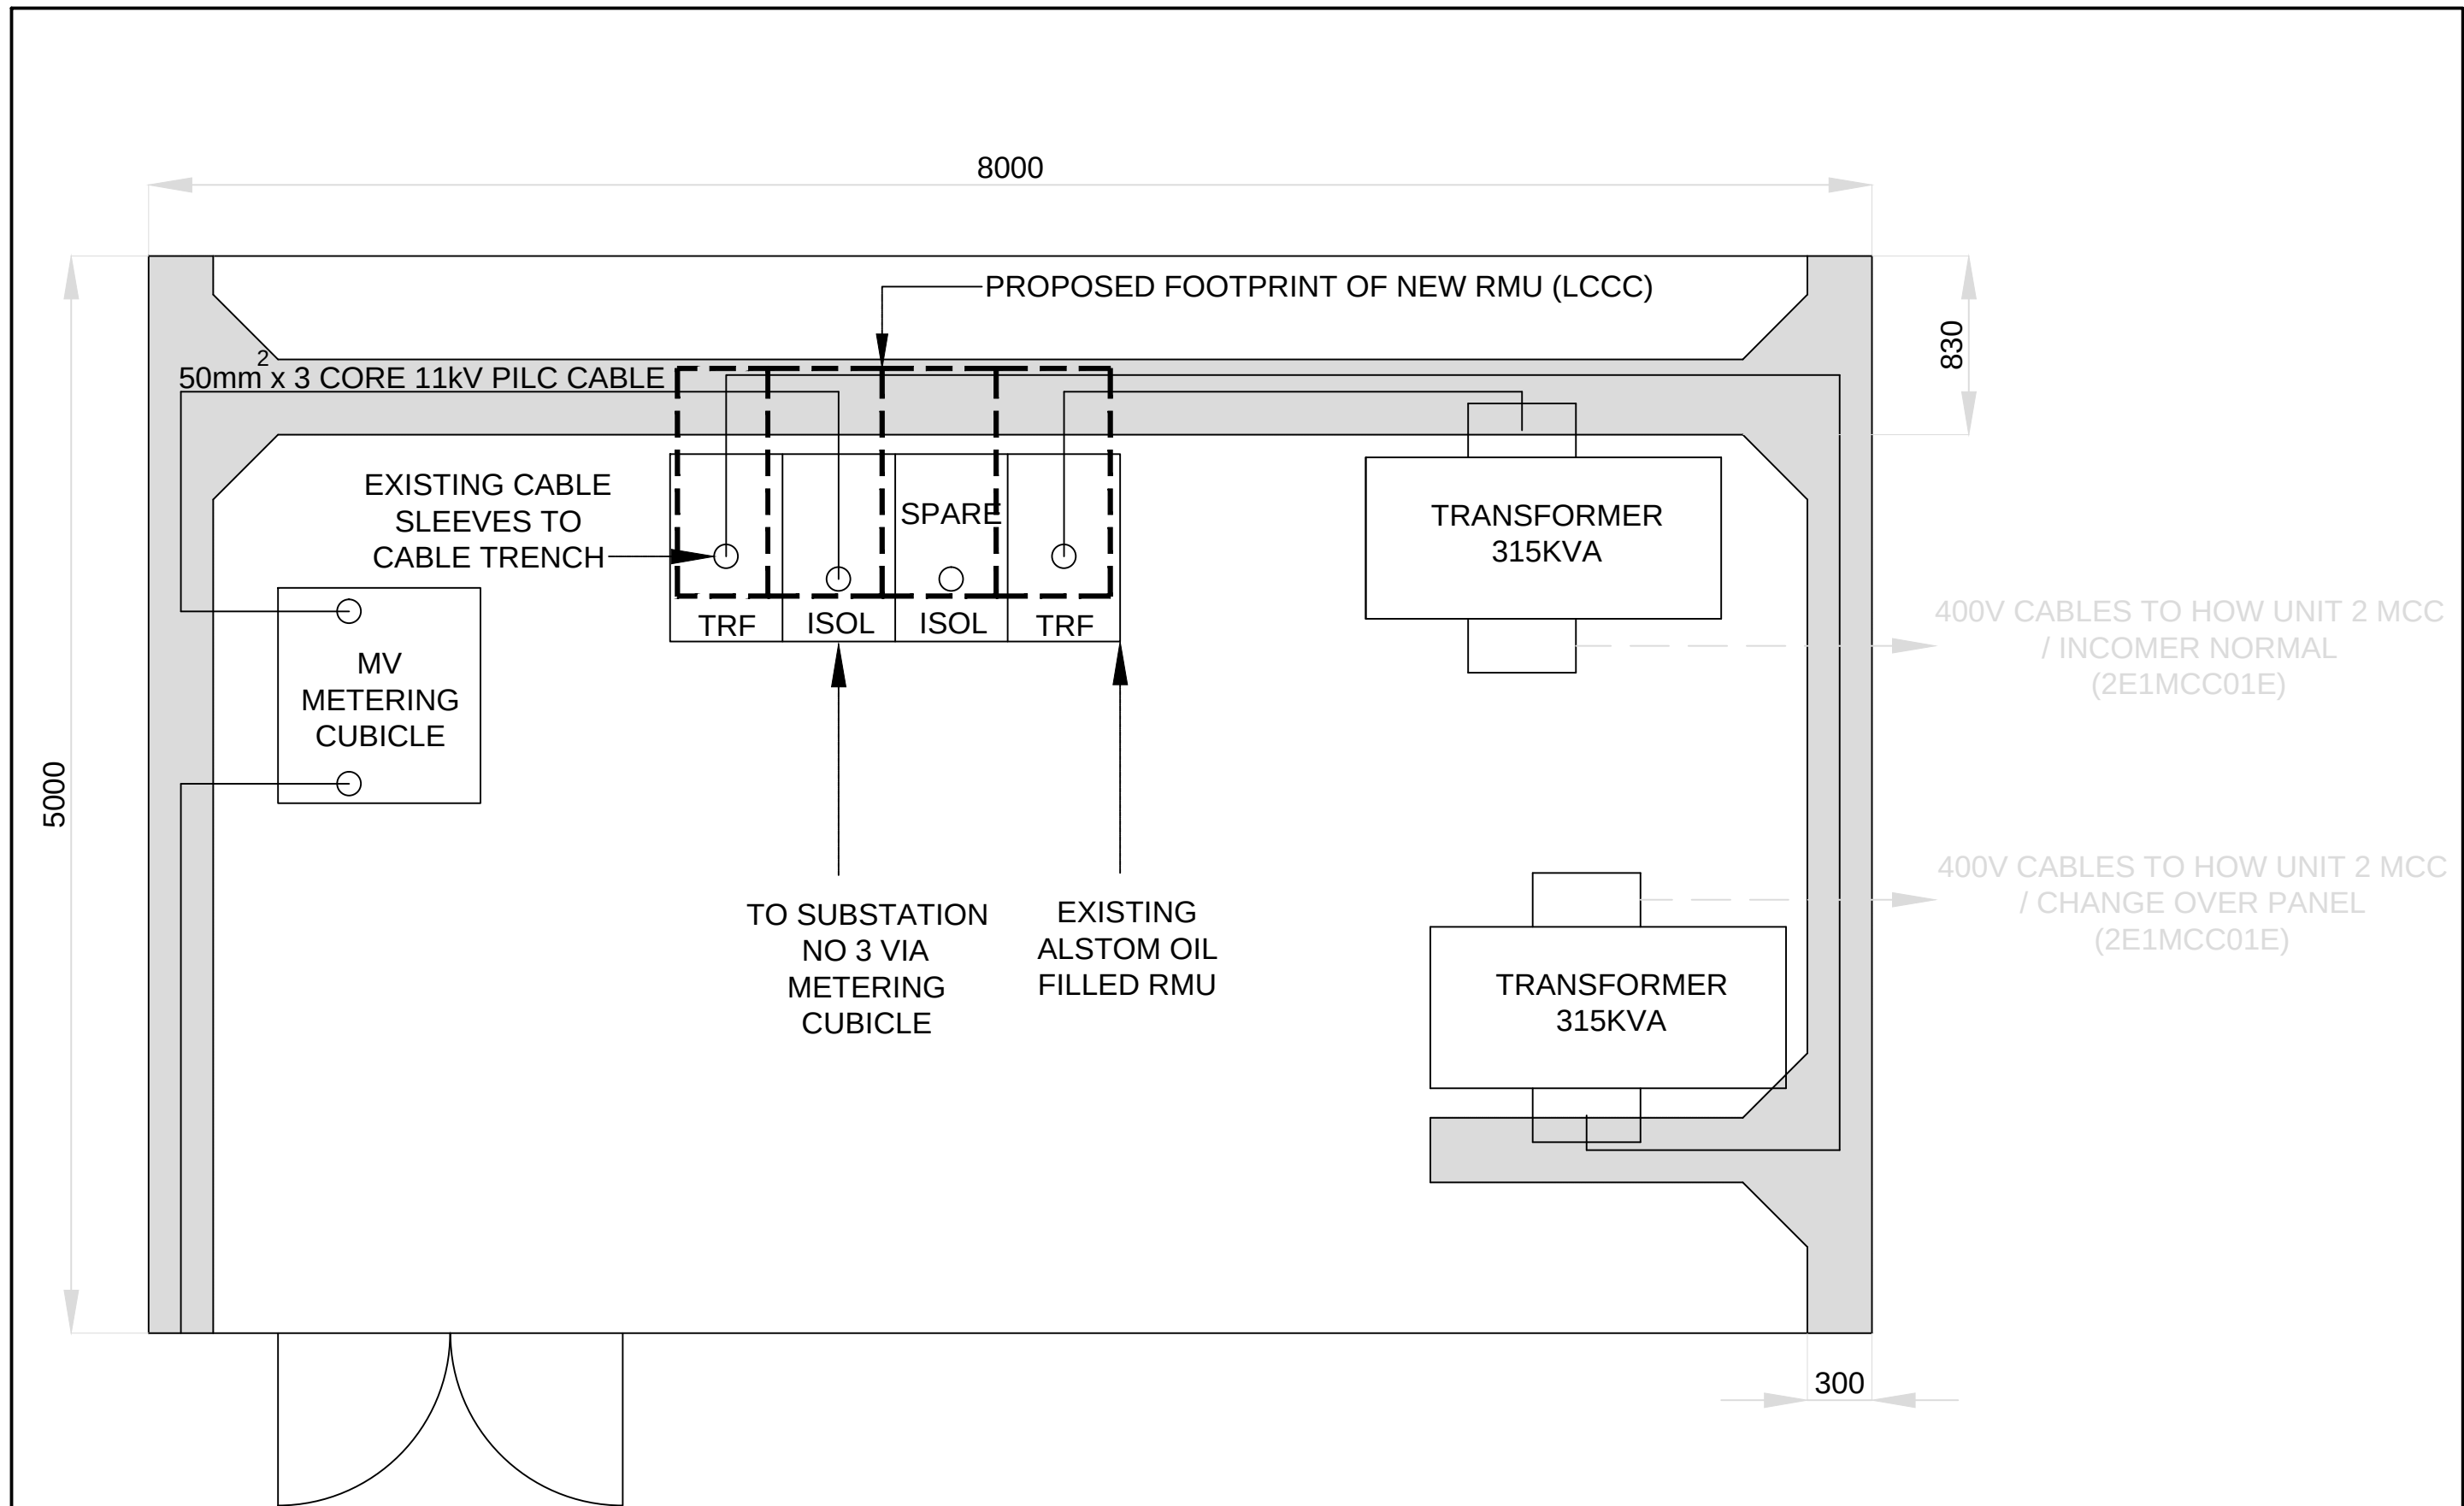

DEPARTMENT	APPROVED	DESIGNATION	DATE

CONSULTING ENGINEERS		JOHANNESBURG WATER (PTY) LTD		CITY OF JOHANNESBURG				DESIGN MANAGER	SCALE 1:30	AMENDMENTS		APPROVED DMcD	DATE AUG 21	DRAWING No.			
ZITHOLELE P.O. BOX 6002 HALFWAY HOUSE 1685 TEL. 011-254 4800 FAX. 011-805 2100 EMAIL mail@zitholele.co.za		SURVEYED DESIGNED DRAWN CHECKED SERVICES CHECKED GEOTECHNICAL INVESTIGATION SERVICES APPROVED DATE DMcD DMcD DMcD DMcD DMcD DMcD DMcD DMcD 200270017 AUGUST 2021		Johannesburg Water 17 HARRISON STREET MARSHALLTOWN 2107 TEL: (011) 688-1400 FAX: (011) 688-1529		BUSHKOPPIE WASTEWATER TREATMENT WORKS				T00				ISSUED FOR TENDER		CONSULTANT'S NUMBER 18056-73-12-106	
				INFRASTRUCTURE RENEWAL PLAN HOW SUBSTATION LAYOUT								FILE No 18056					
												JW NUMBER					
												T 0 0					

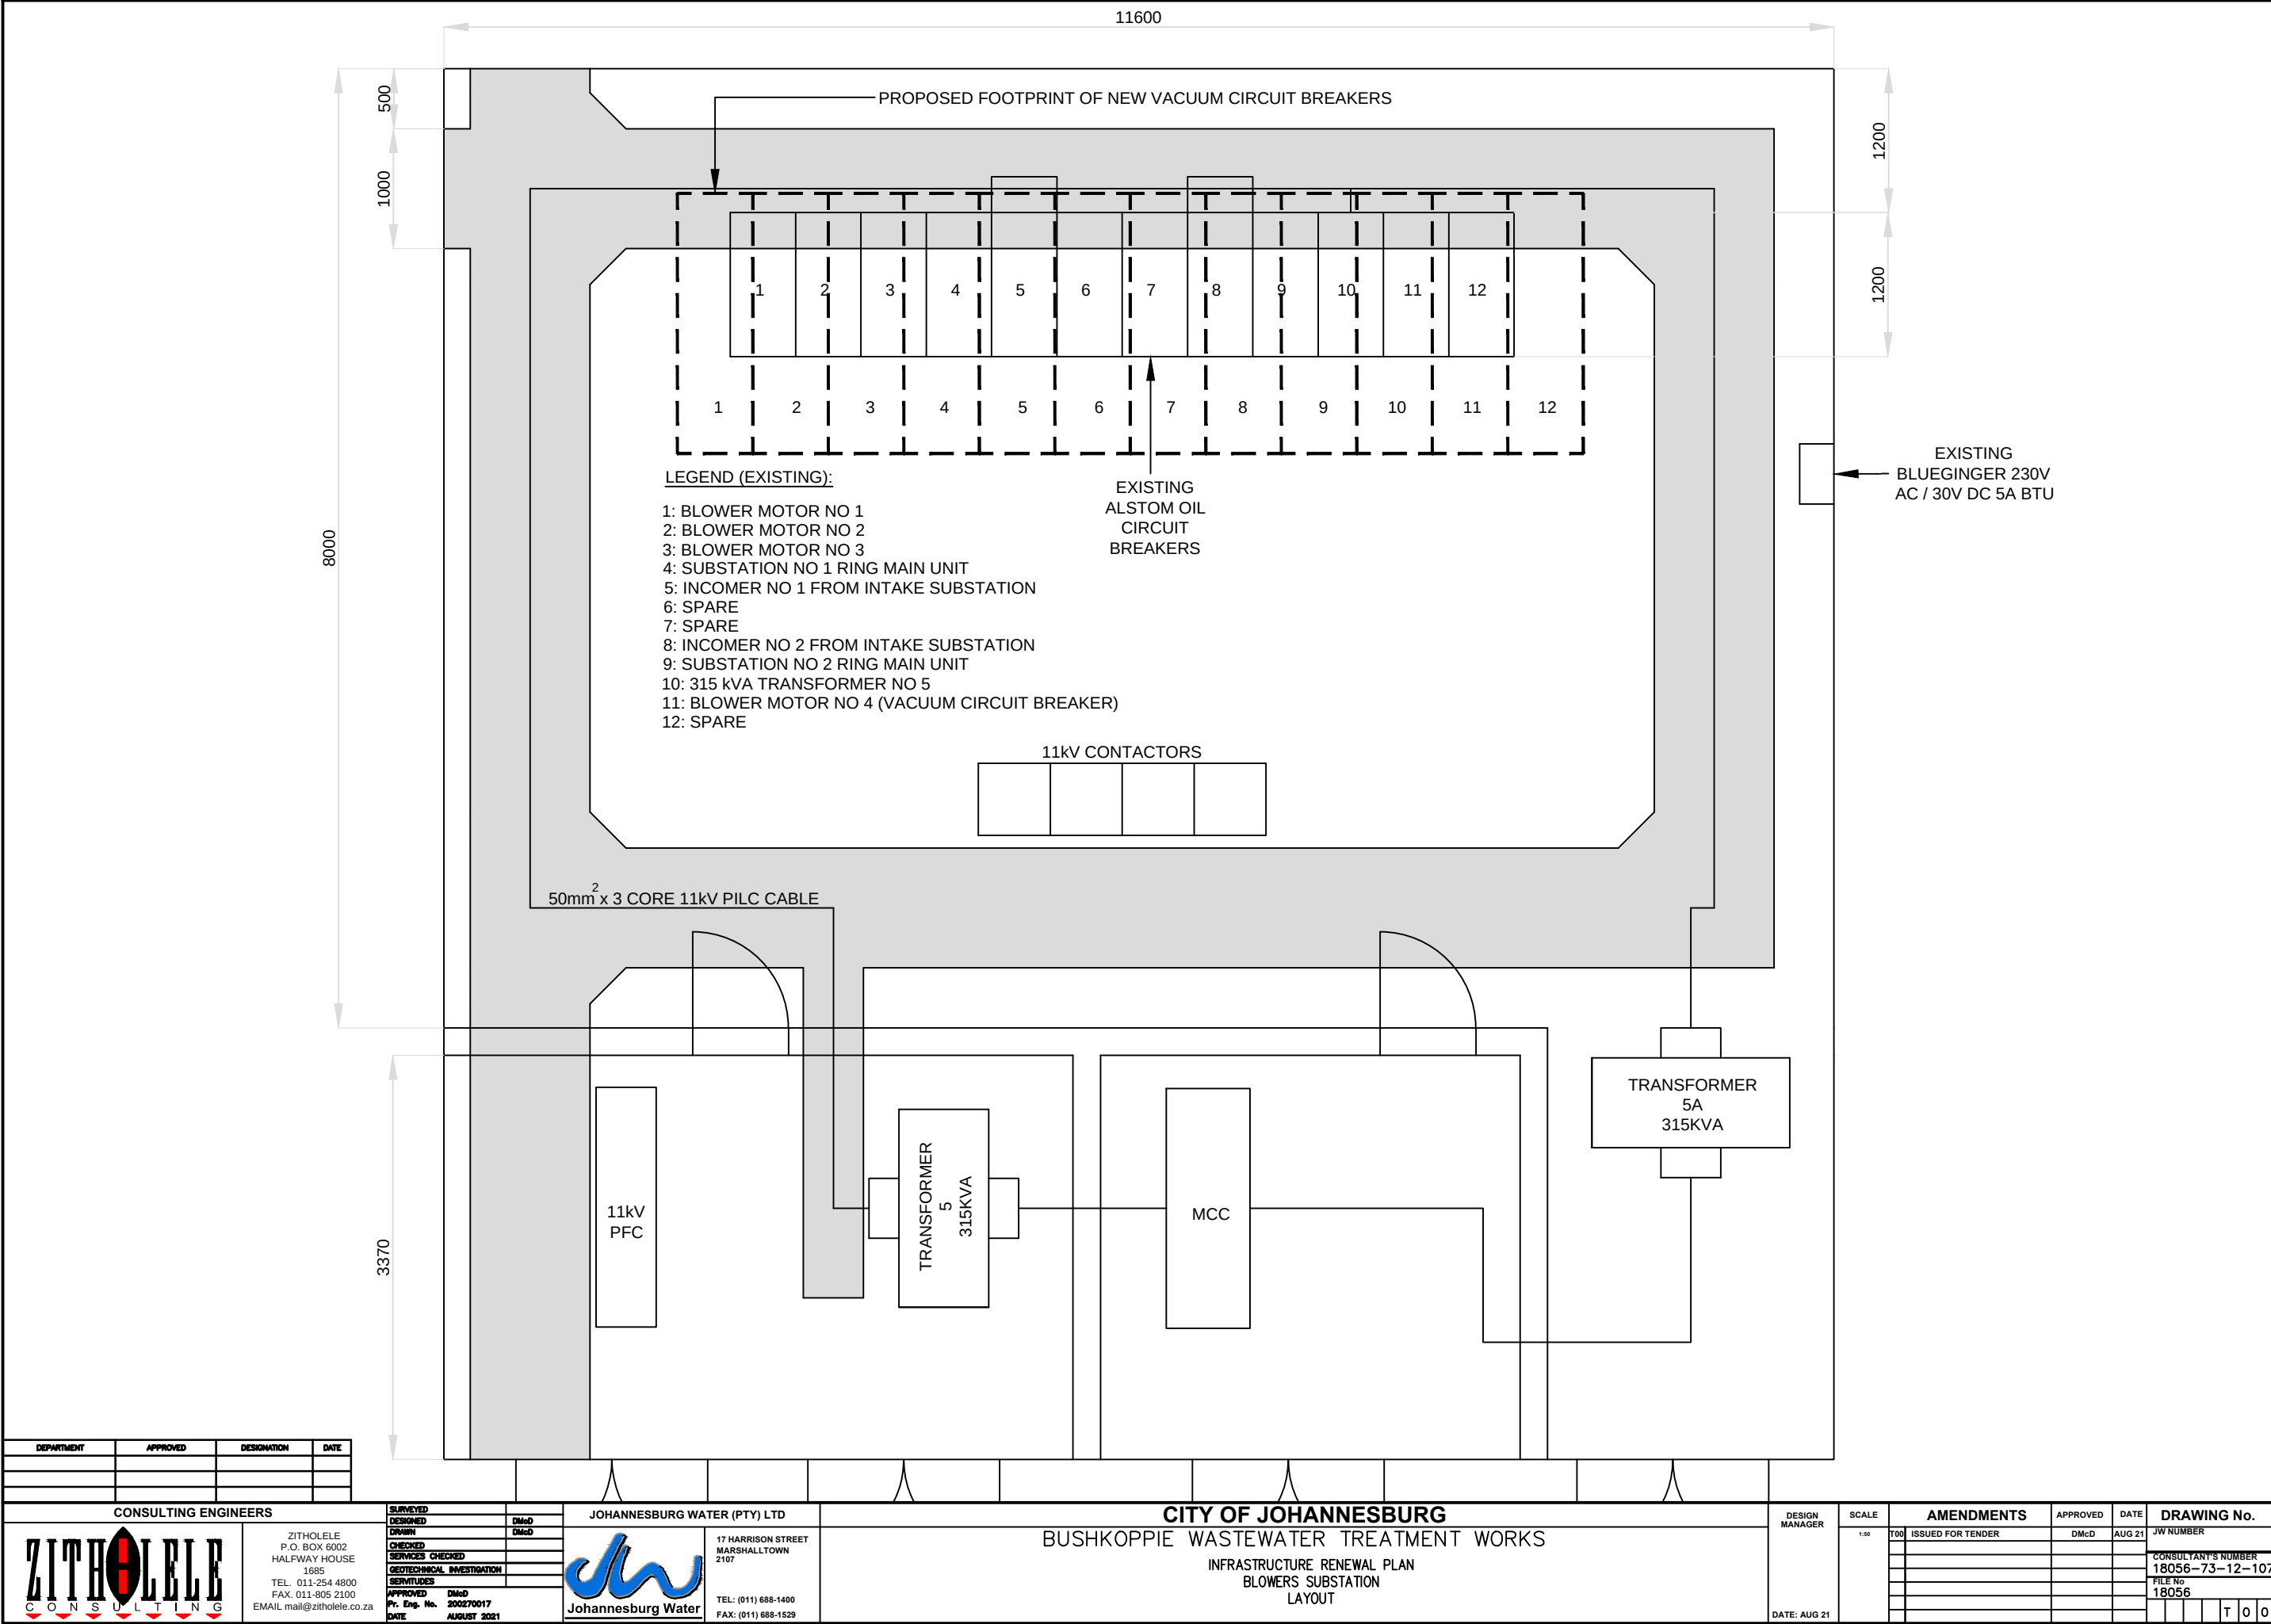

DEPARTMENT	APPROVED	DESIGNATION	DATE

CONSULTING ENGINEERS

ZITHOLELE
P.O. BOX 6002
HALFWAY HOUSE
1685
TEL. 011-254 4800
FAX. 011-805 2100
EMAIL mail@zitholele.co.za

SURVEYED	DMd
DESIGNED	DMd
DRAWN	
CHECKED	
SERVICES CHECKED	
GEOTECHNICAL INVESTIGATION	
SERVICES	
APPROVED	DMd
Pr. Eng. No.	200270017
DATE	AUGUST 2021

JOHANNESBURG WATER (PTY) LTD
17 HARRISON STREET
MARSHALLTOWN
2107
TEL: (011) 688-1400
FAX: (011) 688-1529


CITY OF JOHANNESBURG
BUSHKOPPIE WASTEWATER TREATMENT WORKS
INFRASTRUCTURE RENEWAL PLAN
BLOWERS SUBSTATION
LAYOUT


DESIGN MANAGER


SCALE 1:50


DATE: AUG 21


AMENDMENTS	APPROVED	DATE	DRAWING No.
T001 ISSUED FOR TENDER	DMcD	AUG 21	JW NUMBER
			CONSULTANT'S NUMBER
			18056-73-12-107
			FILE No
			18056
			T 0 0

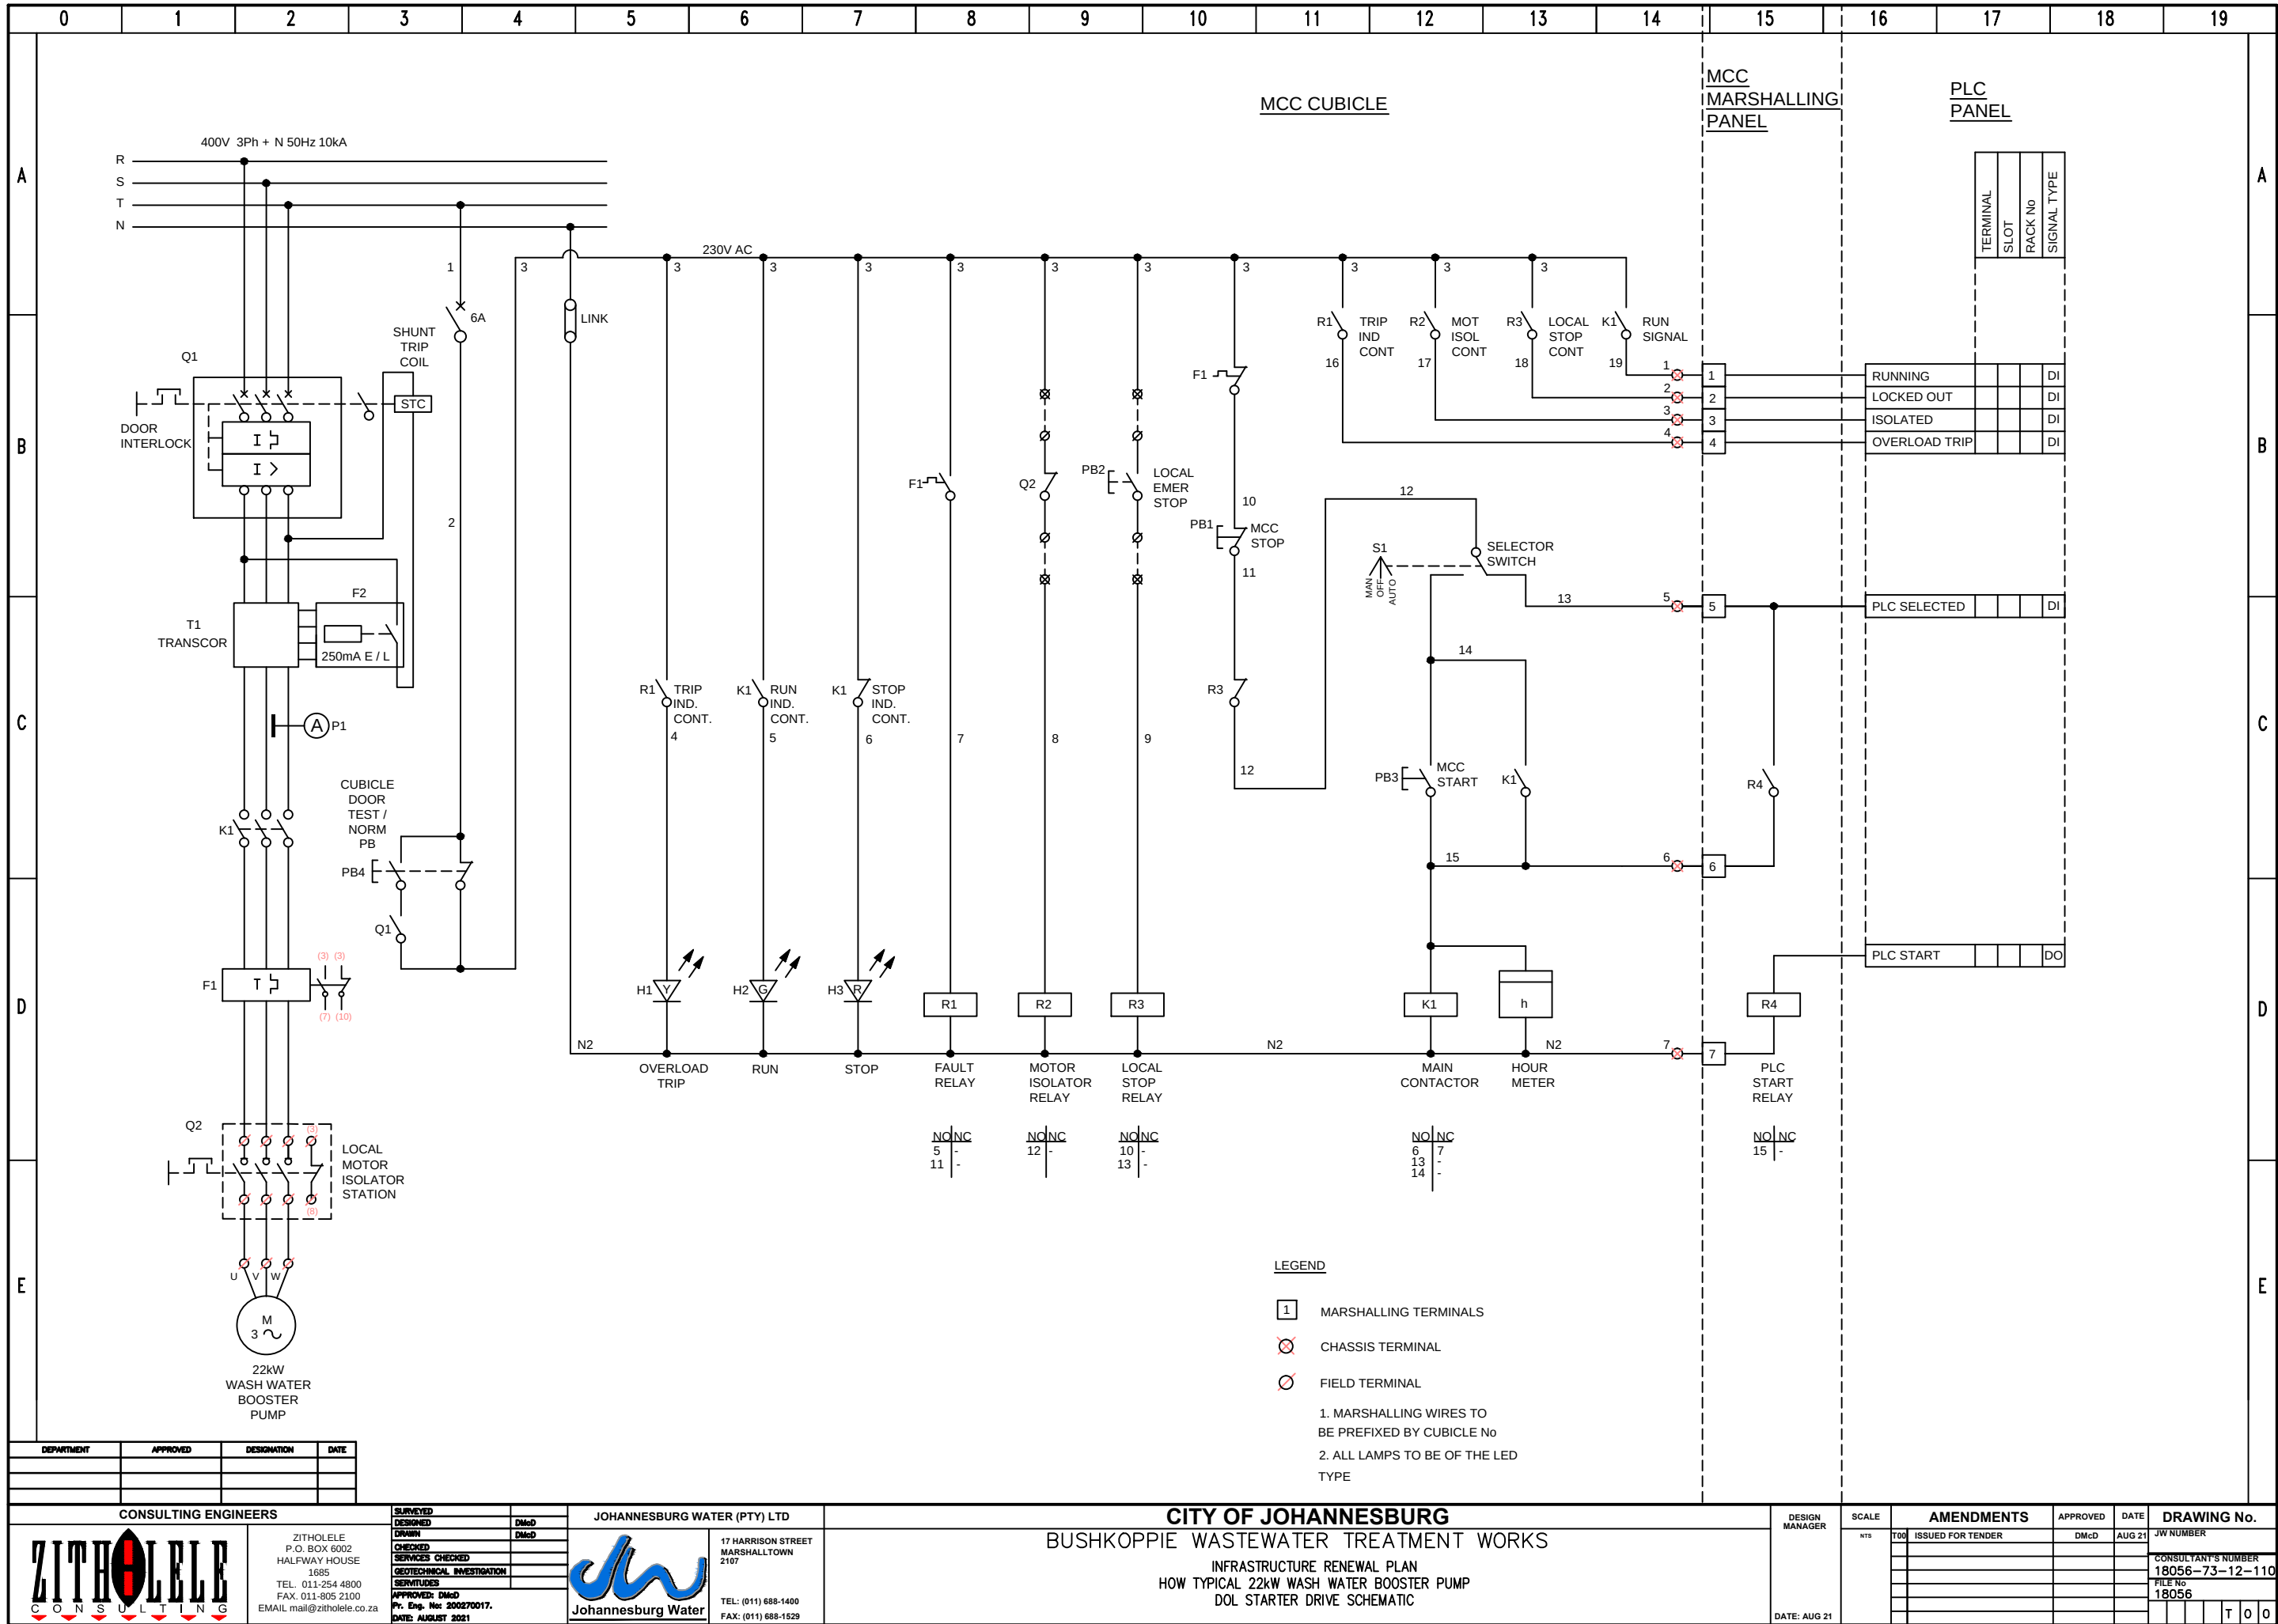


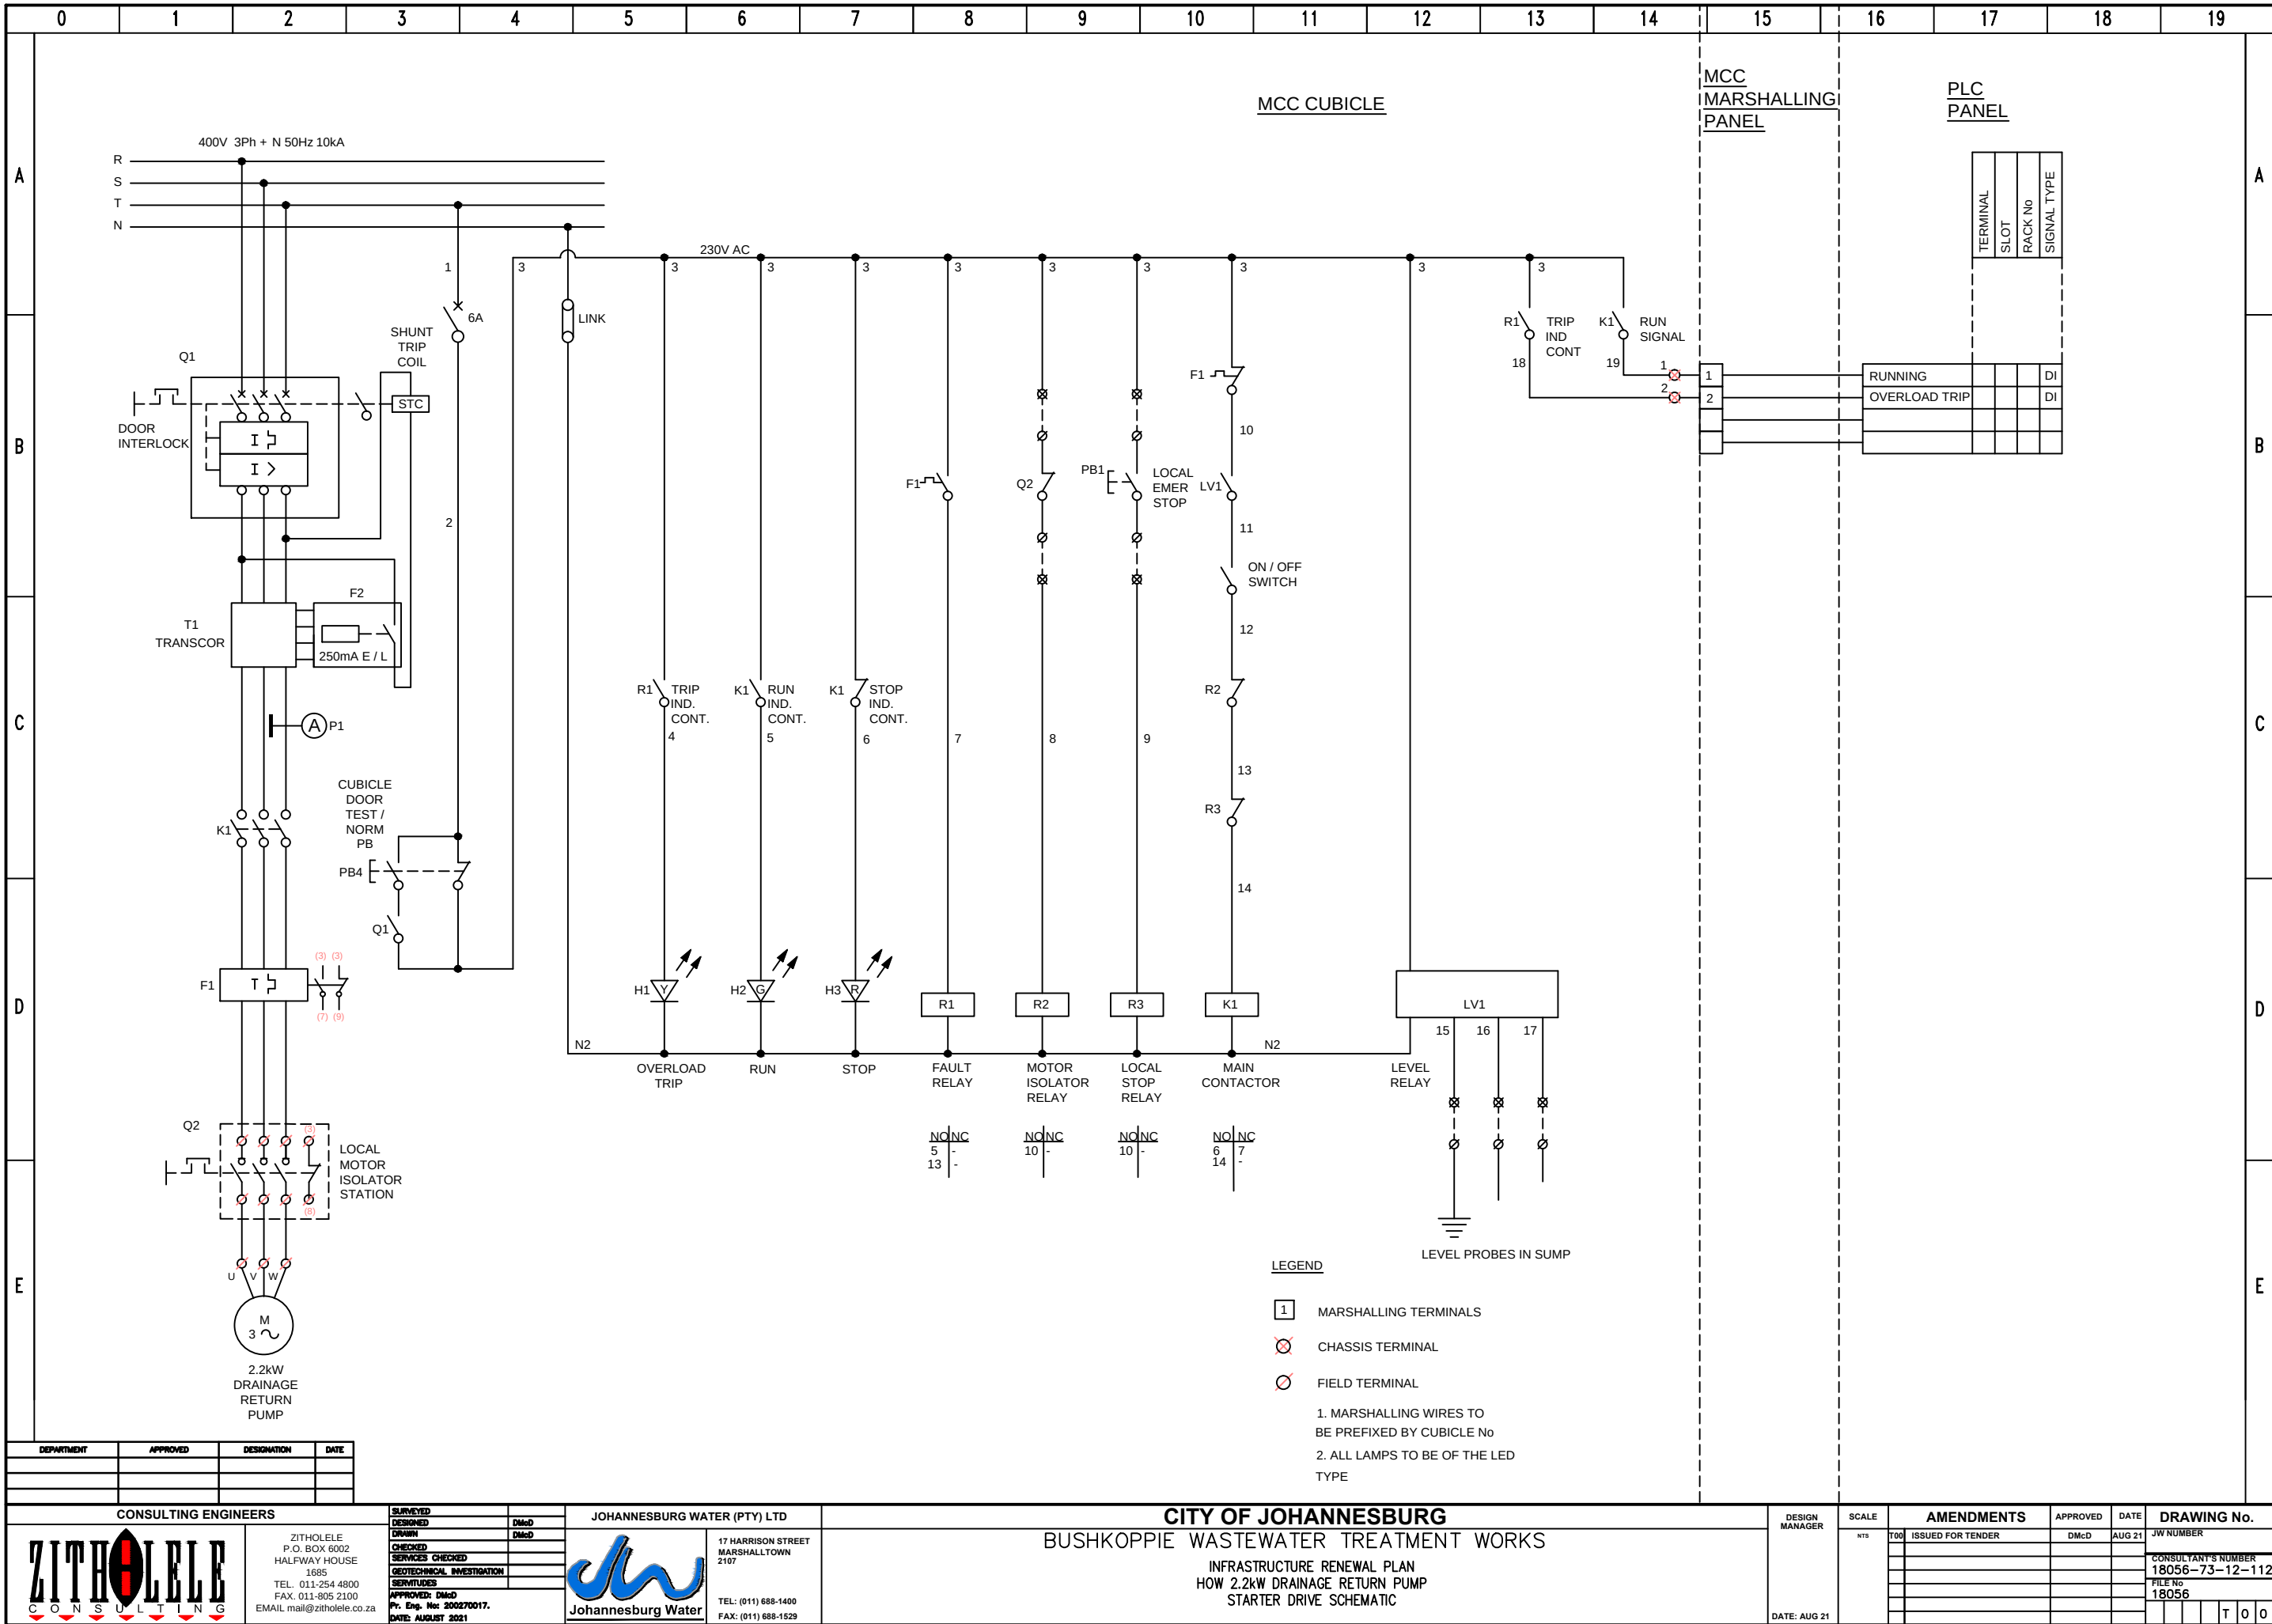


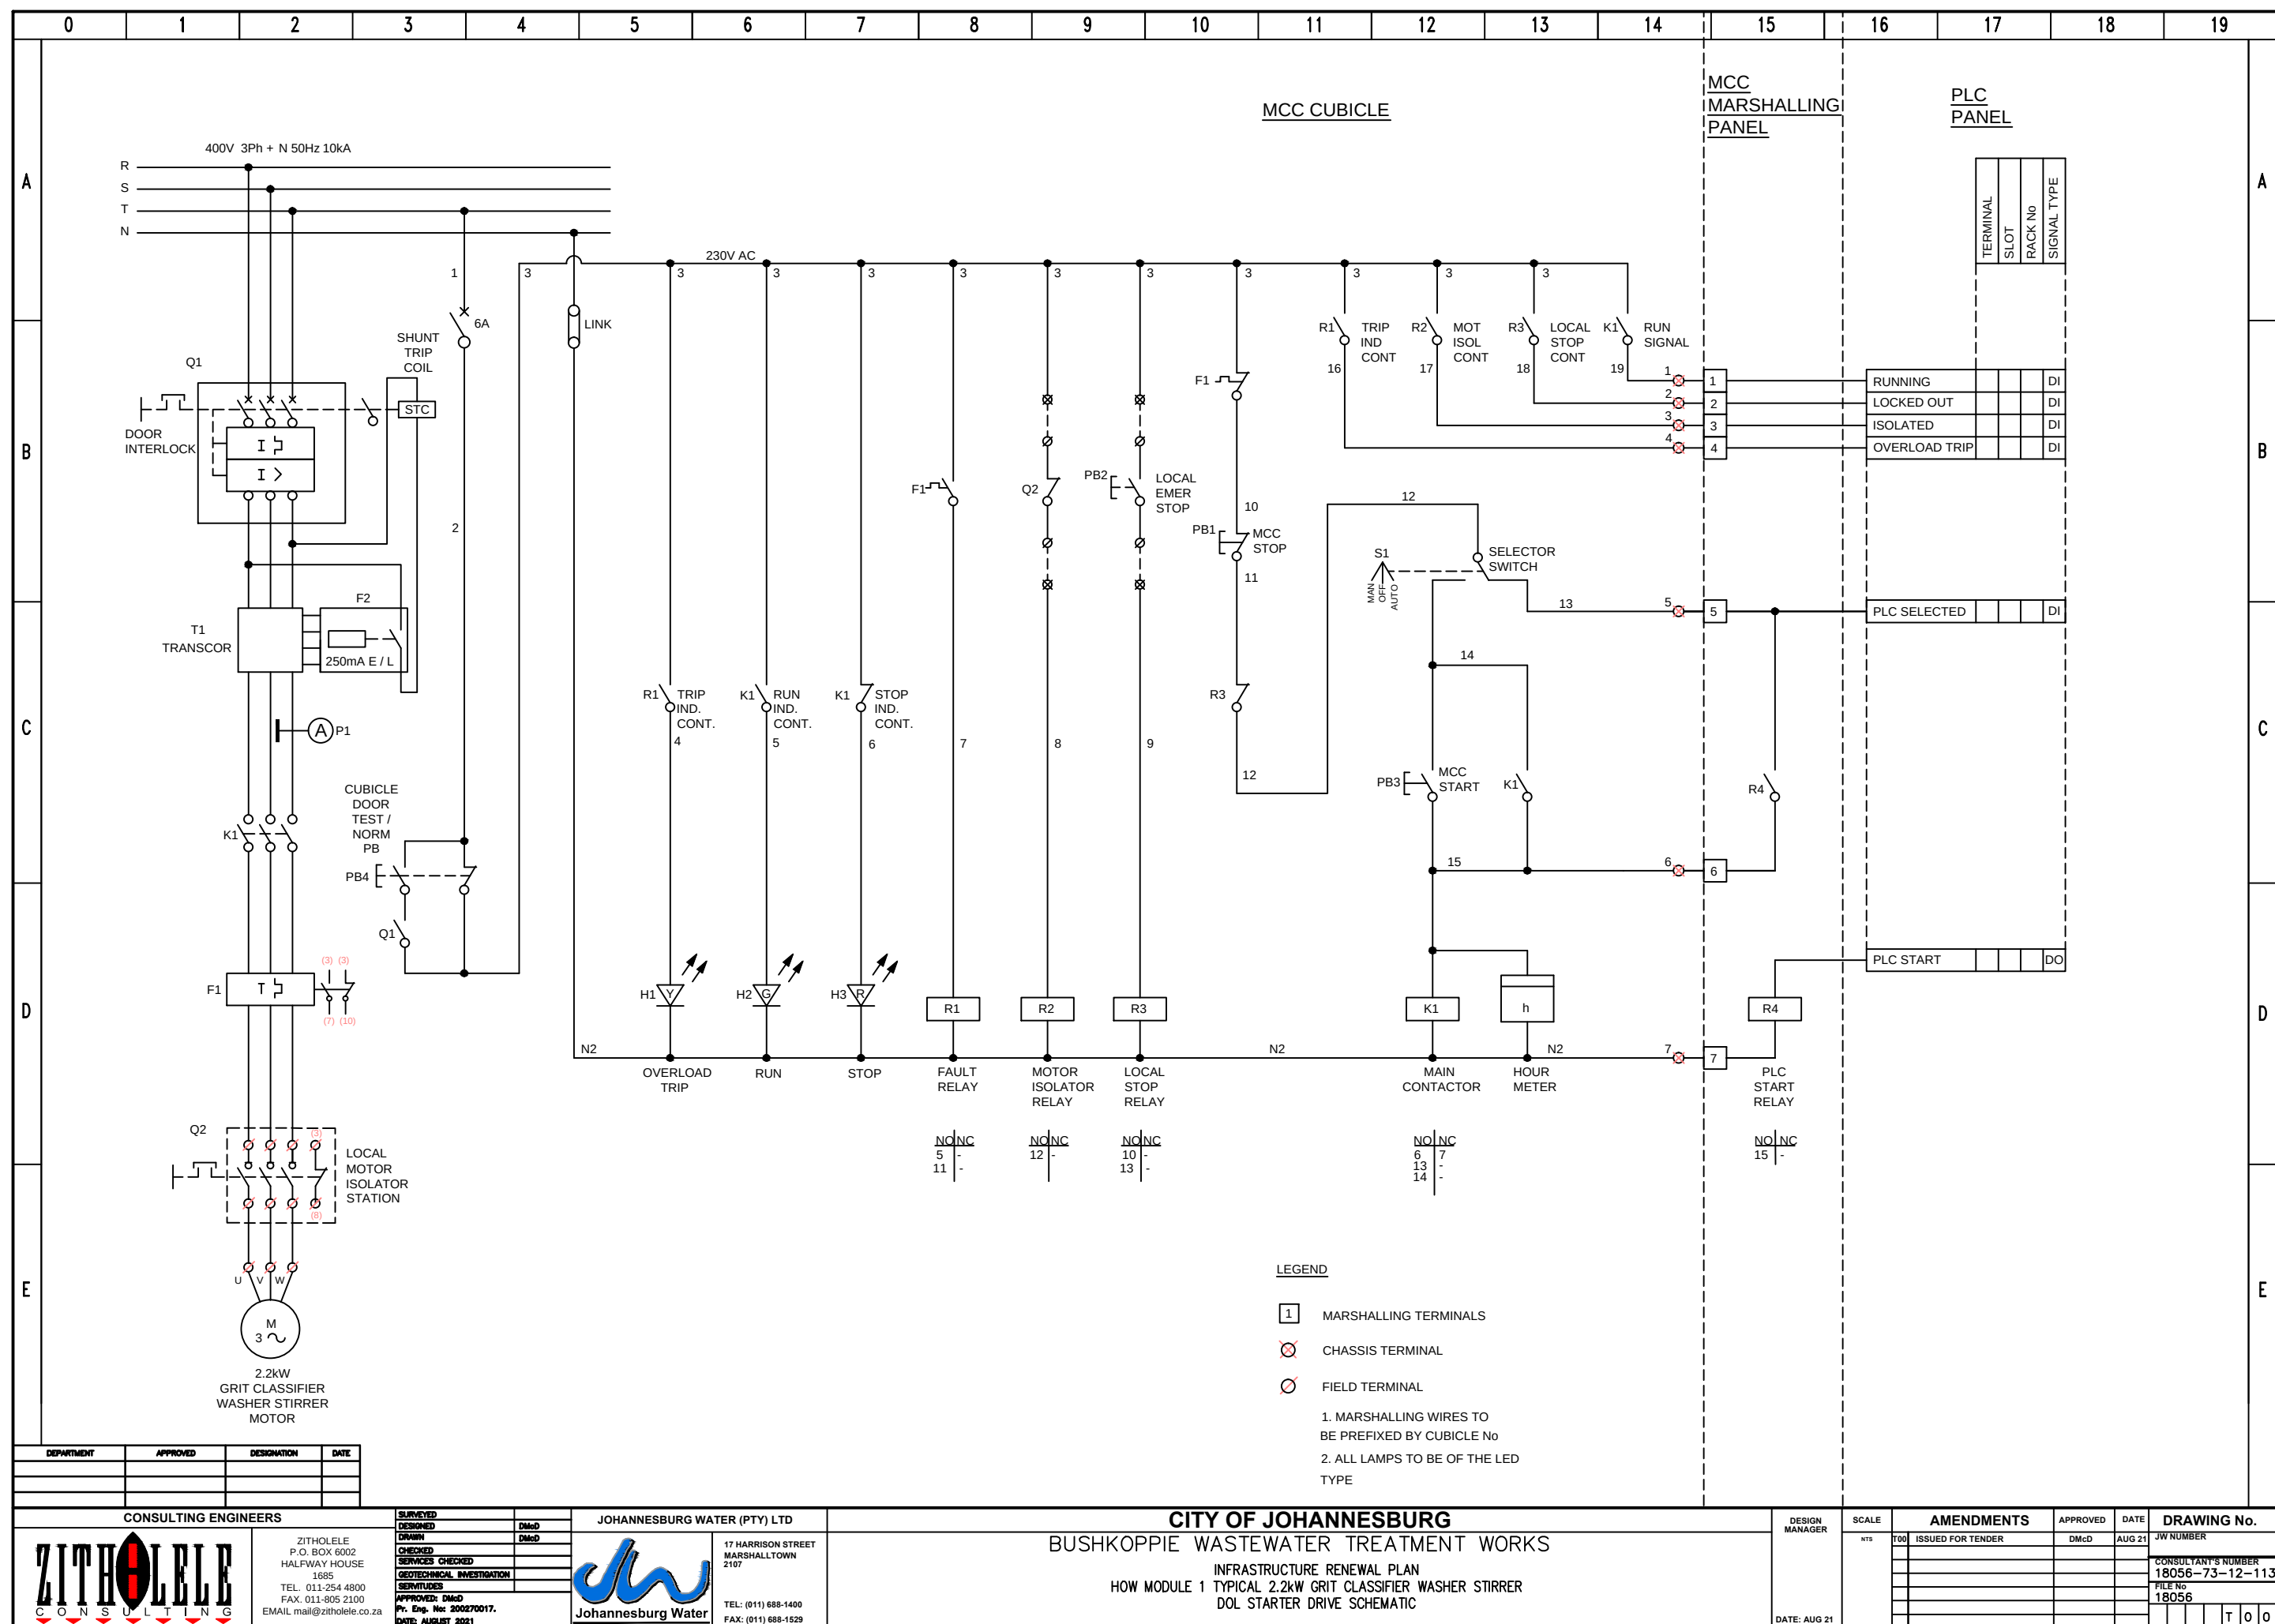

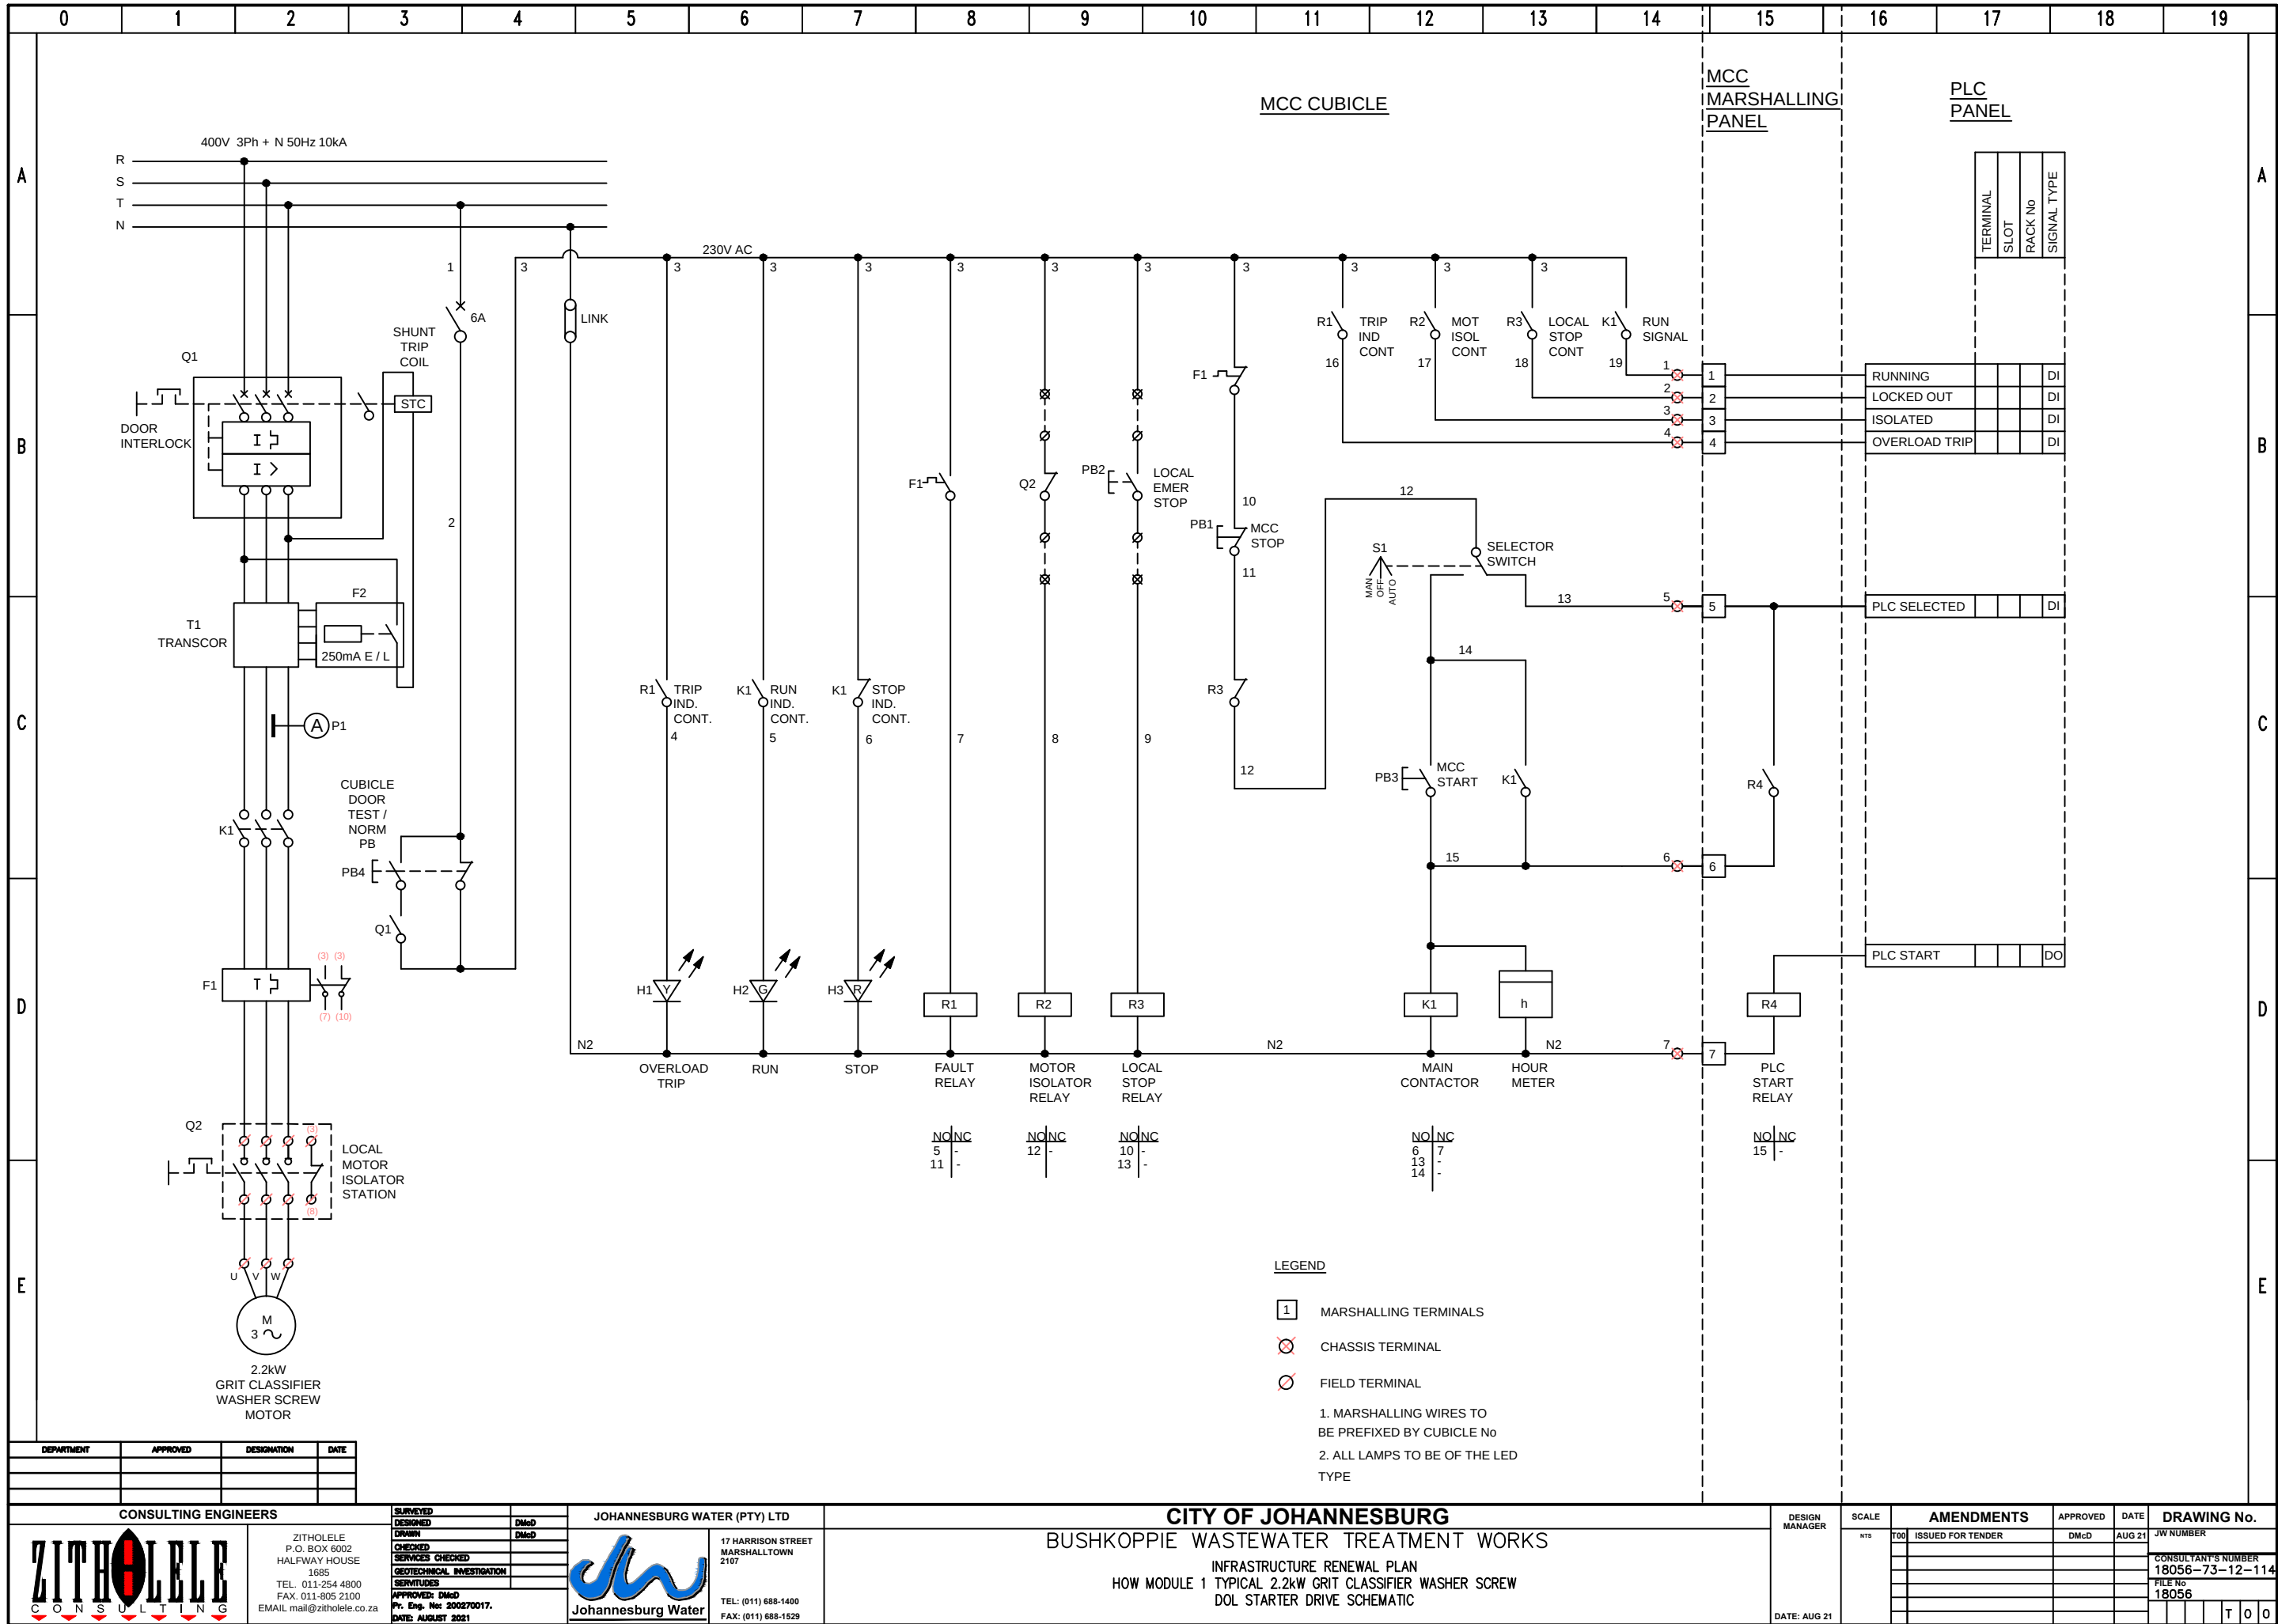


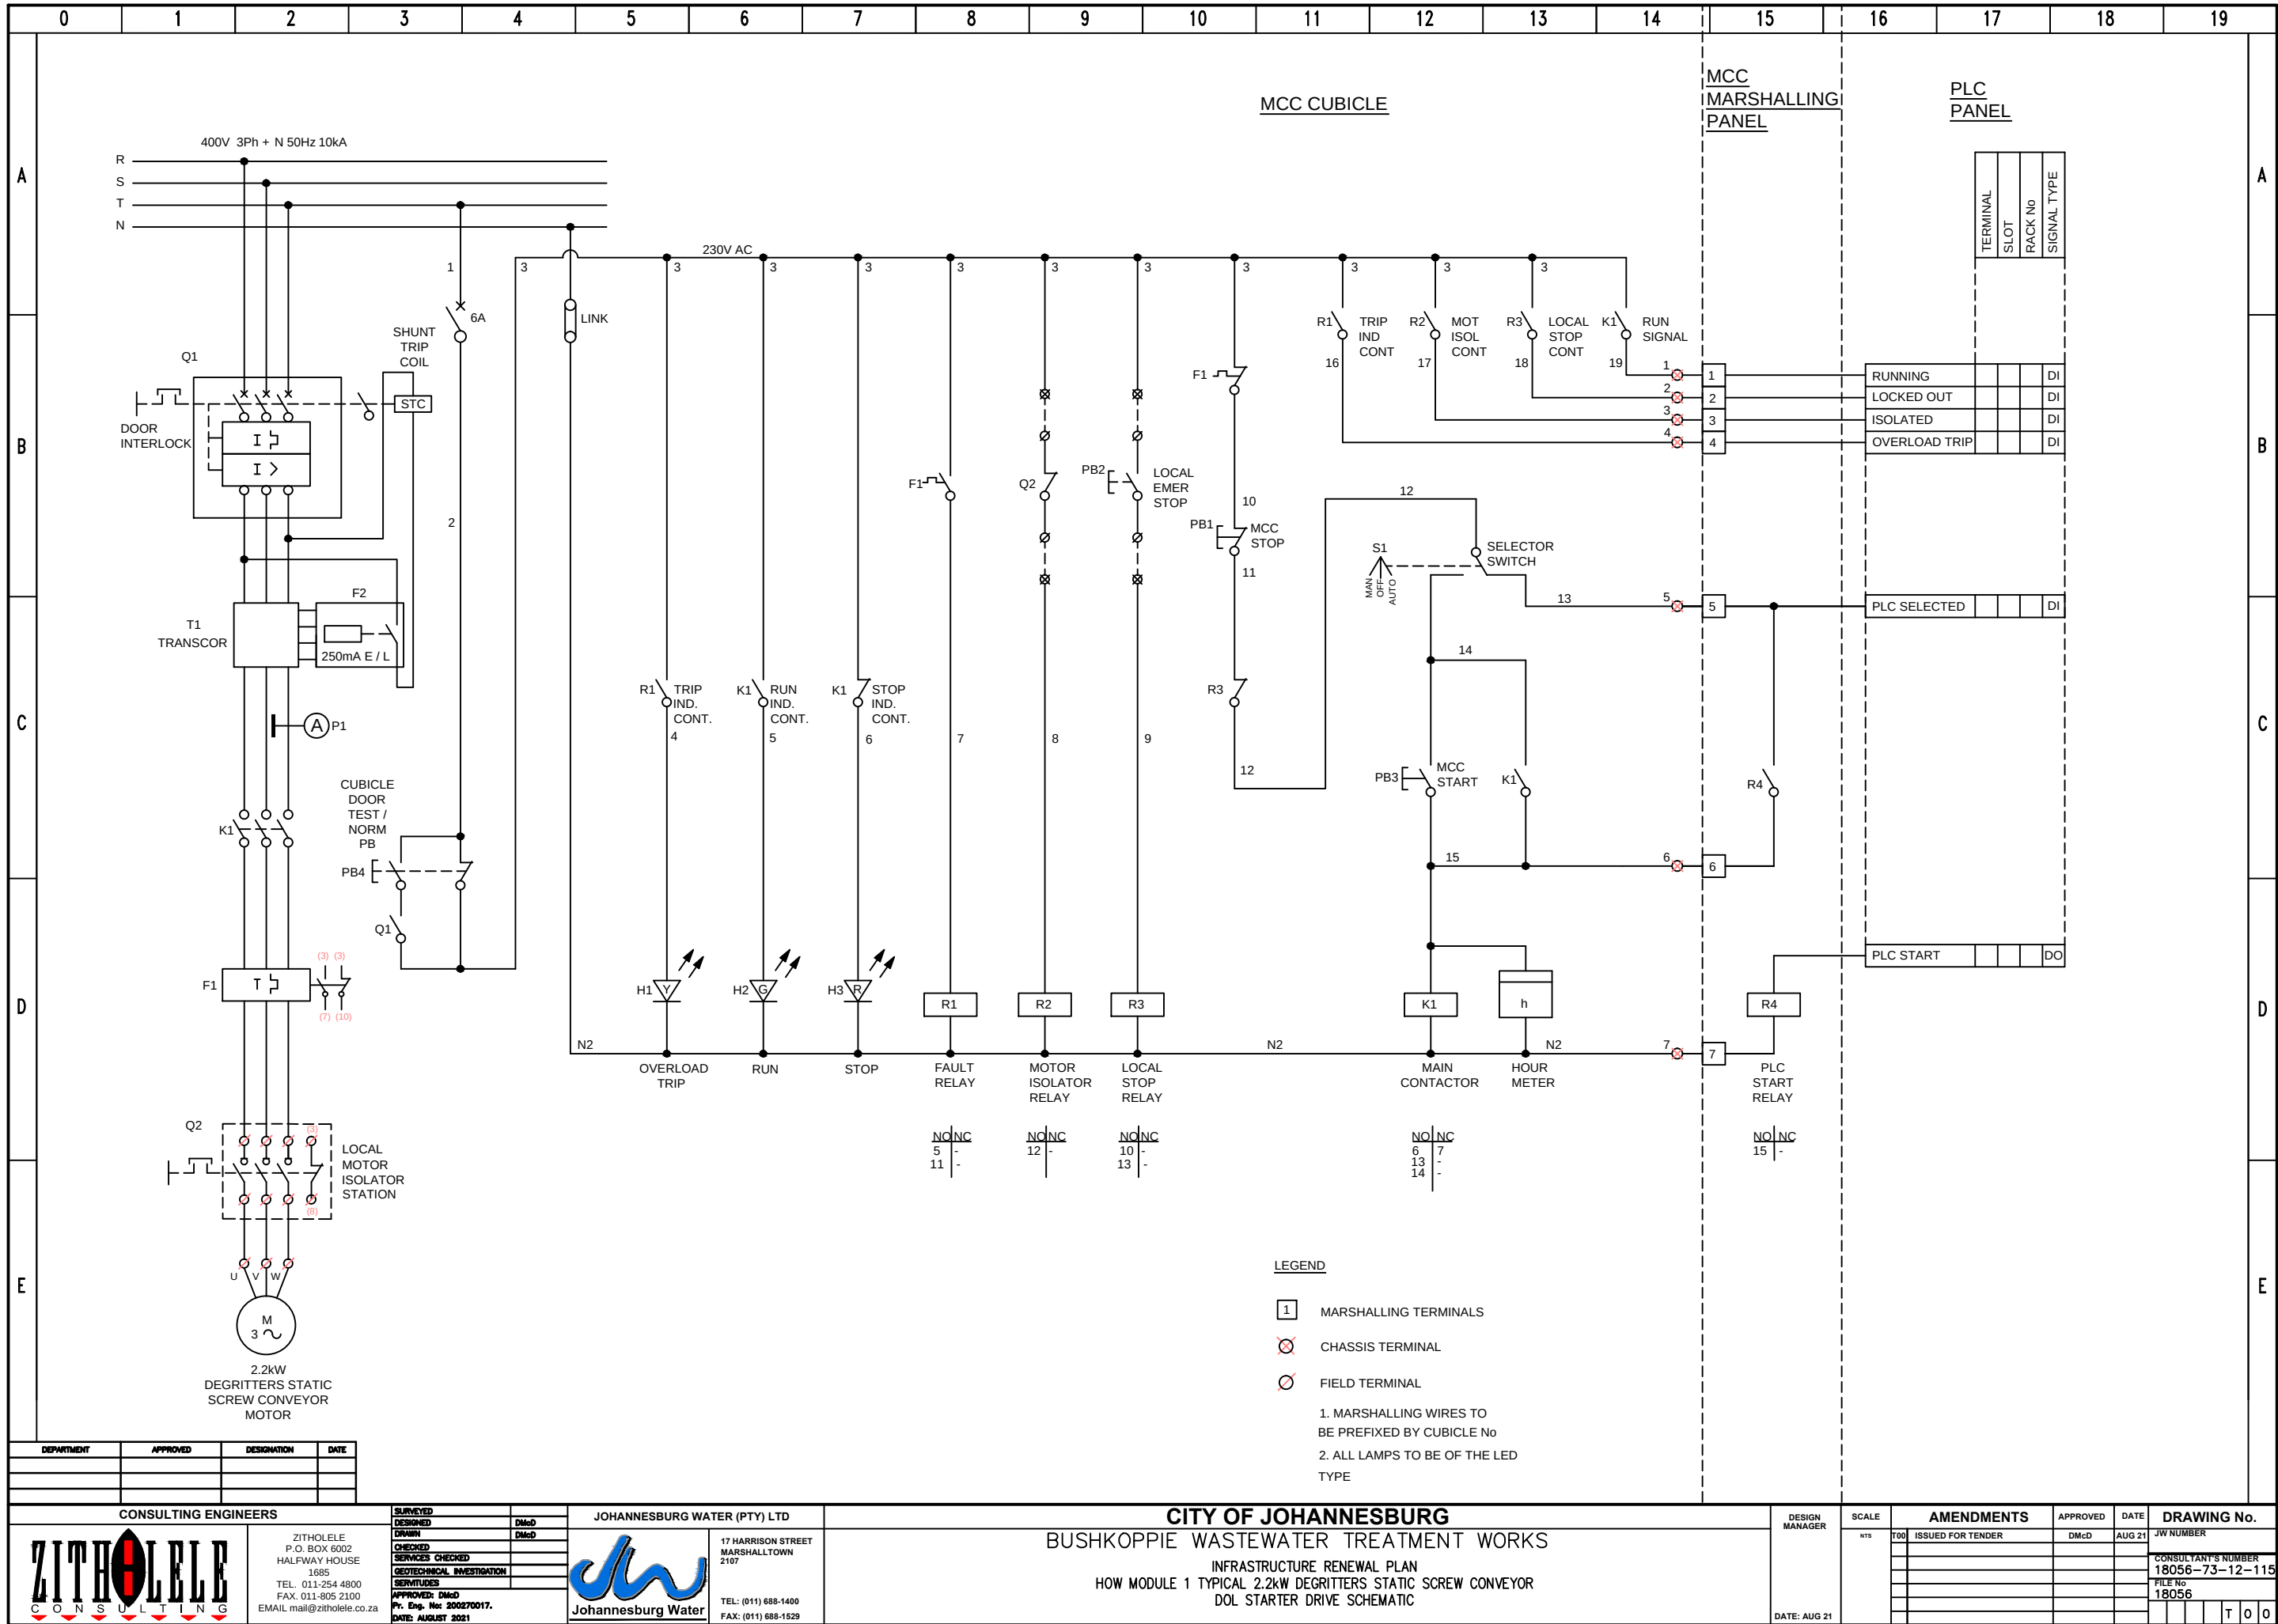


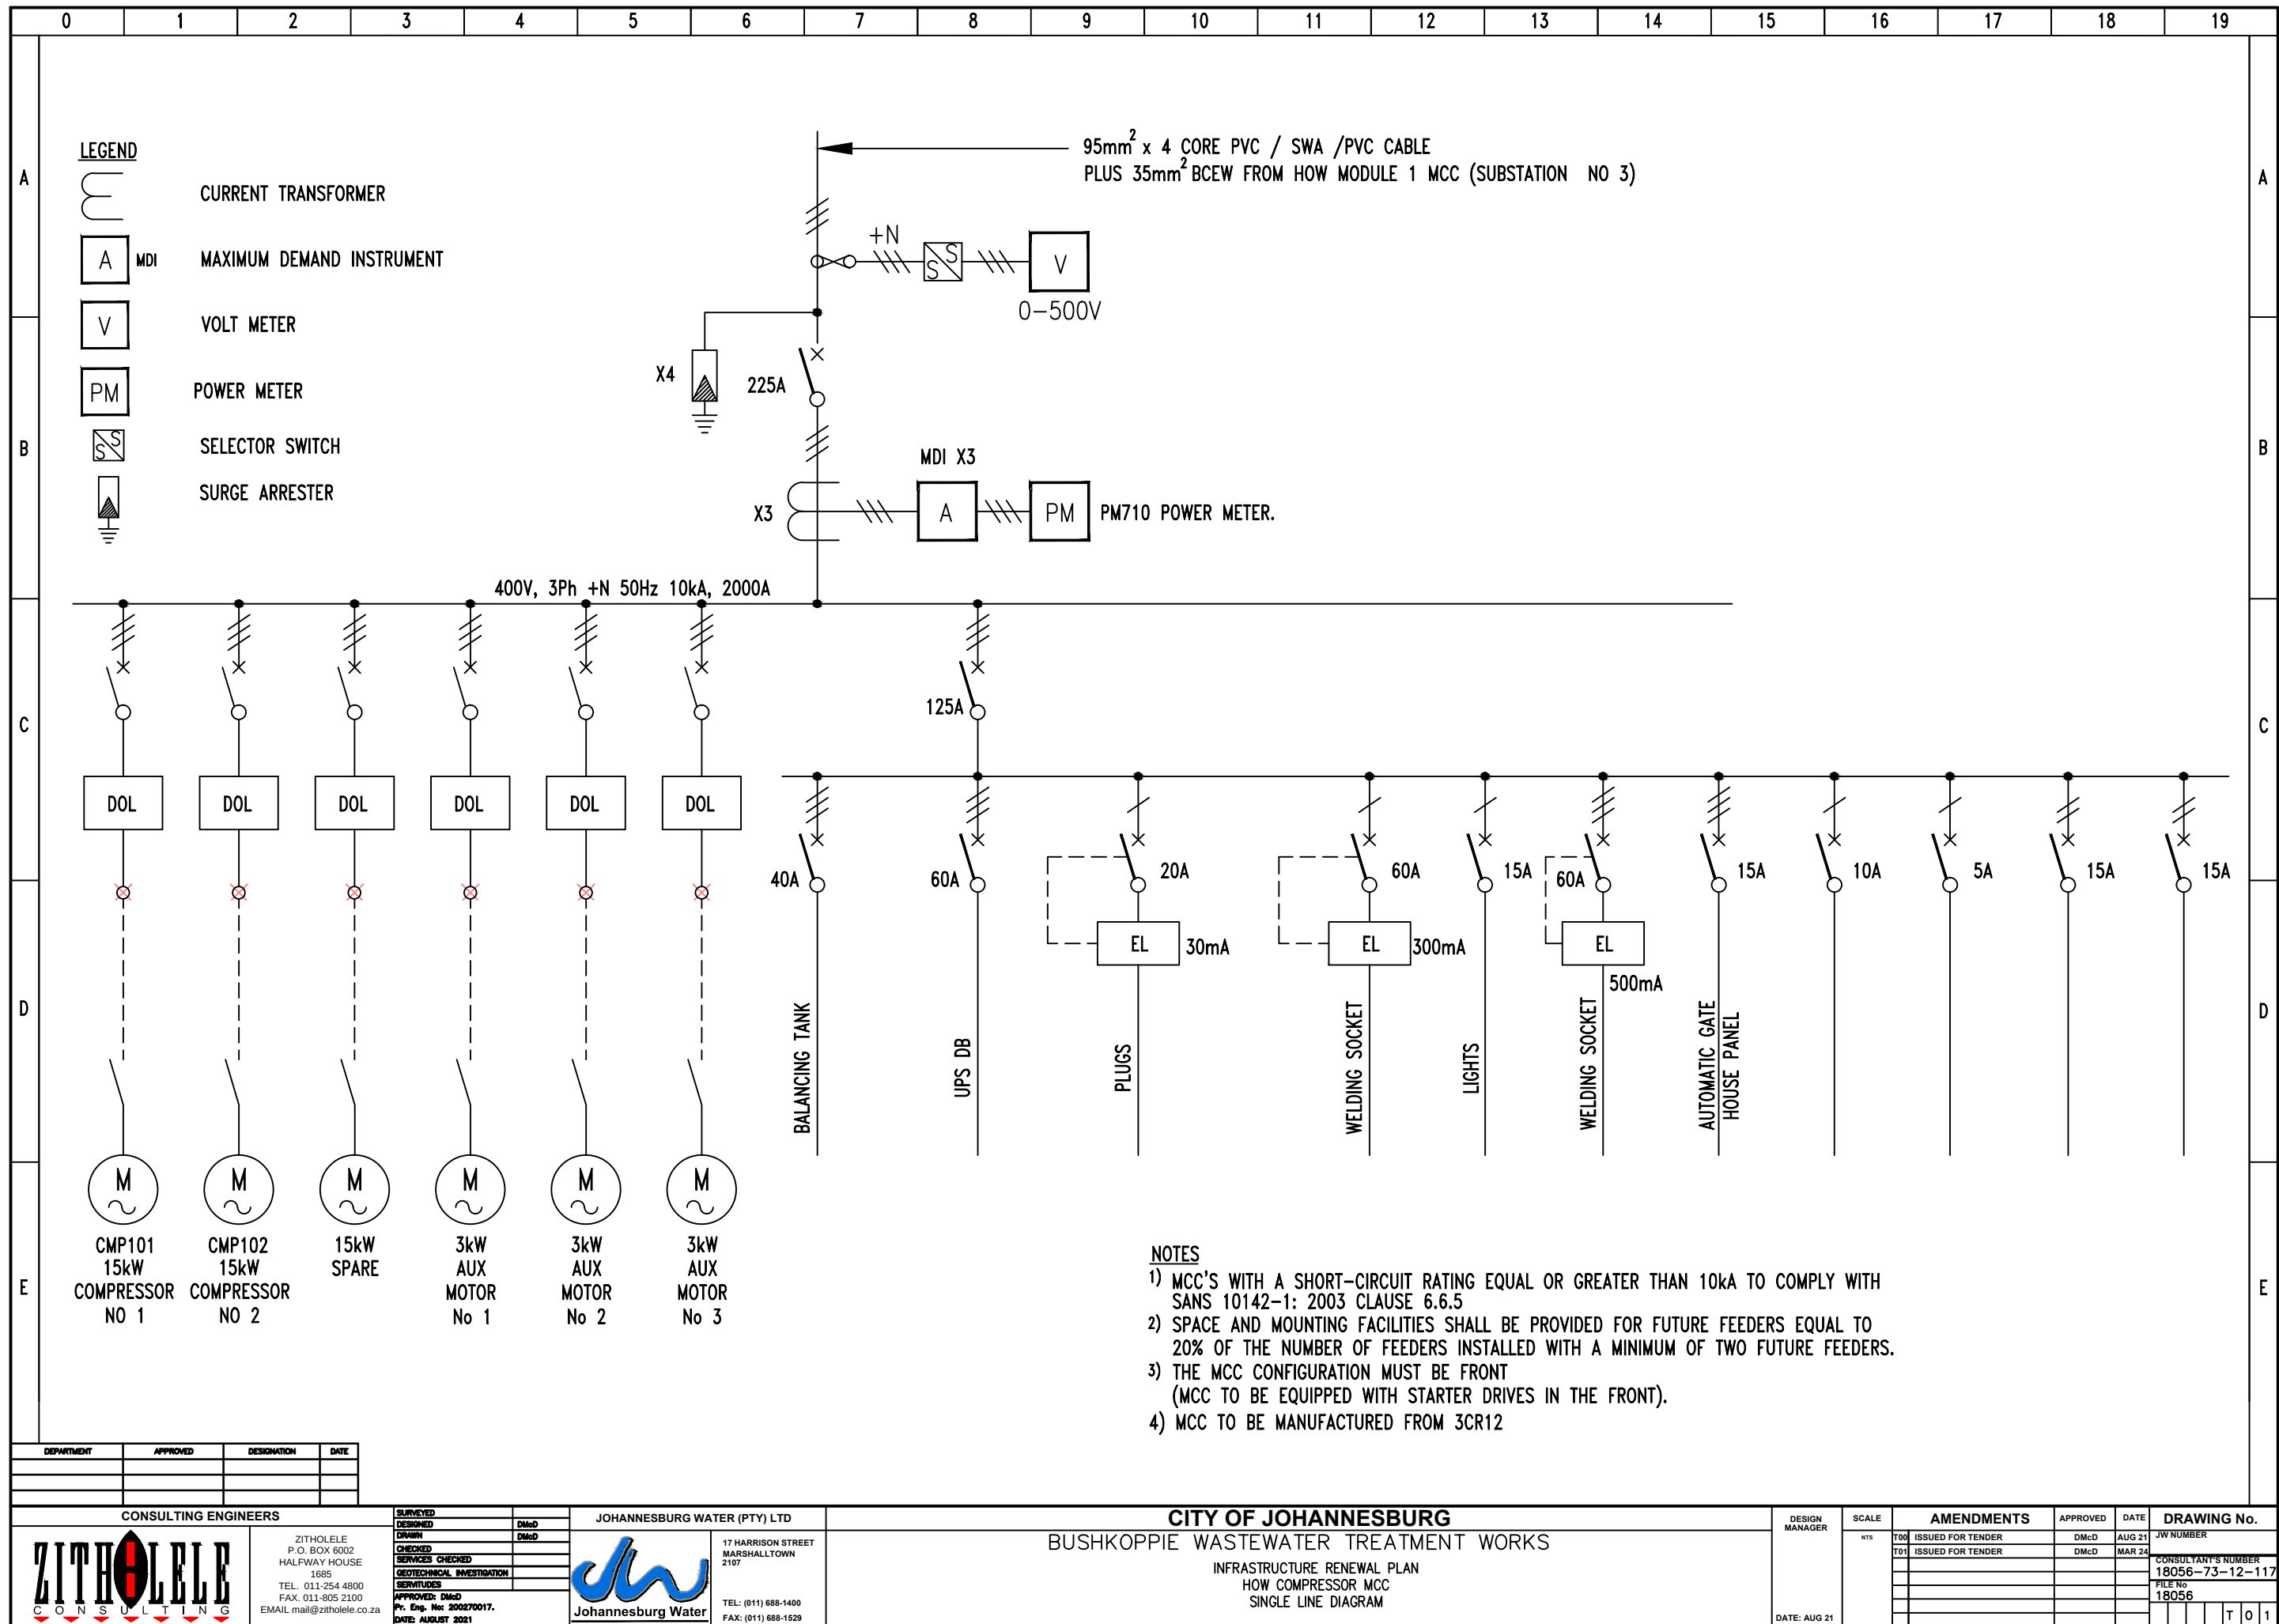


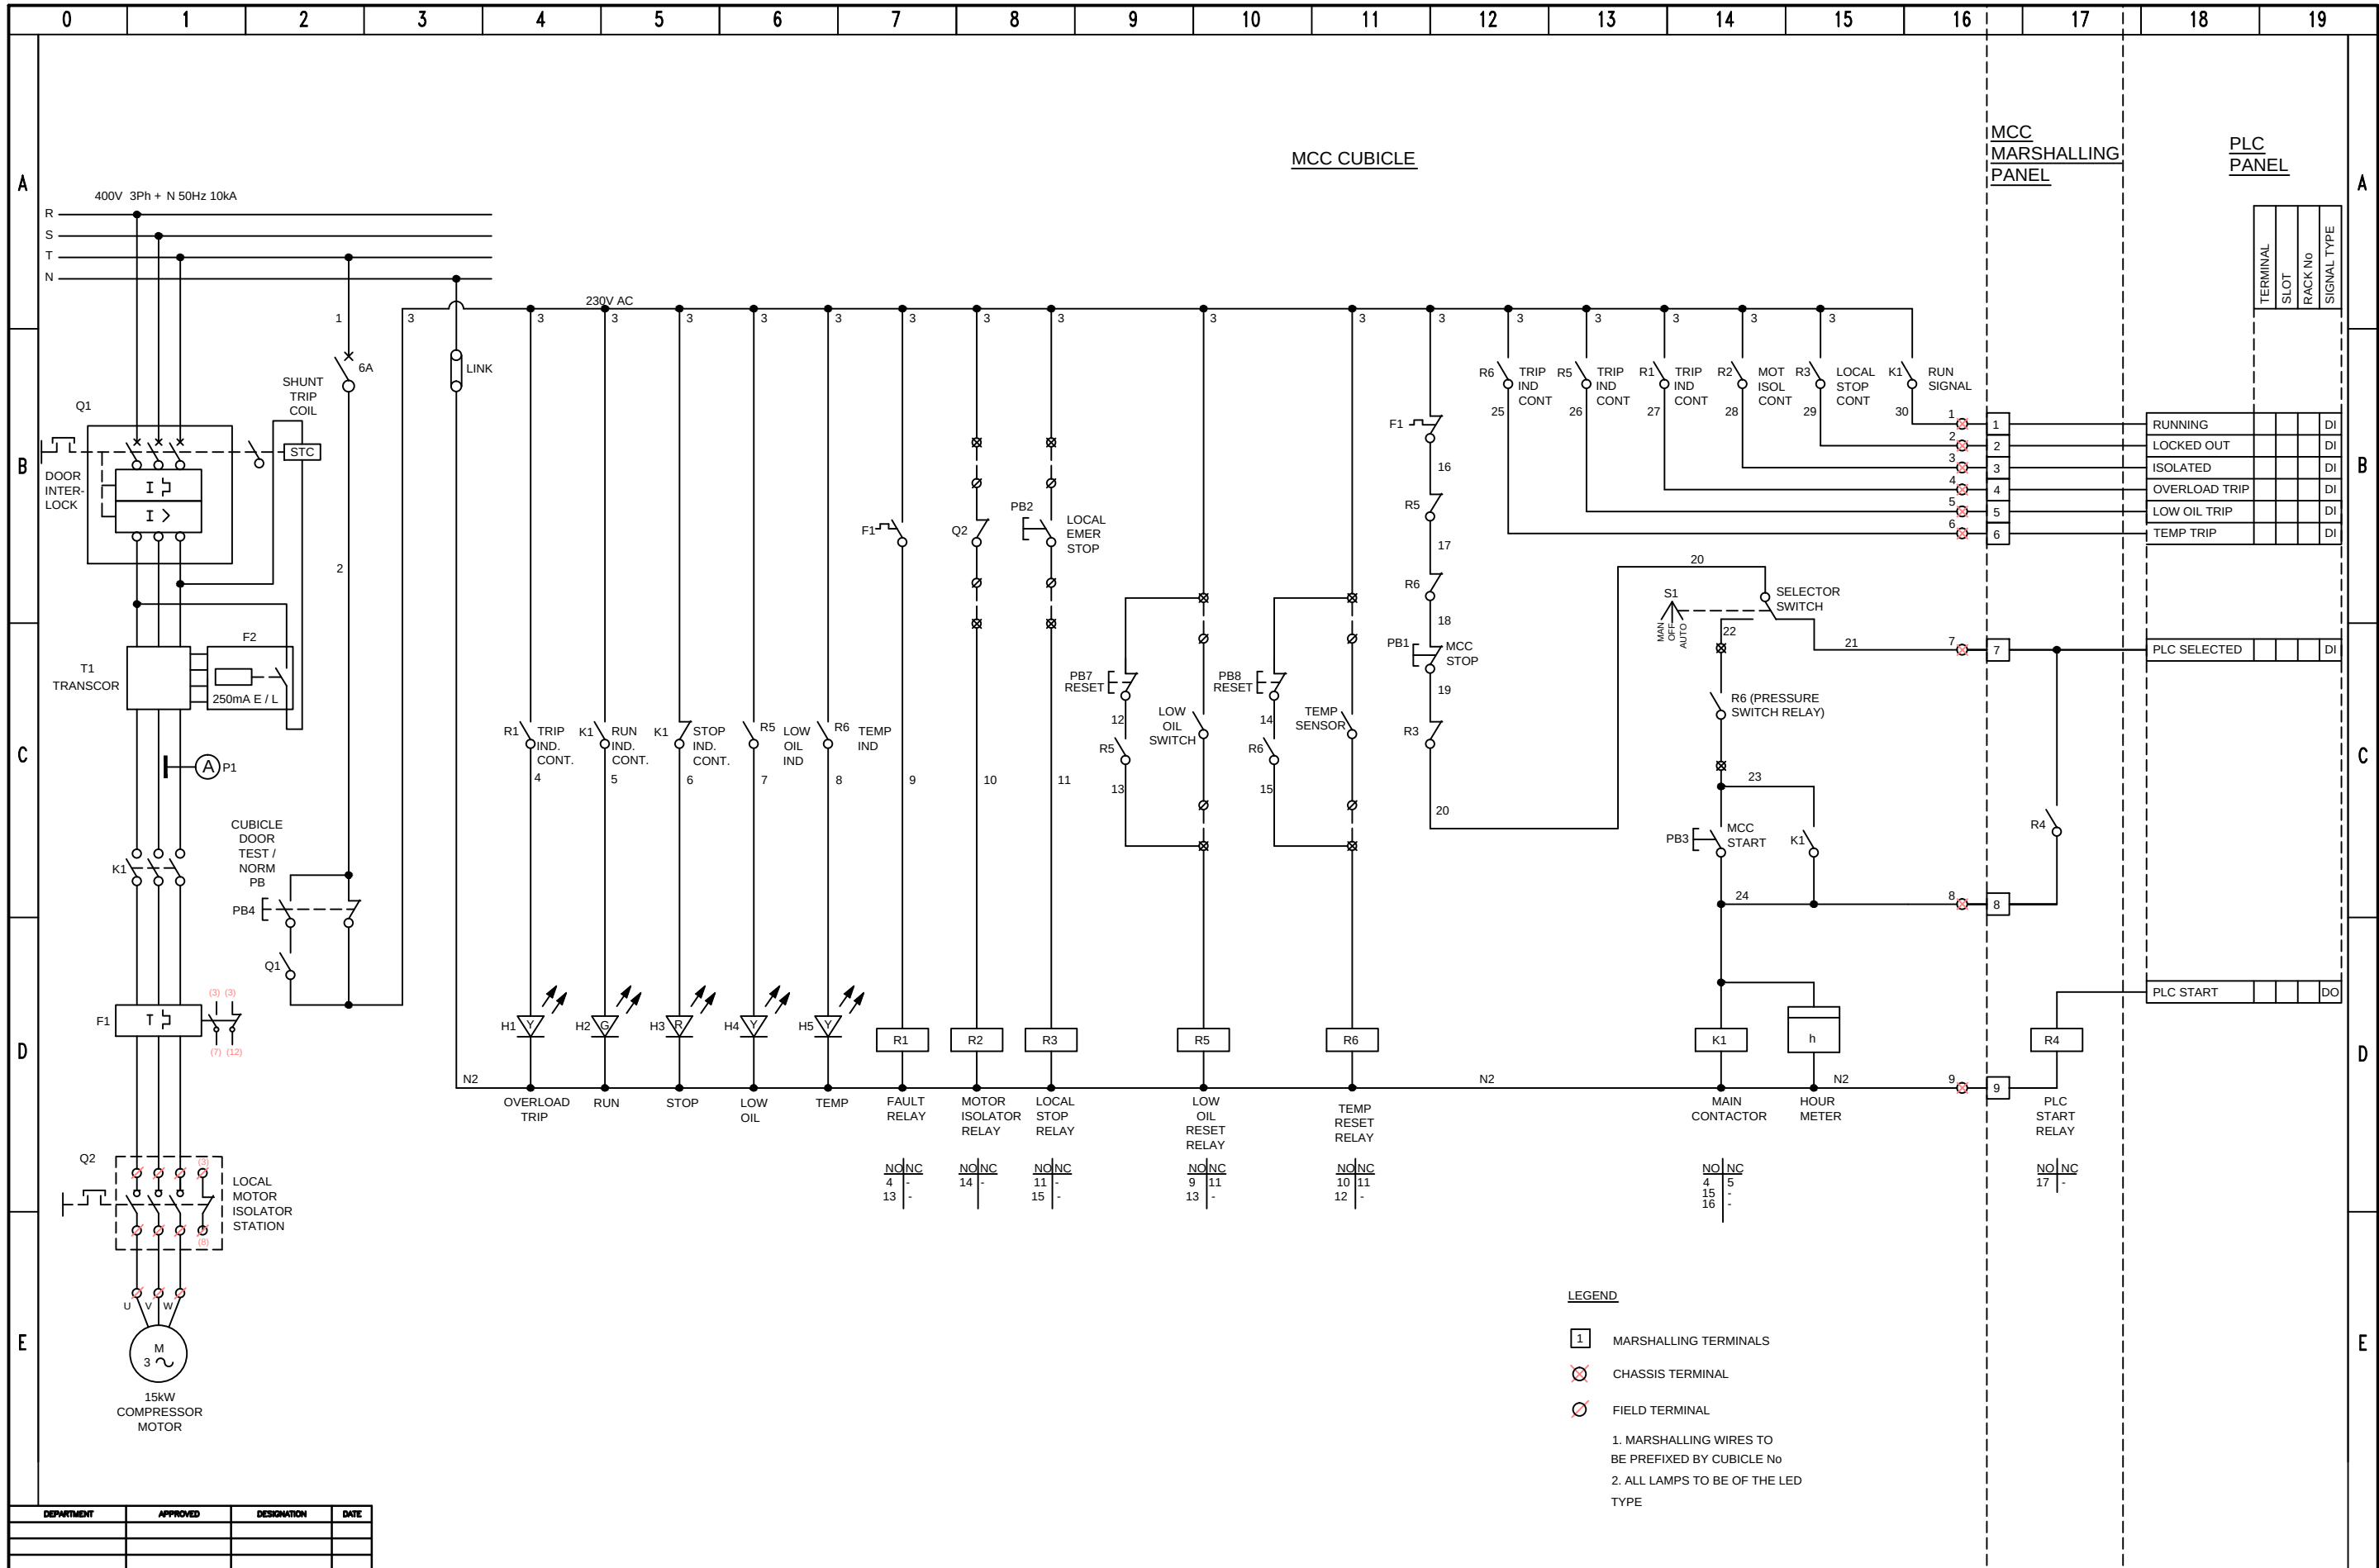


DEPARTMENT	APPROVED	DESIGNATION	DATE

 CONSULTING ENGINEERS				SURVEYED		JOHANNESBURG WATER (PTY) LTD		CITY OF JOHANNESBURG										DESIGN MANAGER	SCALE	AMENDMENTS		APPROVED	DATE	DRAWING No.																																																																																																																																																																																																																																																																																																																																																																																																																																																																																																						
 ZITHOLELE P.O. BOX 6002 HALFWAY HOUSE 1685 TEL: 011-254 4800 FAX: 011-805 2100 EMAIL: mail@zitholele.co.za				DESIGNED		 Johannesburg Water		BUSHKOPPIE WASTEWATER TREATMENT WORKS											NTS	T00	ISSUED FOR TENDER	DMcD	AUG 21	JW NUMBER	CONSULTANT'S NUMBER 18056-73-12-118																																																																																																																																																																																																																																																																																																																																																																																																																																																																																																					
				DRAWN																																																																																																																																																																																																																																																																																																																																																																																																																																																																																																																										
				CHECKED																																																																																																																																																																																																																																																																																																																																																																																																																																																																																																																										
				SERVICES CHECKED																																																																																																																																																																																																																																																																																																																																																																																																																																																																																																																										
				GEOTECHNICAL INVESTIGATION																																																																																																																																																																																																																																																																																																																																																																																																																																																																																																																										
						 Johannesburg Water		INFRASTRUCTURE RENEWAL PLAN HOW TYPICAL 15kW COMPRESSOR DOL STARTER DRIVE SCHEMATIC																	FILE No 18056																																																																																																																																																																																																																																																																																																																																																																																																																																																																																																					
SERVICES																																																																																																																																																																																																																																																																																																																																																																																																																																																																																																																														
APPROVED: DMcD																																																																																																																																																																																																																																																																																																																																																																																																																																																																																																																														
P. Eng. No: 200270017.																																																																																																																																																																																																																																																																																																																																																																																																																																																																																																																														
DATE: AUGUST 2021																																																																																																																																																																																																																																																																																																																																																																																																																																																																																																																														

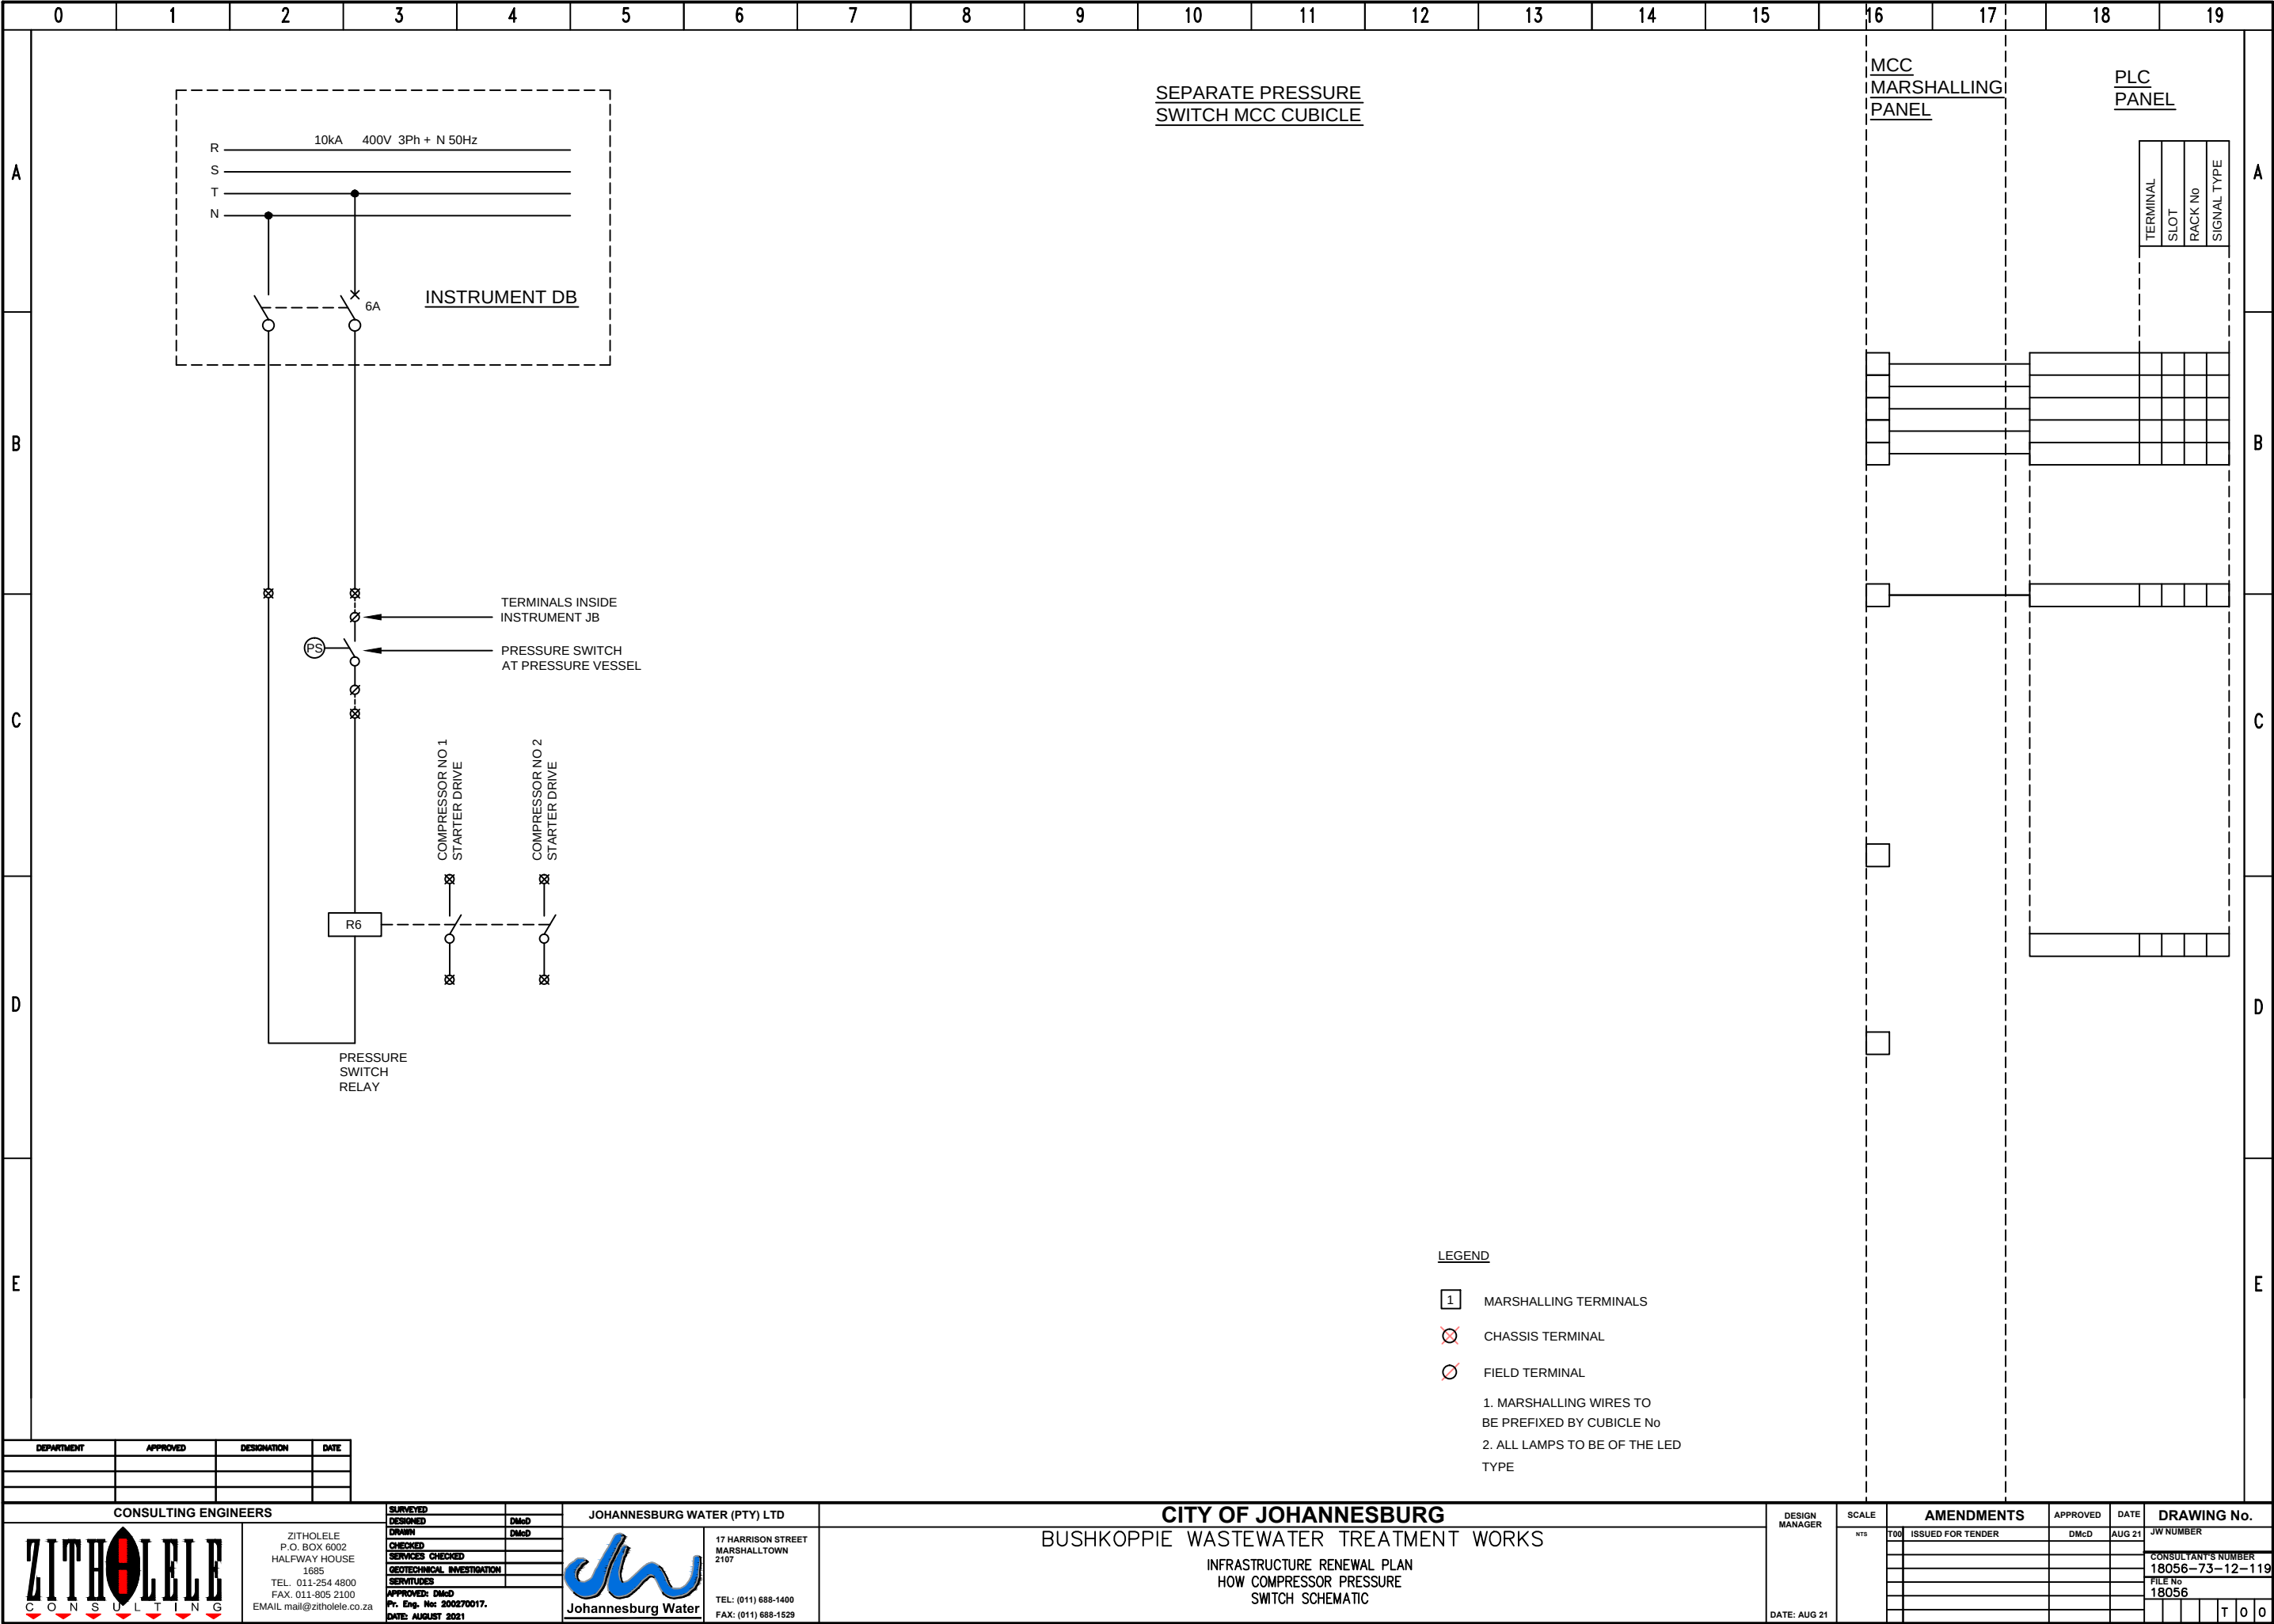

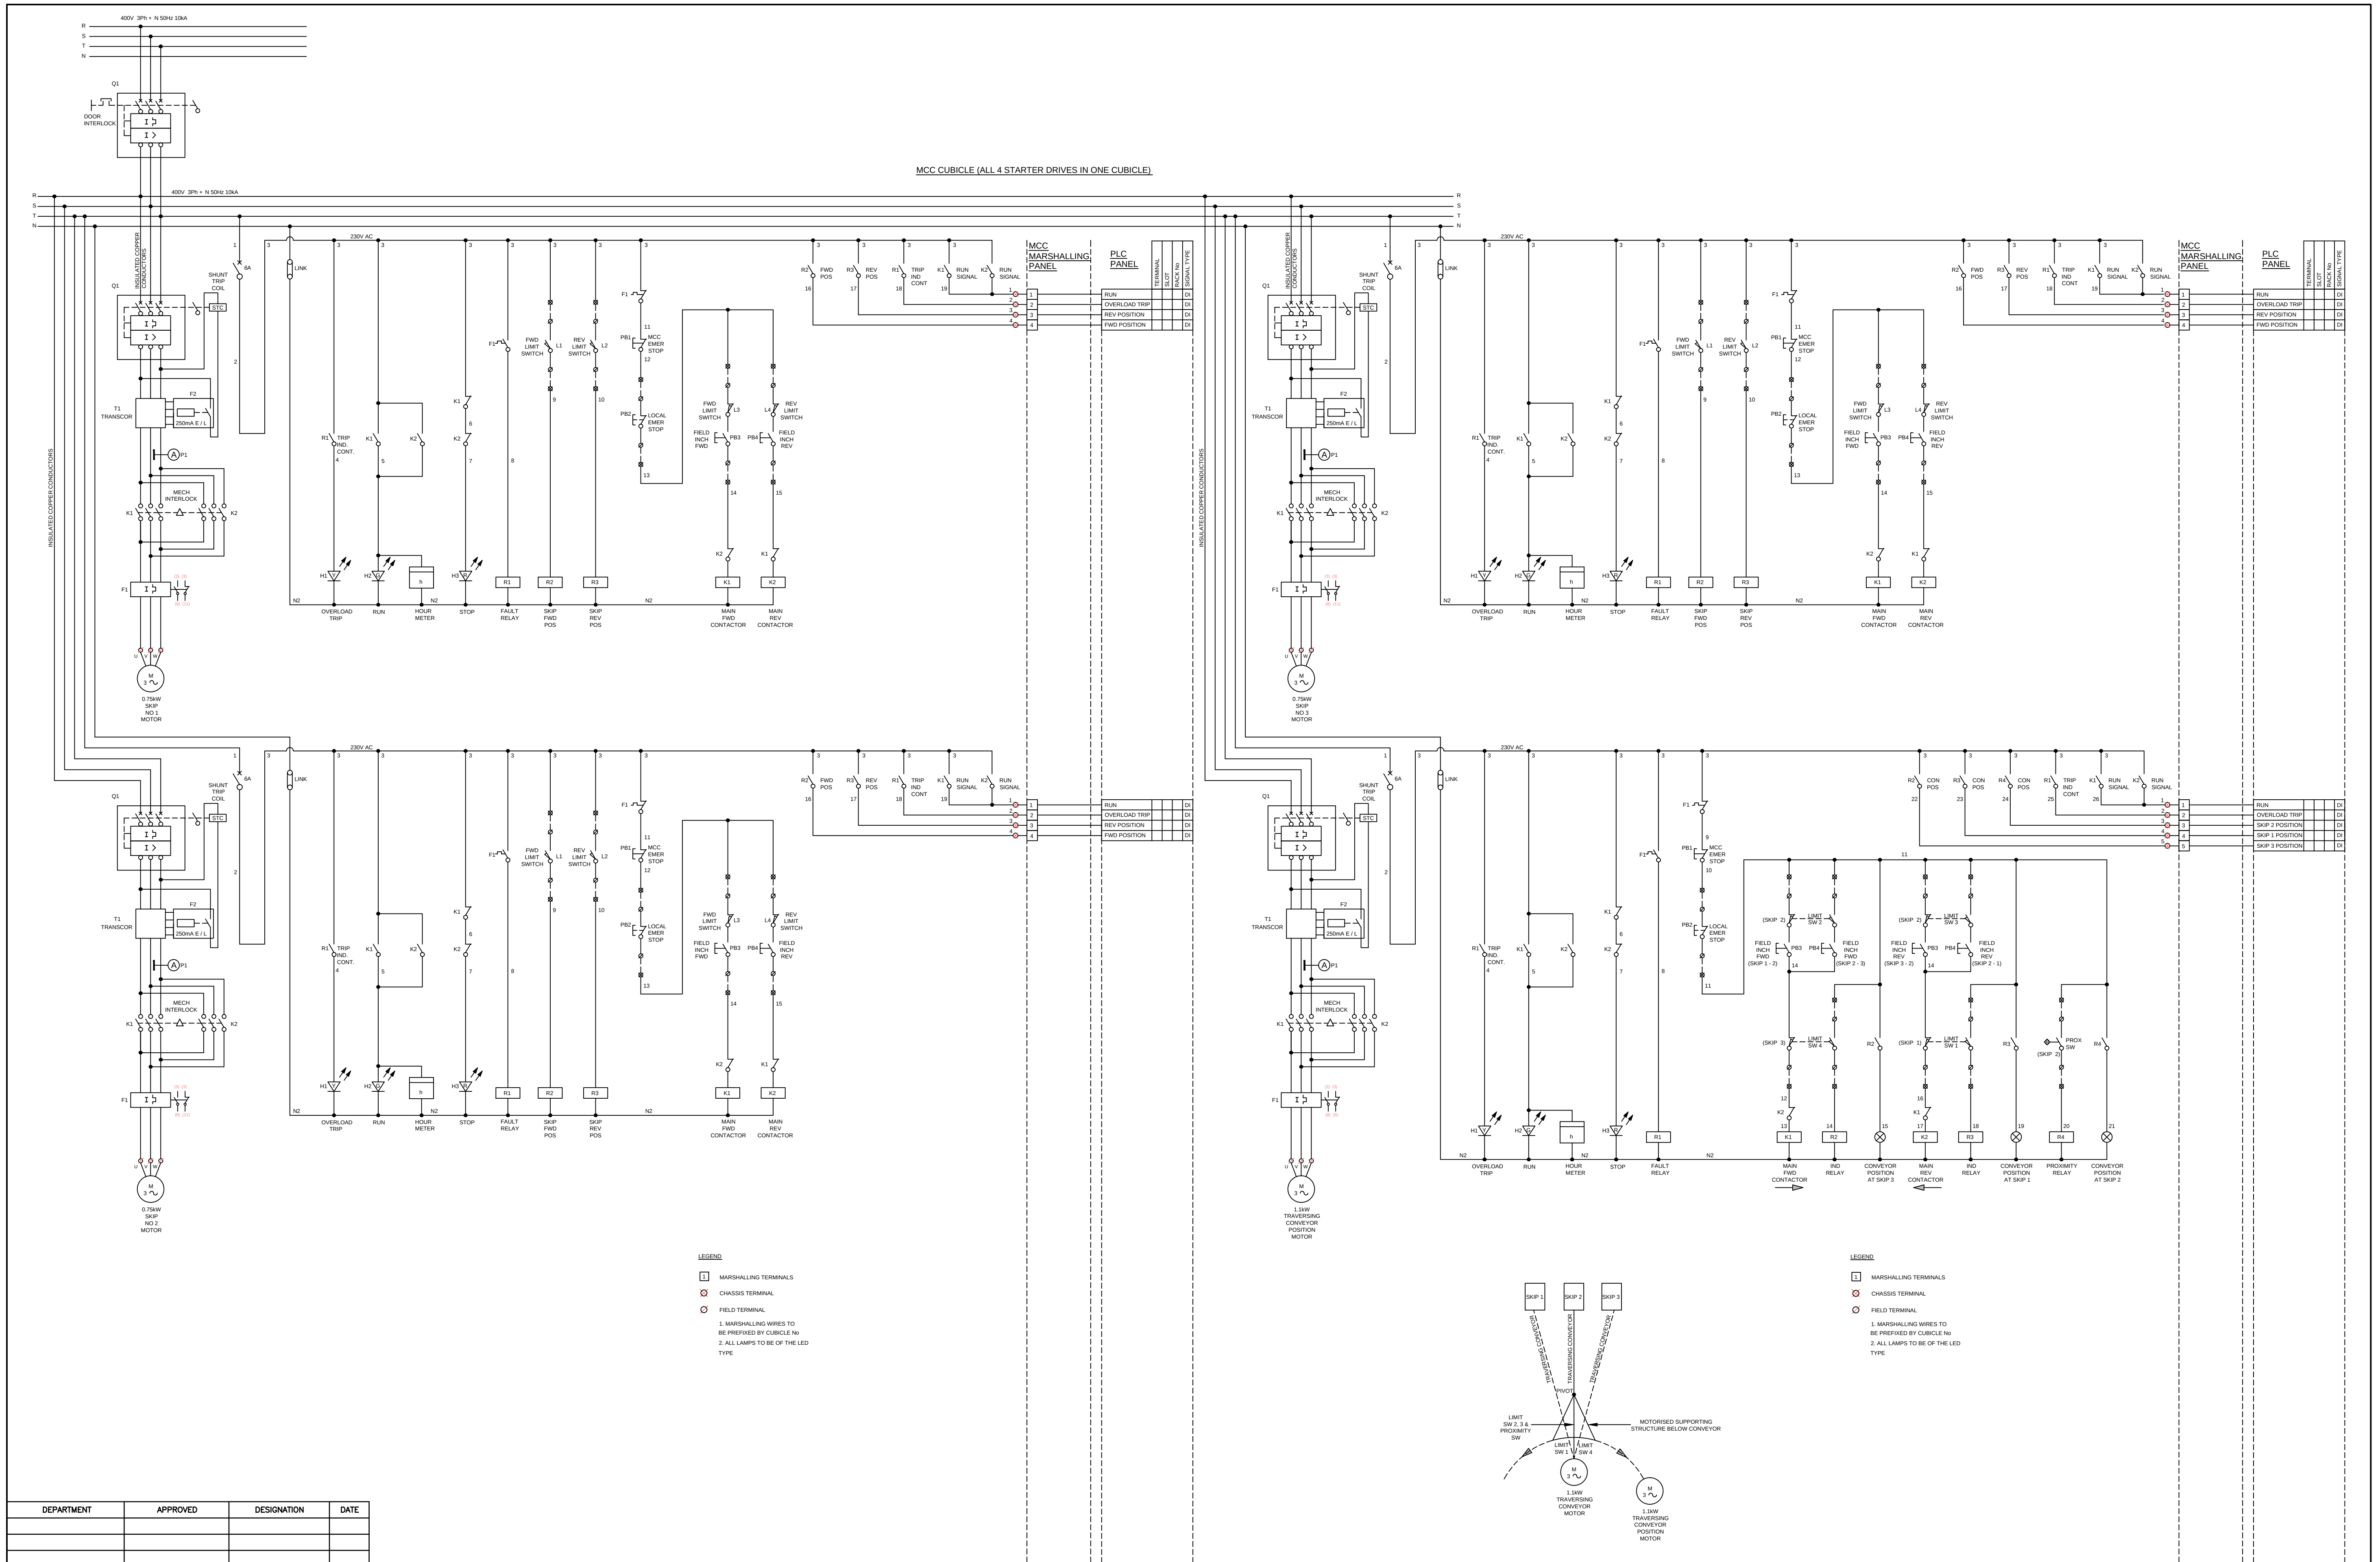

DEPARTMENT	APPROVED	DESIGNATION	DATE

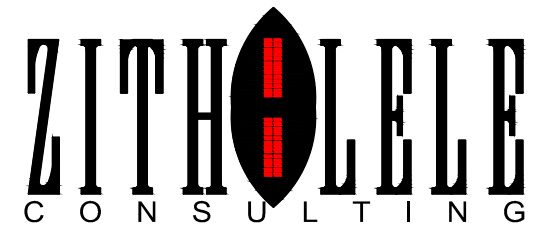CONSULTING ENGINEERS

ZITHOLELE
P.O. BOX 6002
HALFWAY HOUSE
1685
TEL: 011-254 4800
FAX: 011-905 2100
EMAIL: mail@zitholele.co.za


SURVEYED	
DESIGNED	DmC
DRAWN	DmC
CHECKED	
SERVICES CHECKED	
GEO-TECHNICAL INVESTIGATION	
APPROVED: DmC	
Pr. Eng. No: 200270017.	
DATE: AUGUST 2021	


JOHANNESBURG WATER (PTY) LTD


17 HARRISON STREET
MARSHALLTOWN
2107
TEL: (011) 688-1400
FAX: (011) 688-1529


CITY OF JOHANNESBURG
BUSHKOPPIE WASTEWATER TREATMENT WORKS
INFRASTRUCTURE RENEWAL PLAN
HOW SKIP WINCH & TRAVERSING CONVEYOR POSITION
DOL STARTER DRIVES SCHEMATIC


DESIGN MANAGER	SCALE	AMENDMENTS	APPROVED	DATE	DRAWING No.
	NTS	T00 ISSUED FOR TENDER	DmC	AUG 21	JW NUMBER CONSULTANT'S NUMBER 18056-73-12-120 FILE NO 18056
DATE: AUG 21					T 0 0

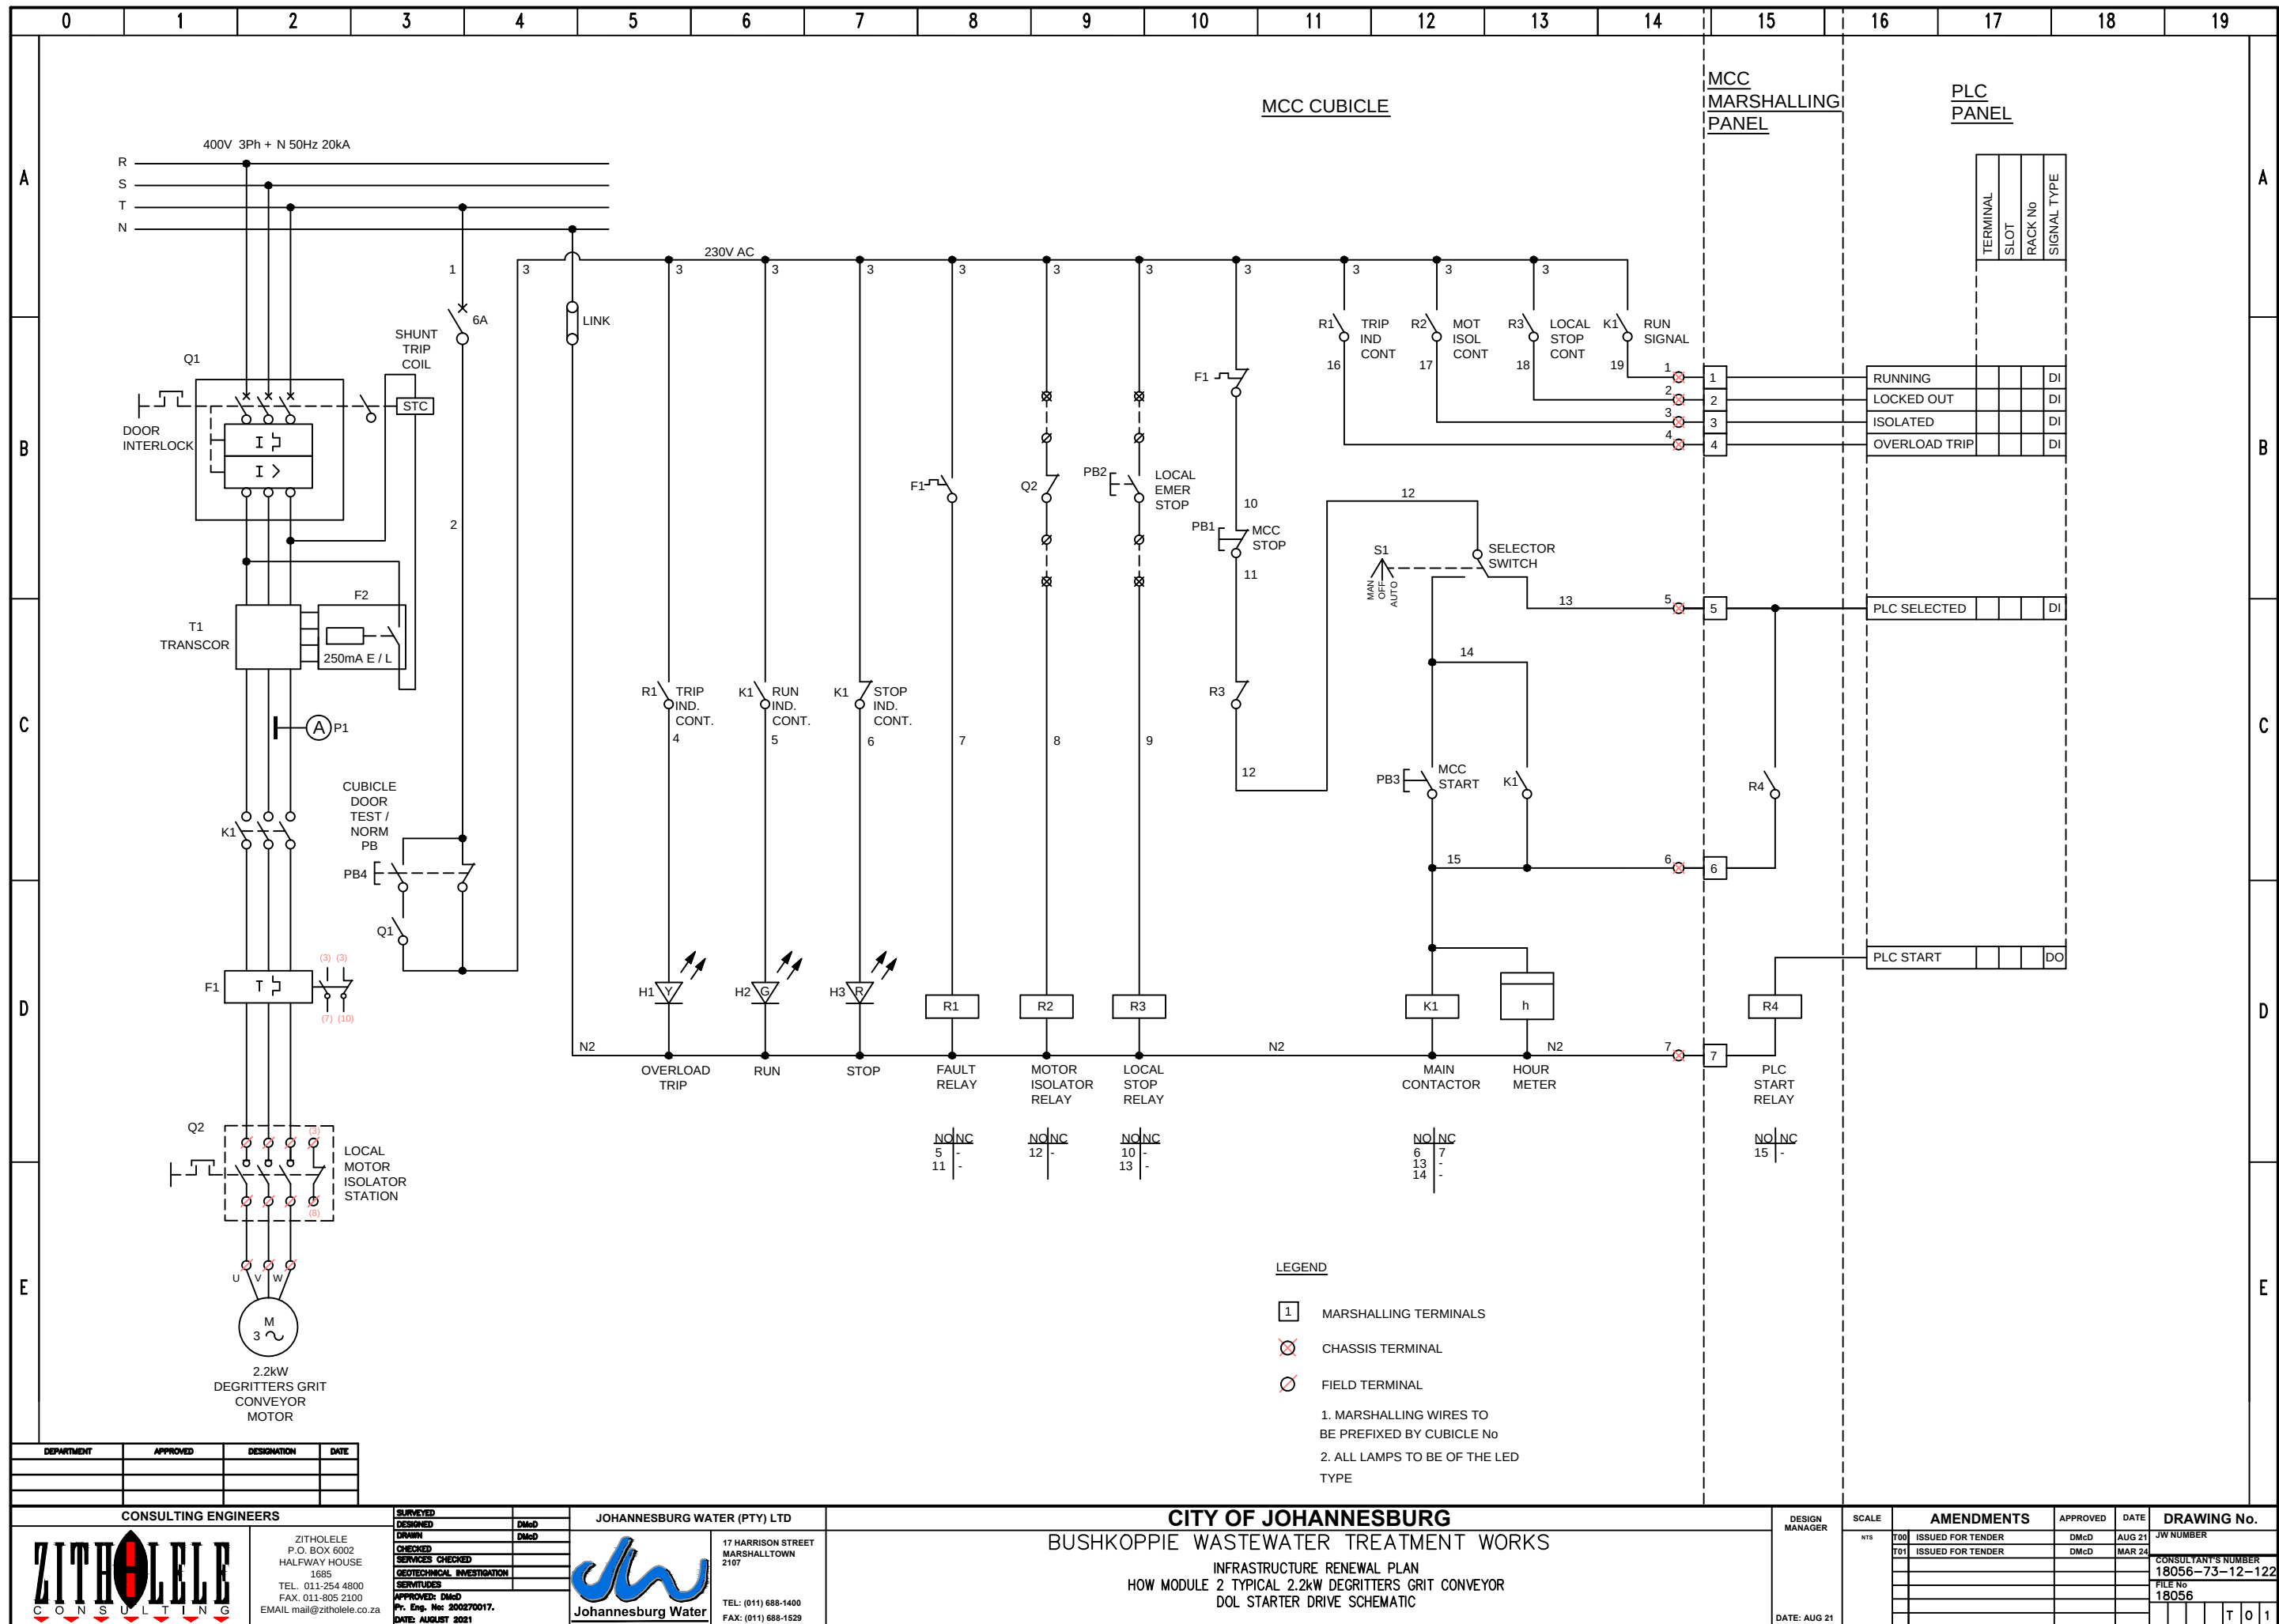


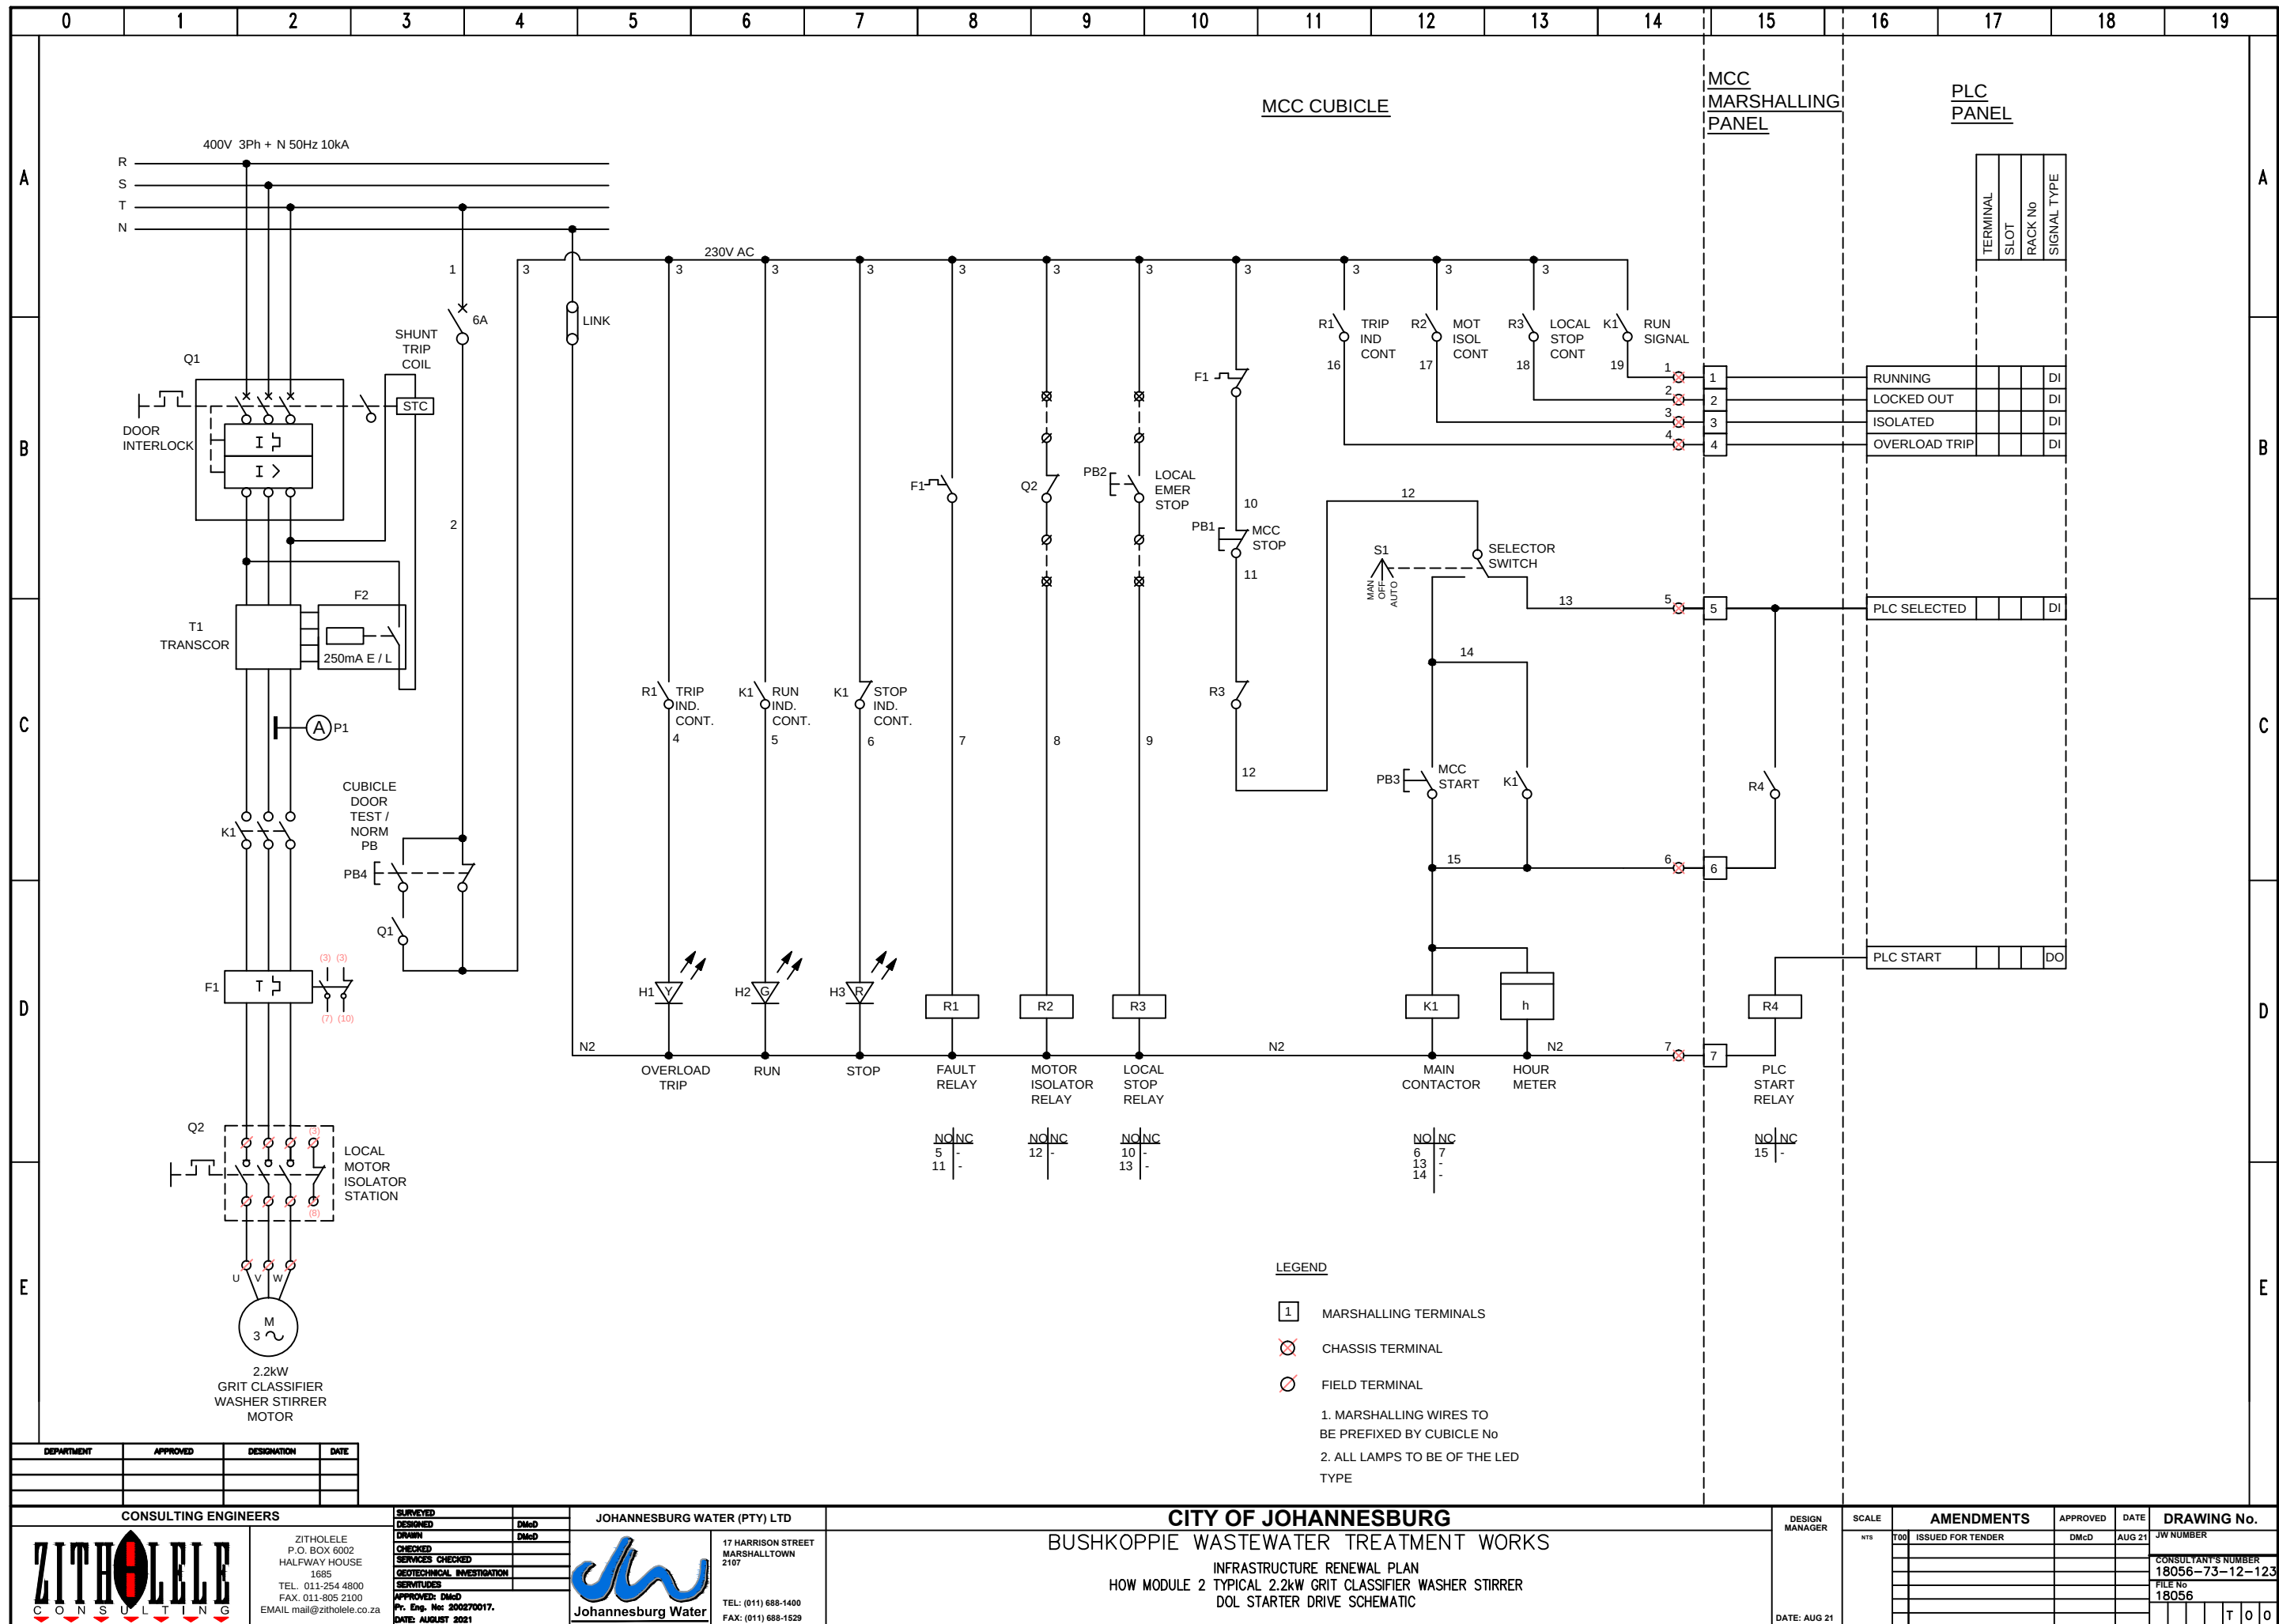

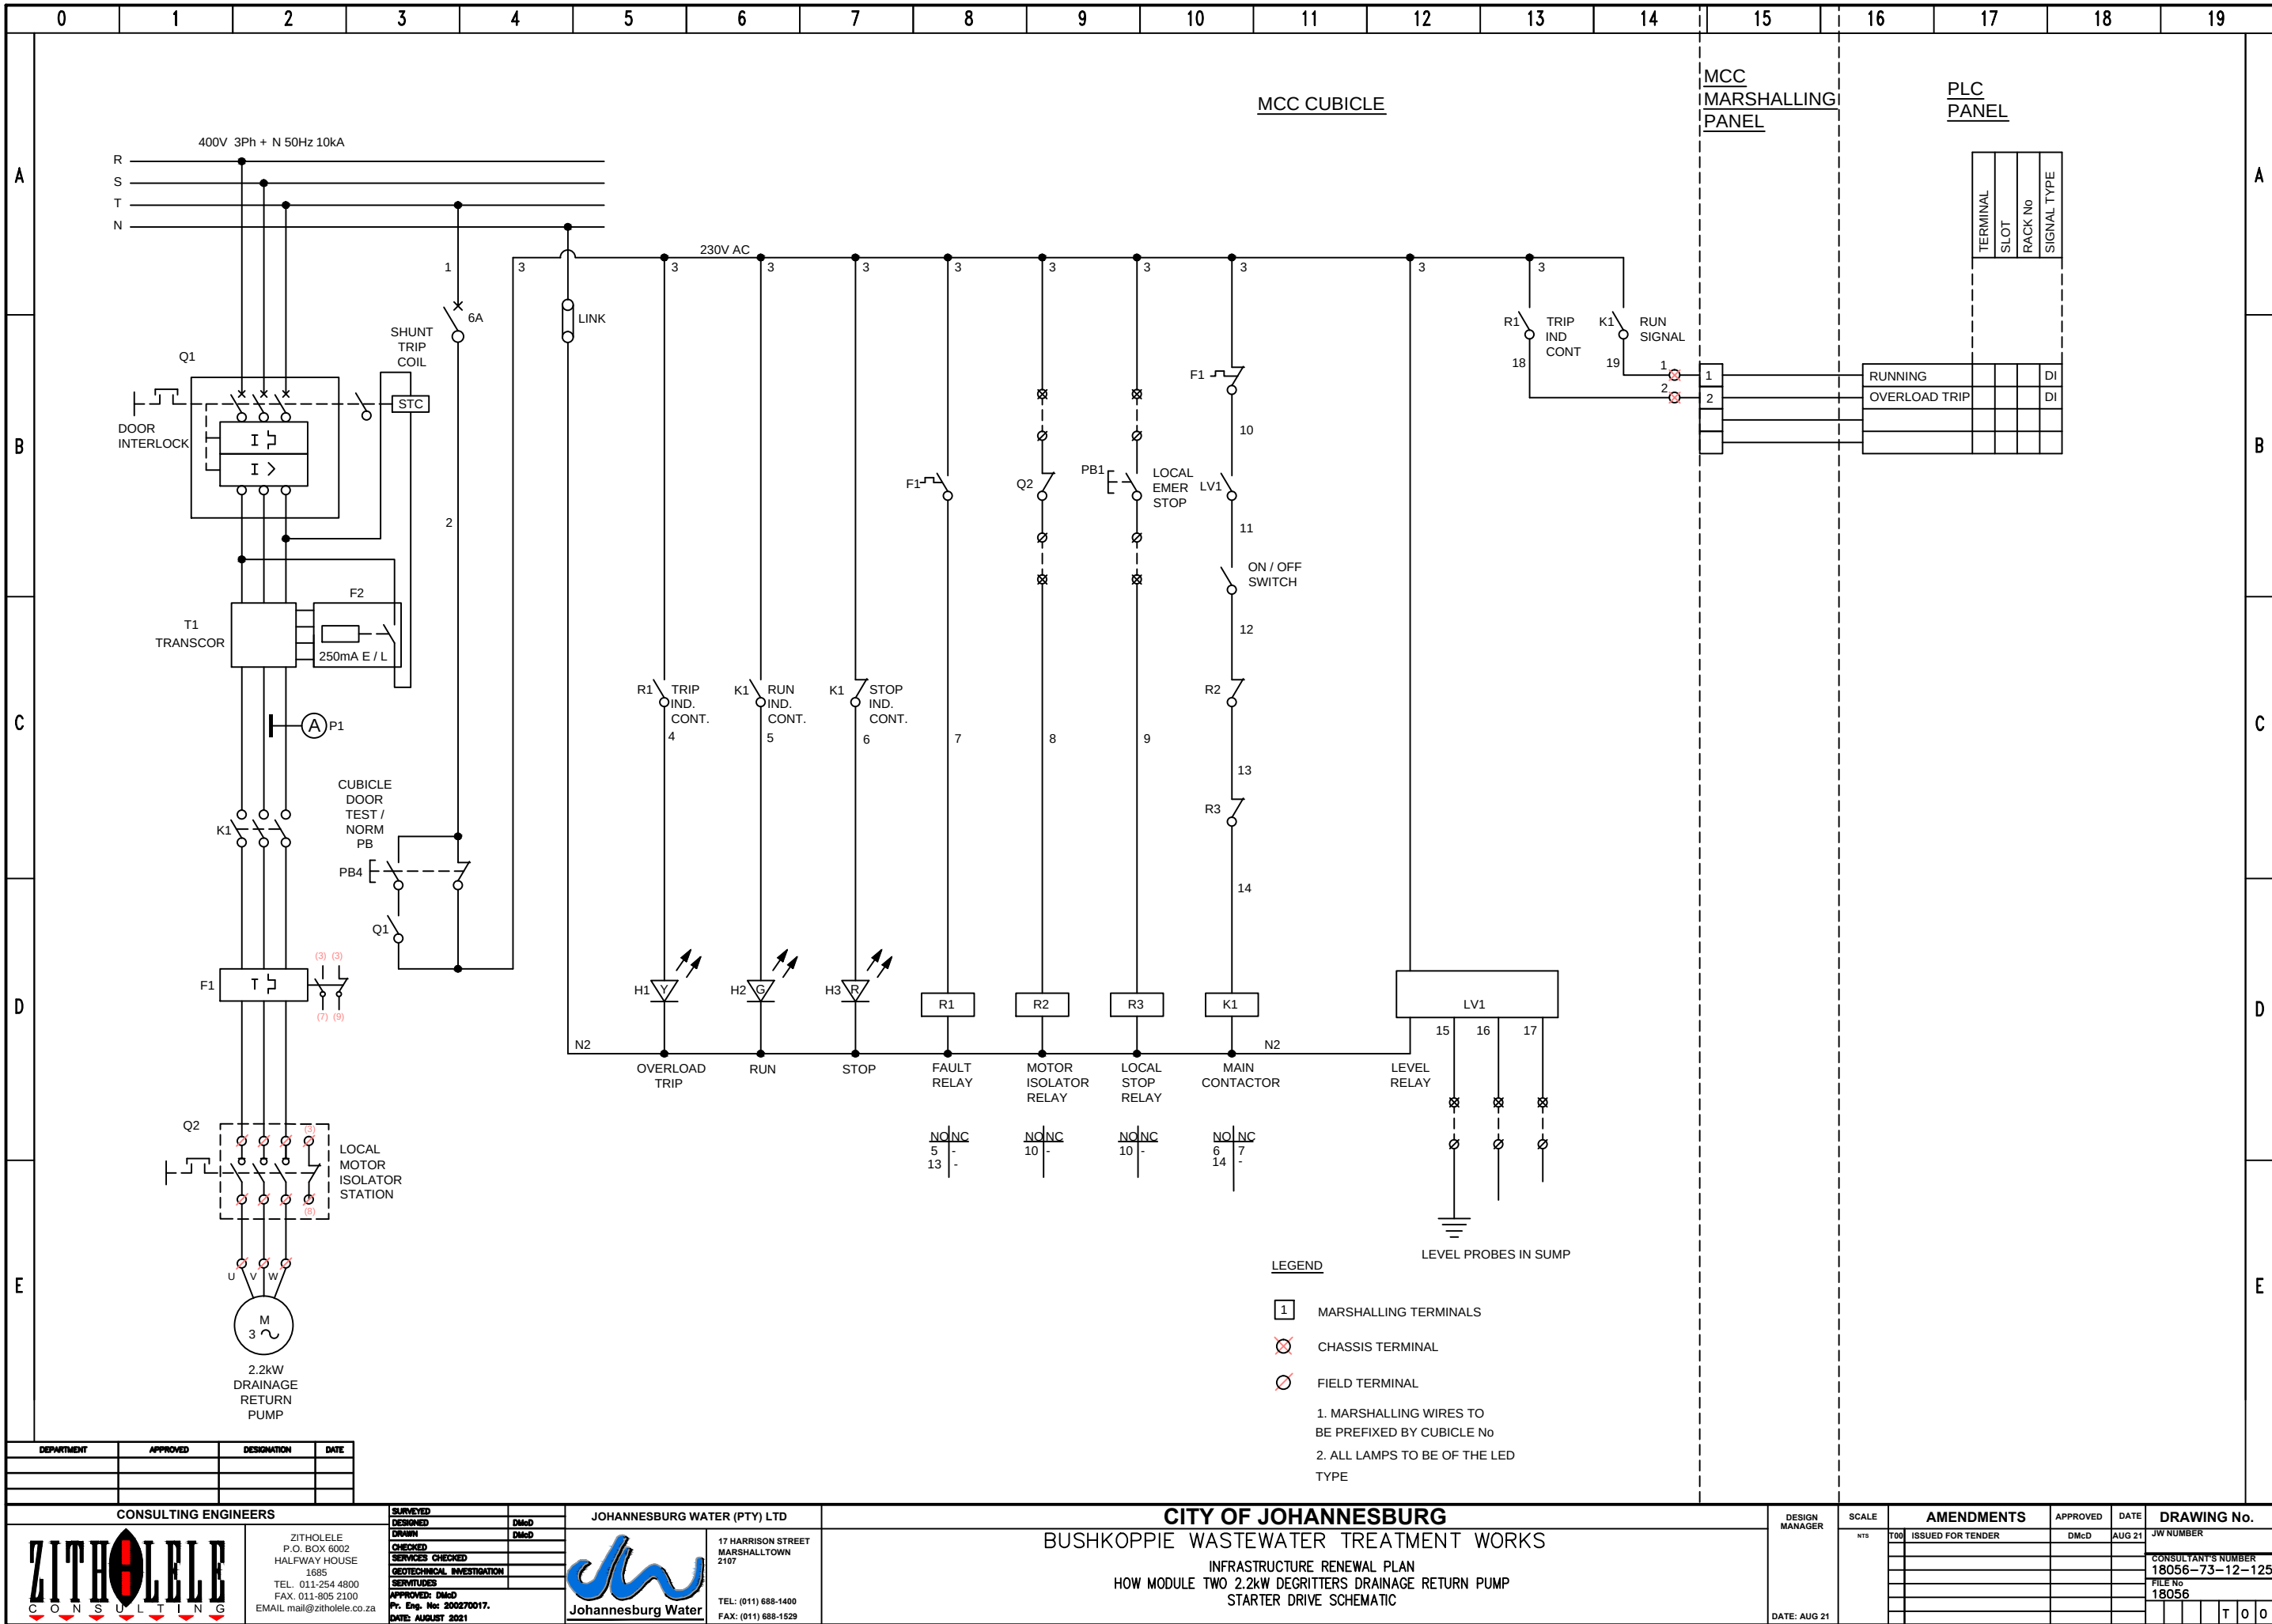

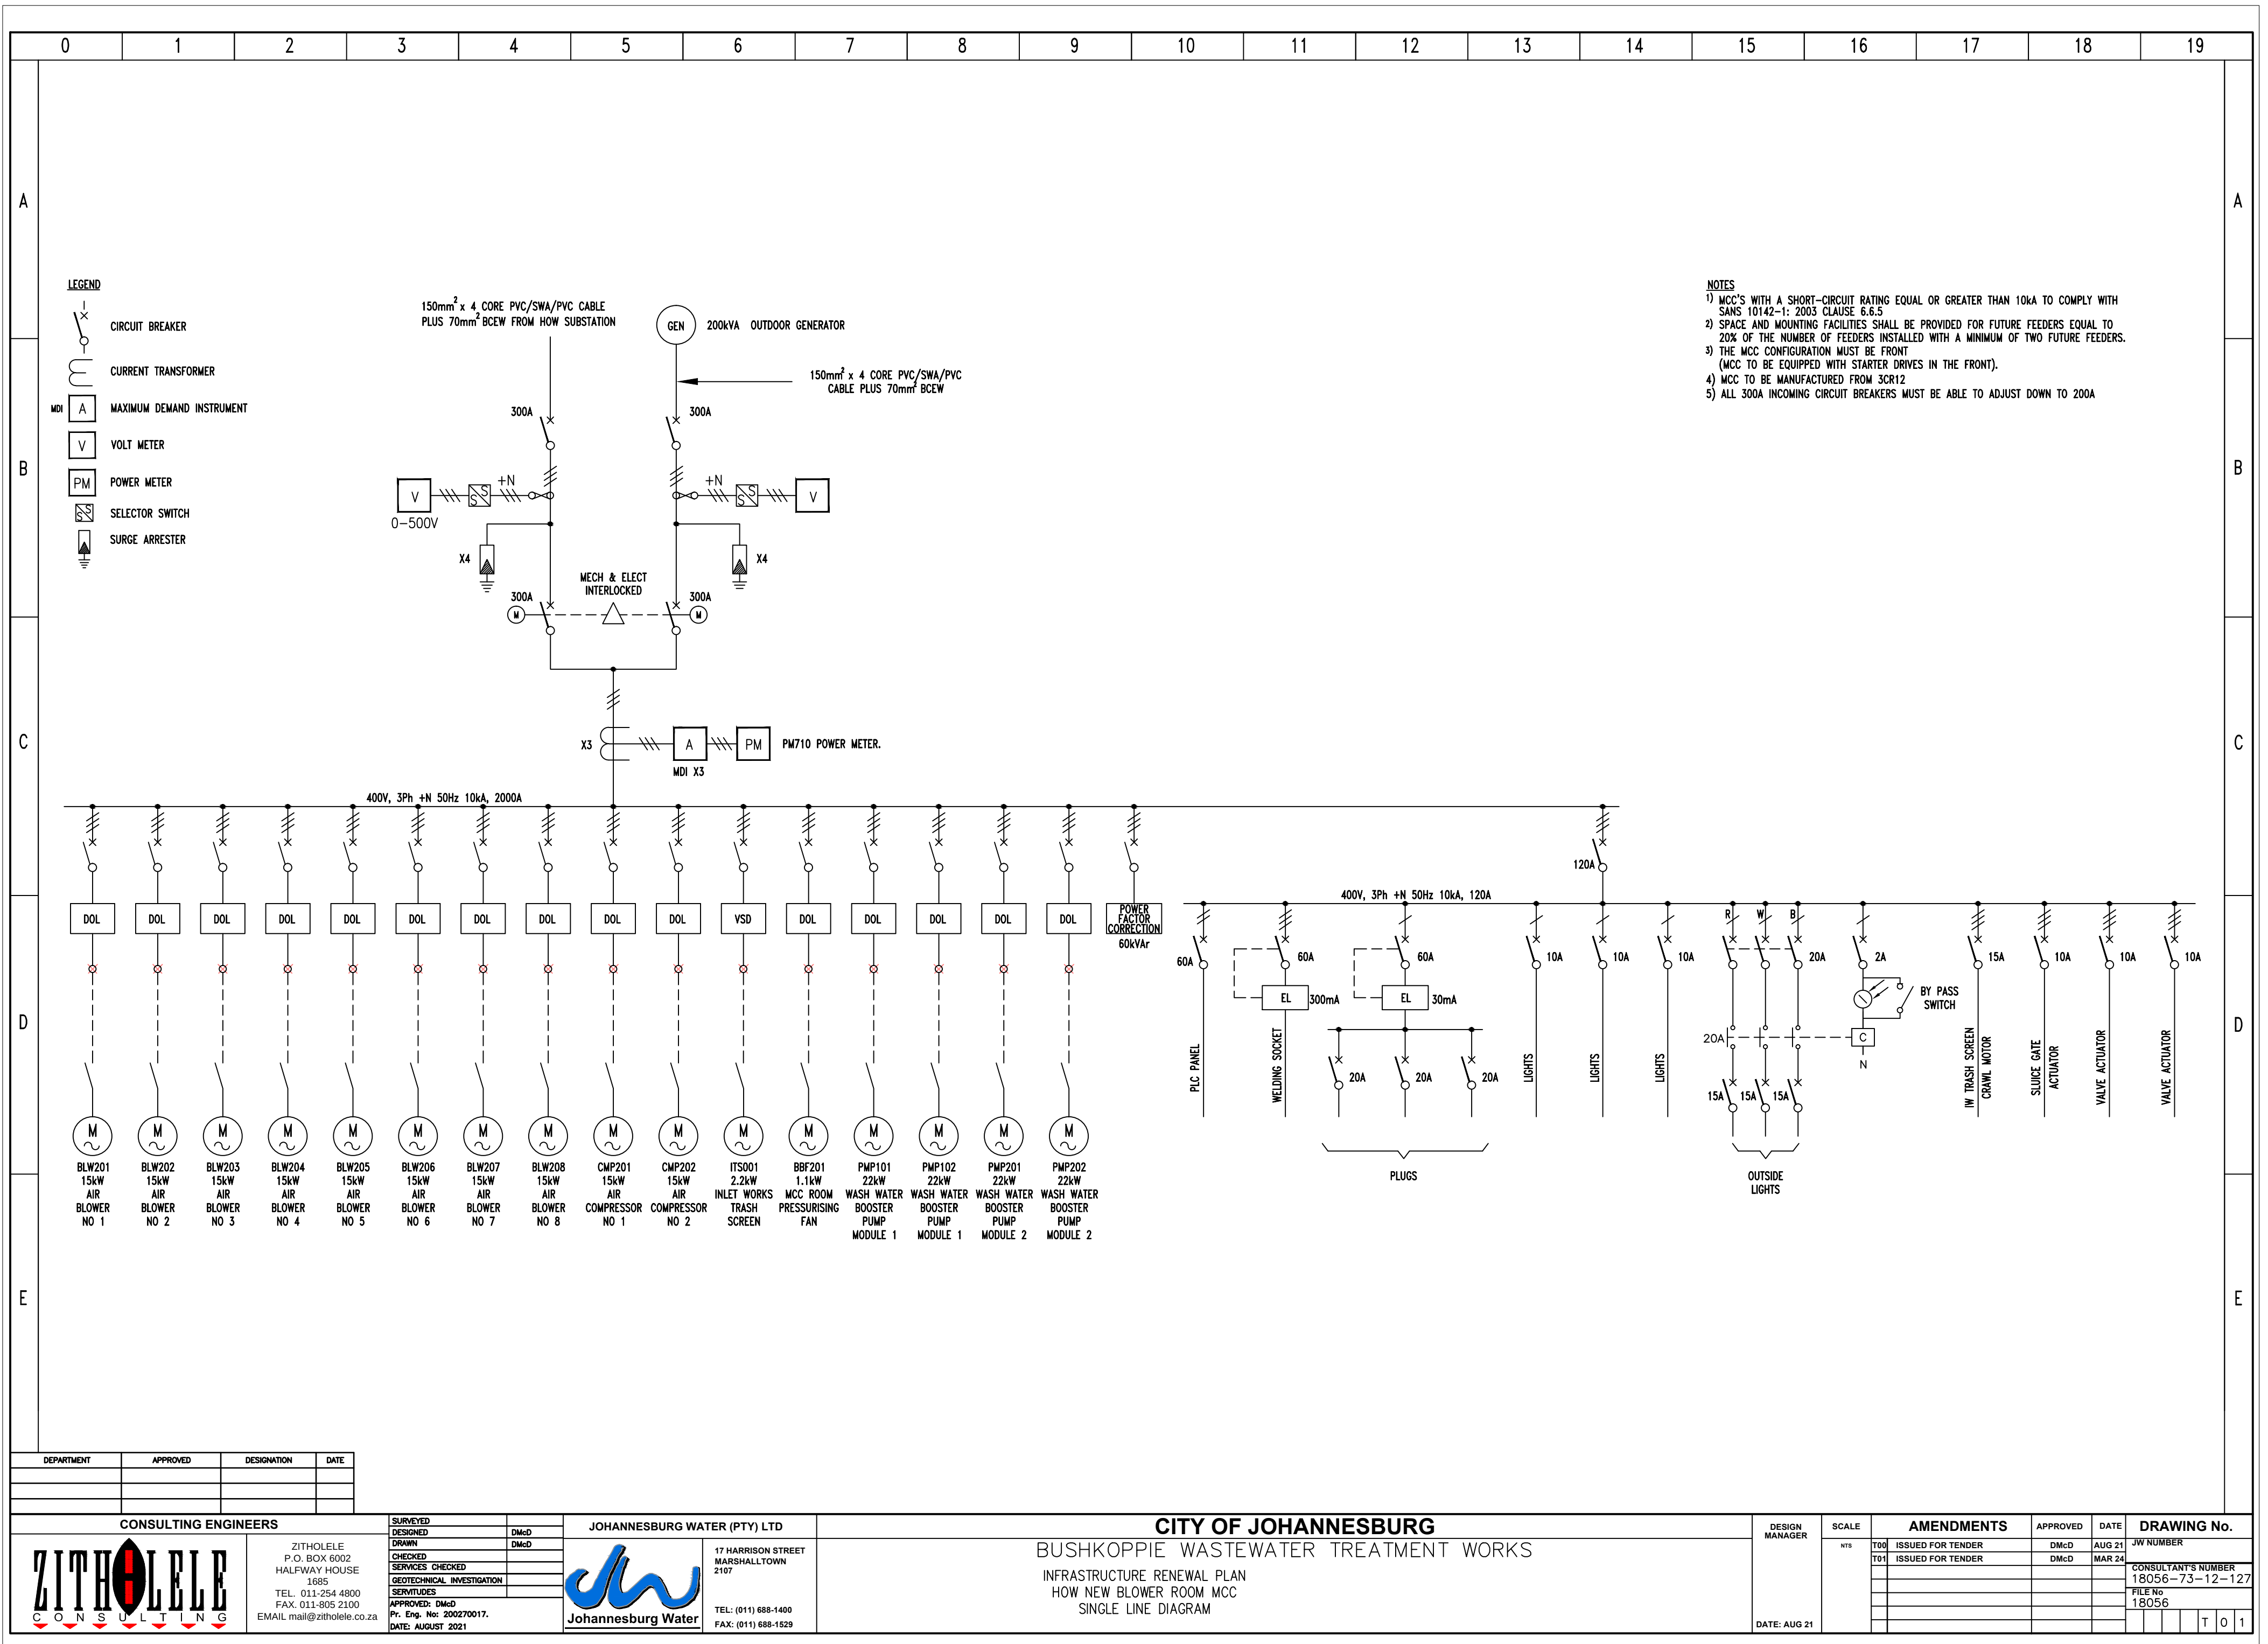


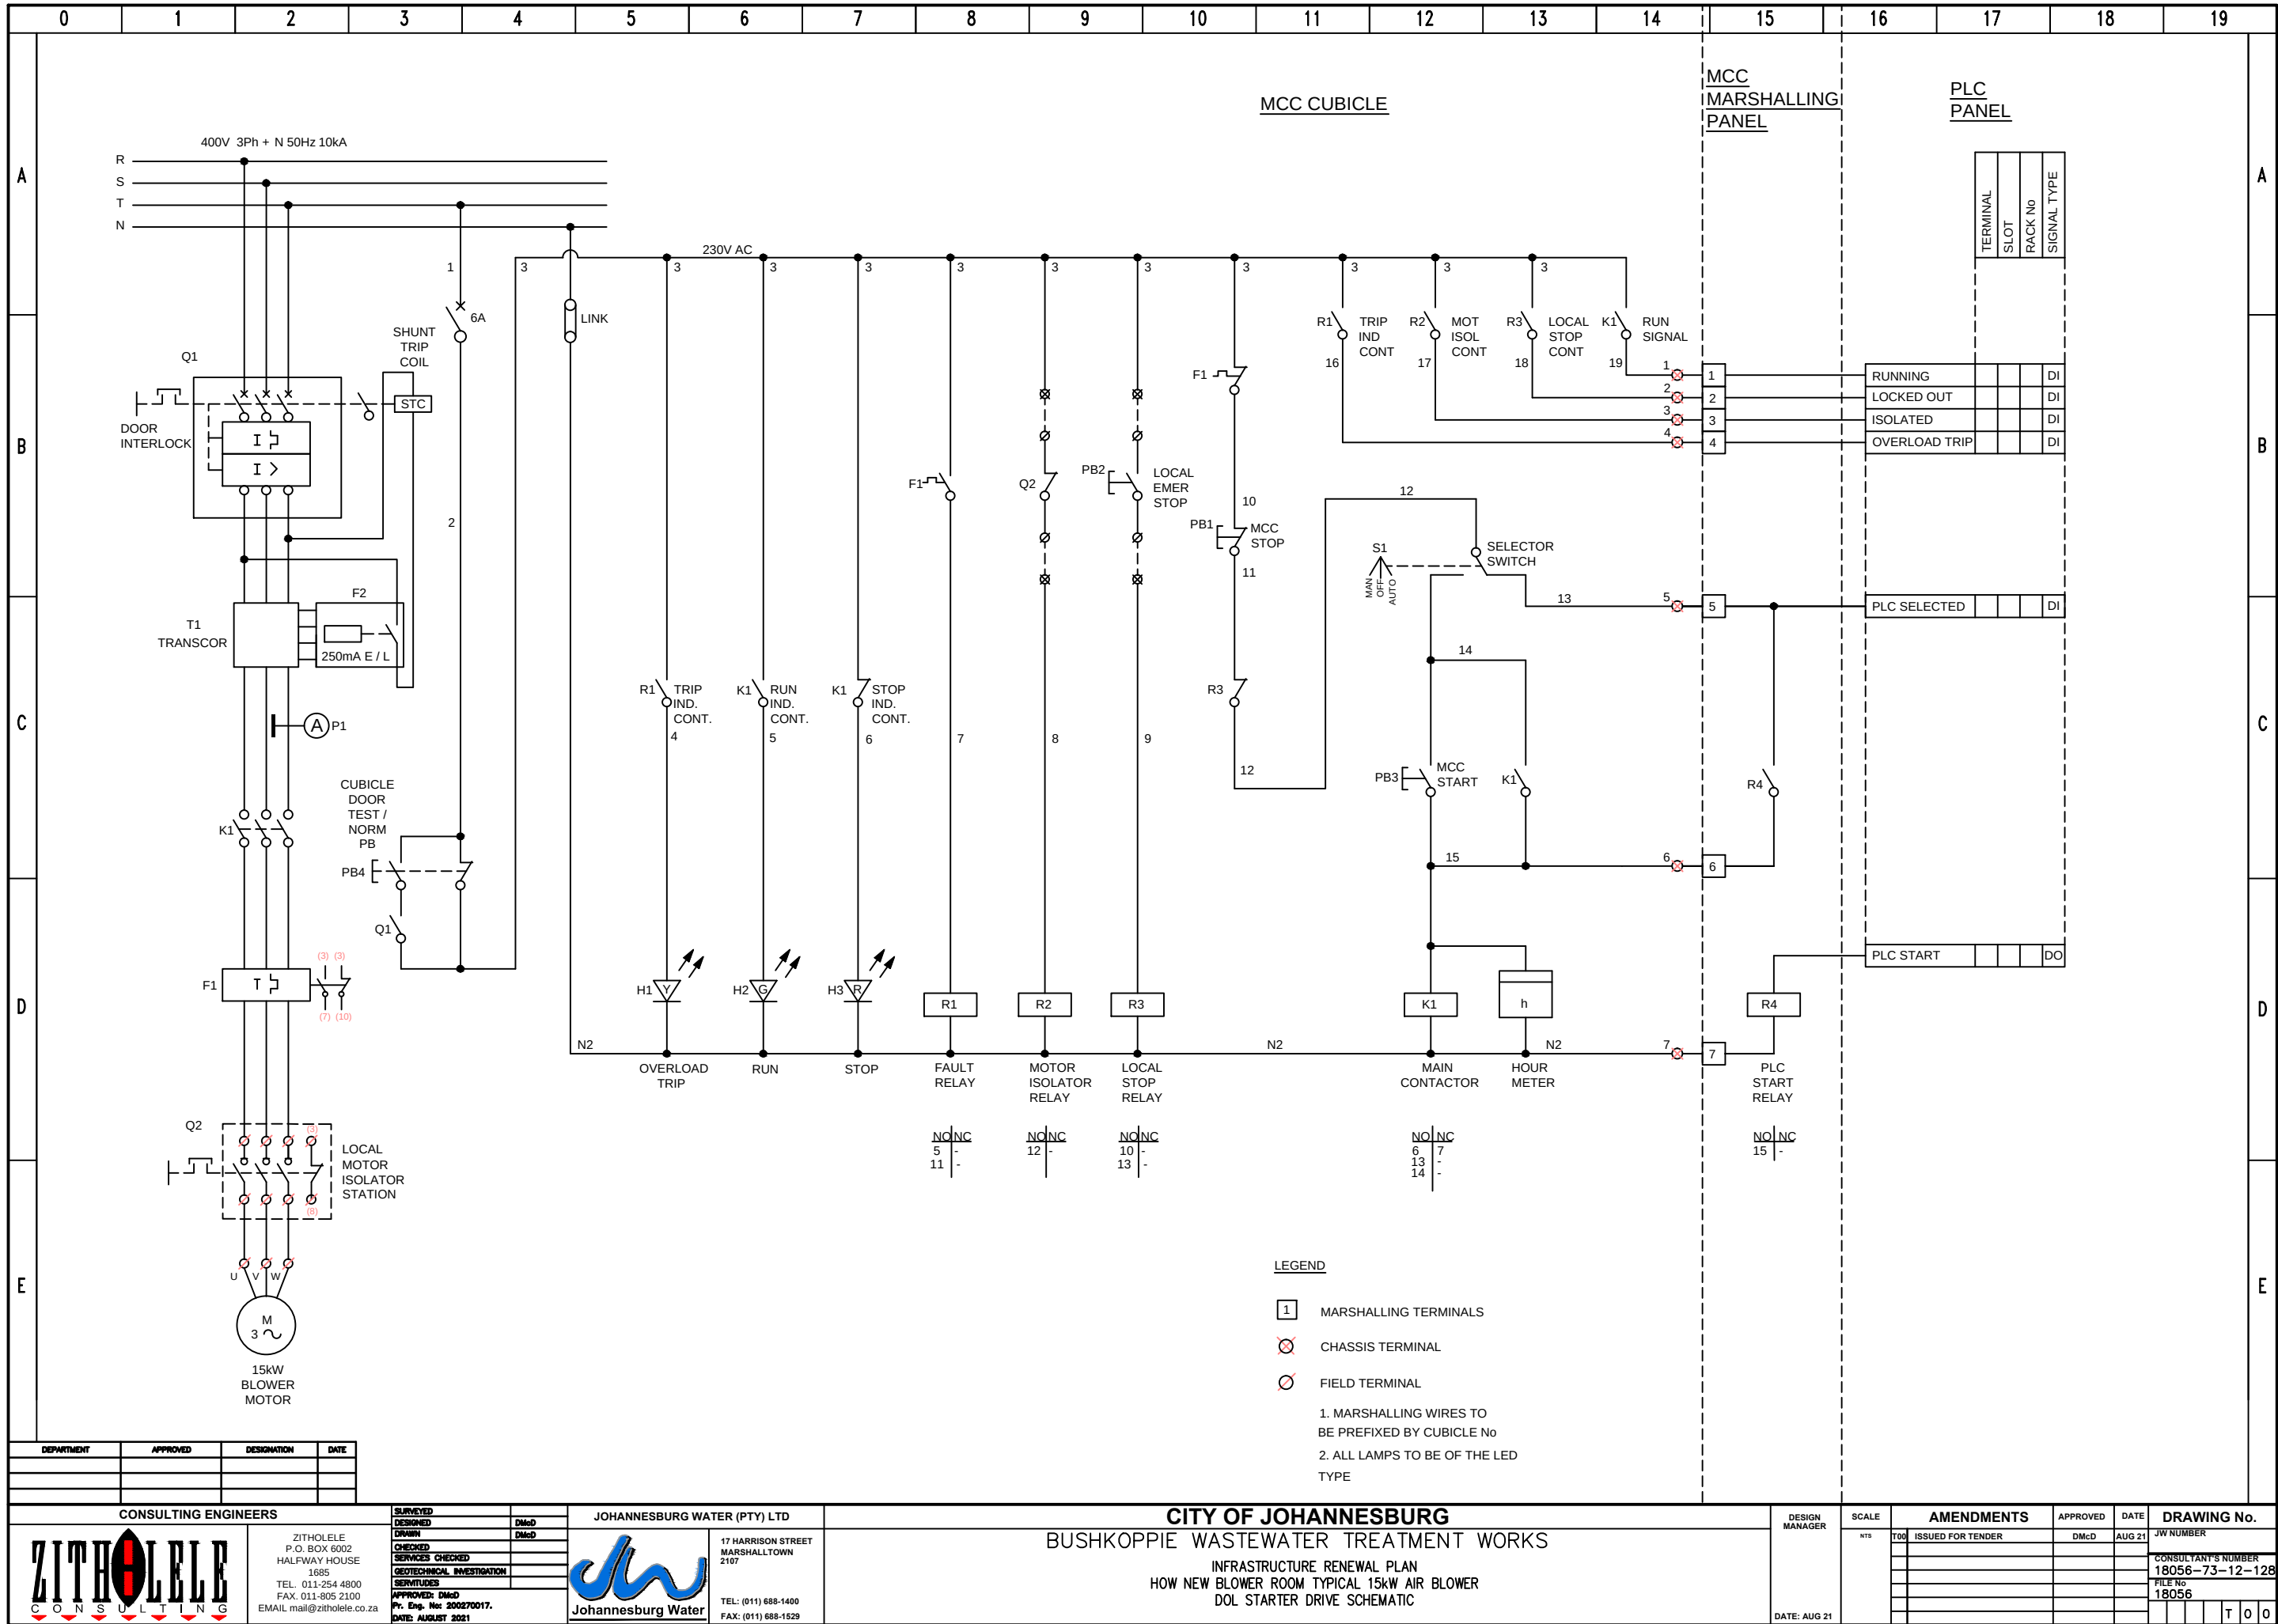


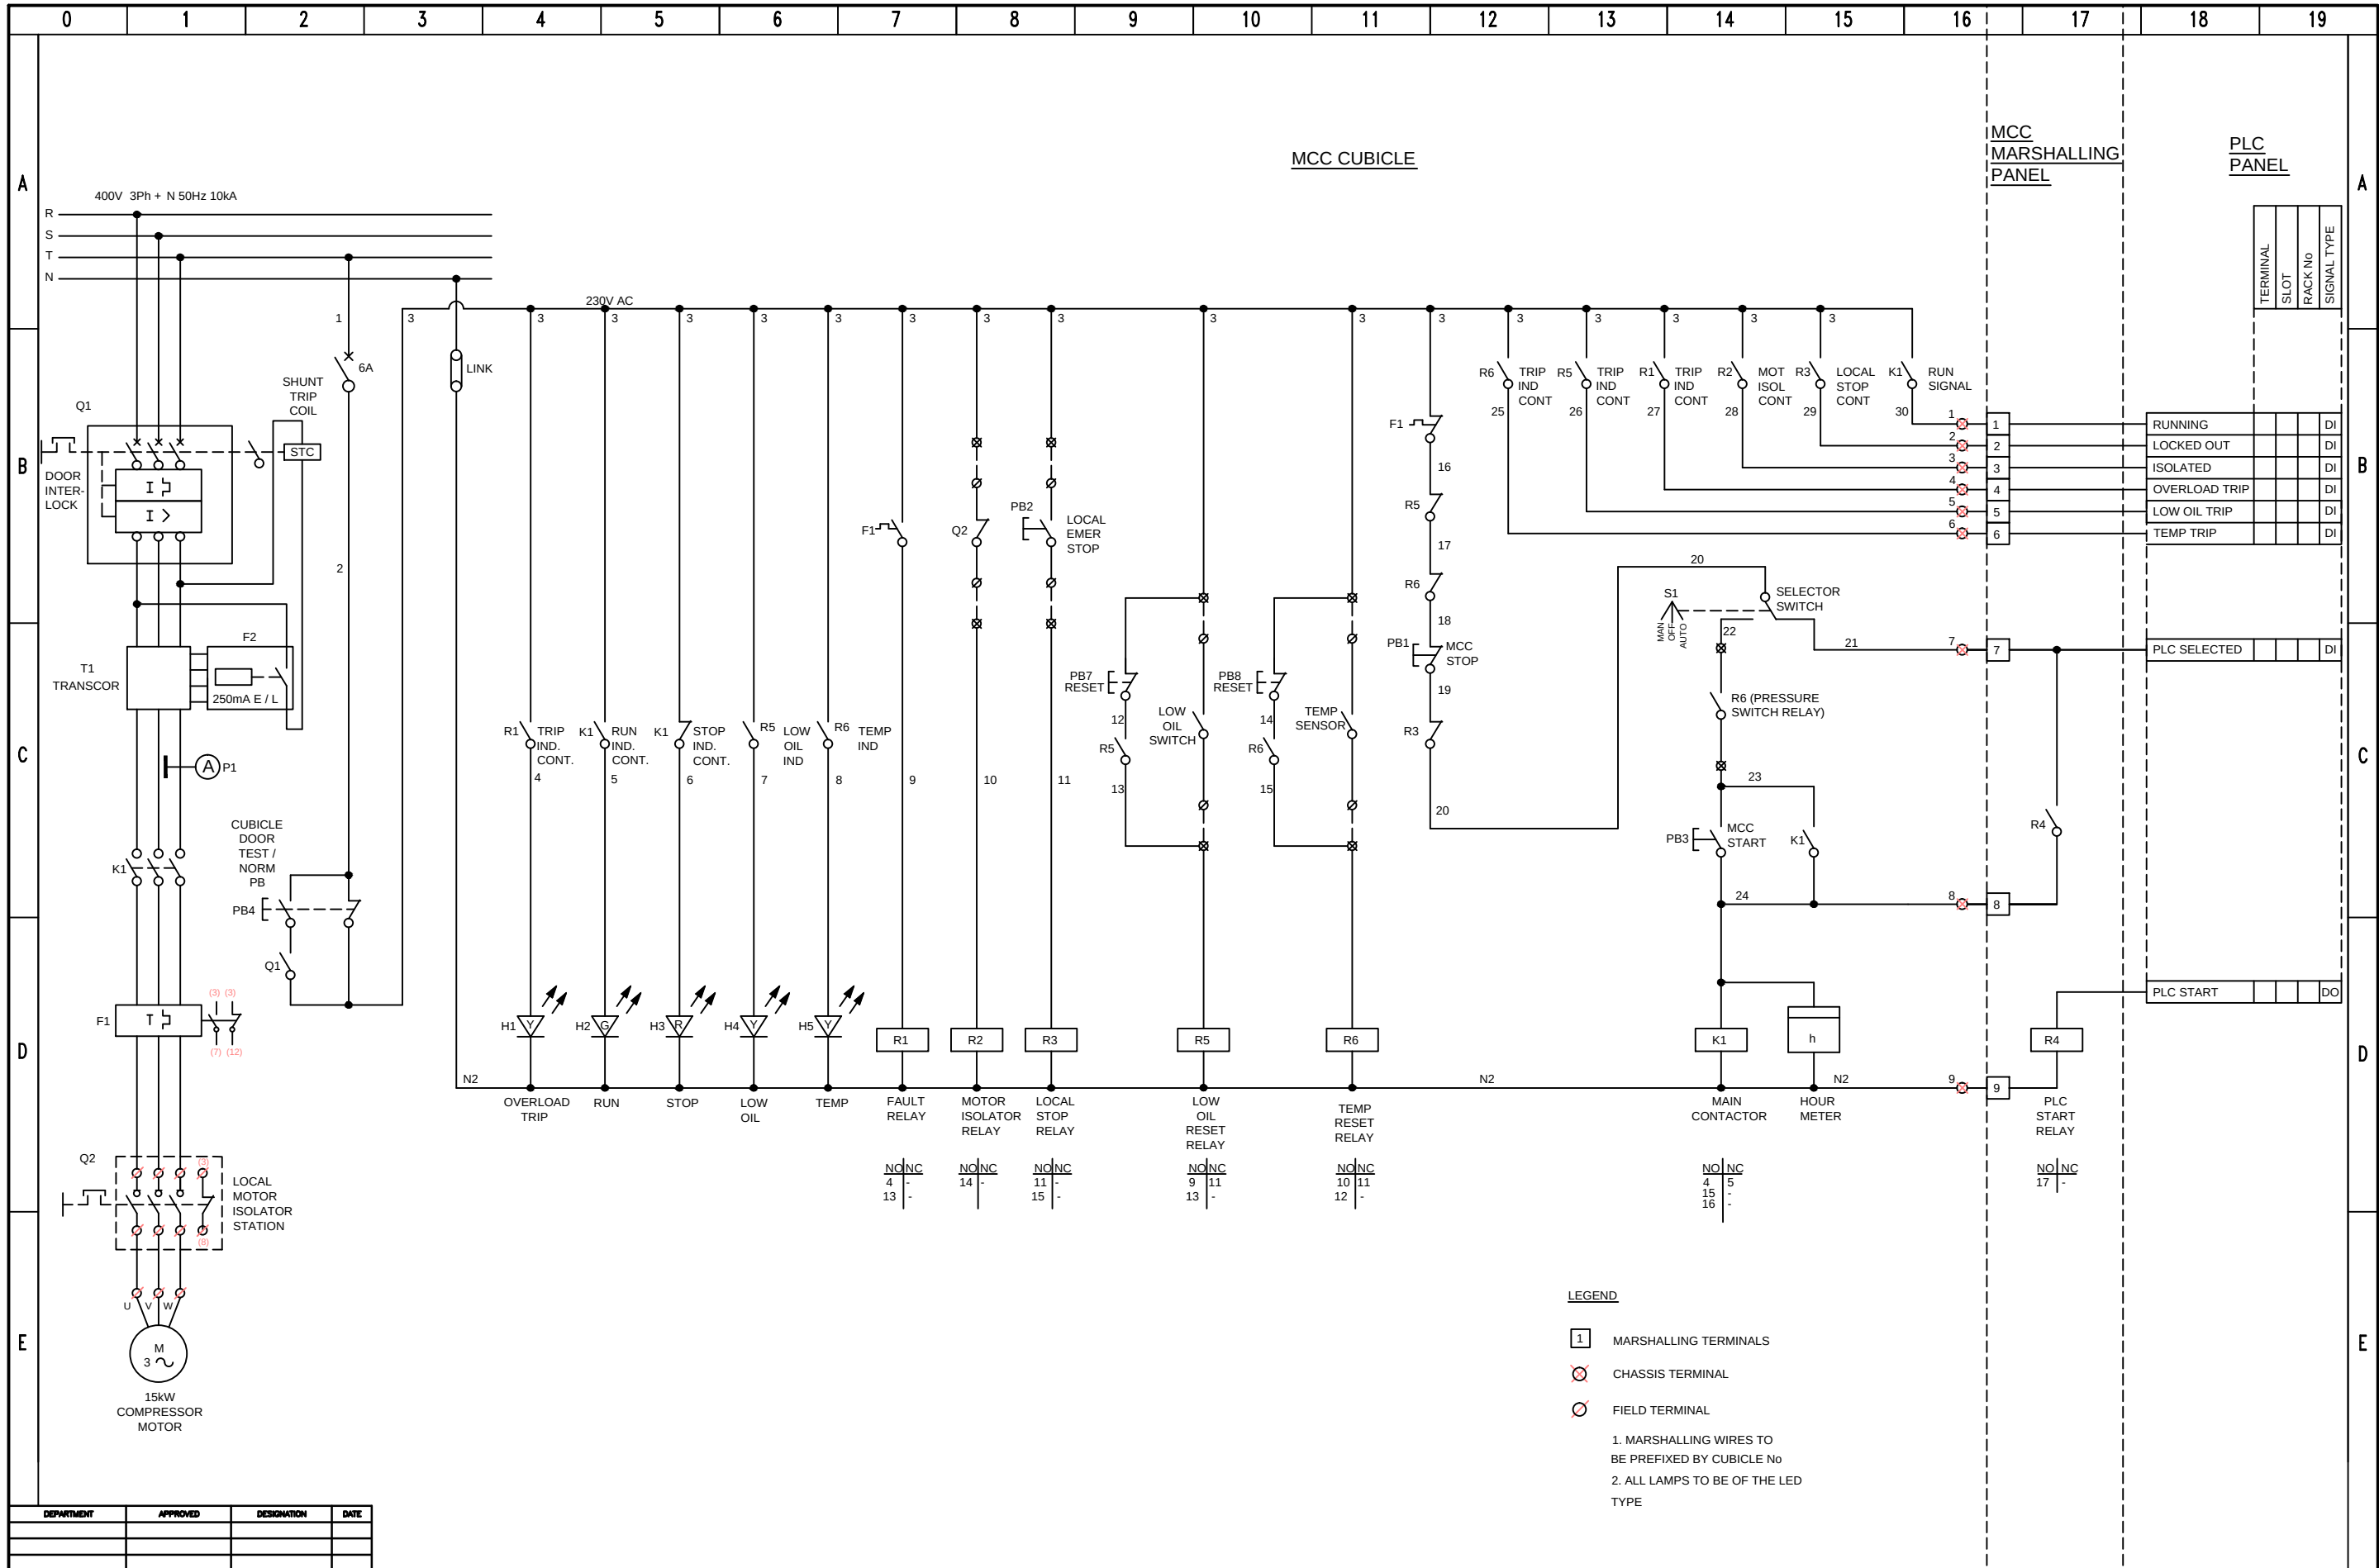



DEPARTMENT	APPROVED	DESIGNATION	DATE


CONSULTING ENGINEERS ZITHOLELE P.O. BOX 6002 HALFWAY HOUSE 1685 TEL. 011-254 4800 FAX. 011-805 2100 EMAIL mail@zitholele.co.za		SURVEYED DESIGNED DRAWN CHECKED SERVICES CHECKED GEOTECHNICAL INVESTIGATION SERVICES APPROVED: Dmcd P. Eng. No: 200270017. DATE: AUGUST 2021	JOHANNESBURG WATER (PTY) LTD 17 HARRISON STREET MARSHALLTOWN 2107 TEL: (011) 688-1400 FAX: (011) 688-1529	CITY OF JOHANNESBURG BUSHKOPPIE WASTEWATER TREATMENT WORKS INFRASTRUCTURE RENEWAL PLAN HOW NEW BLOWER ROOM TYPICAL 15kW COMPRESSOR DOL STARTER DRIVE SCHEMATIC		DESIGN MANAGER DATE: AUG 21	SCALE NTS	AMENDMENTS <table border="1"> <tr> <th>NO</th><th>ISSUED FOR TENDER</th><th>DATE</th></tr> <tr> <td>1</td><td></td><td></td></tr> <tr> <td>2</td><td></td><td></td></tr> <tr> <td>3</td><td></td><td></td></tr> <tr> <td>4</td><td></td><td></td></tr> <tr> <td>5</td><td></td><td></td></tr> <tr> <td>6</td><td></td><td></td></tr> <tr> <td>7</td><td></td><td></td></tr> <tr> <td>8</td><td></td><td></td></tr> <tr> <td>9</td><td></td><td></td></tr> </table>	NO	ISSUED FOR TENDER	DATE	1			2			3			4			5			6			7			8			9			APPROVED Dmcd DATE AUG 21	DRAWING No. JW NUMBER 18056-73-12-129 CONSULTANT'S NUMBER 18056 FILE No 18056
NO	ISSUED FOR TENDER	DATE																																						
1																																								
2																																								
3																																								
4																																								
5																																								
6																																								
7																																								
8																																								
9																																								

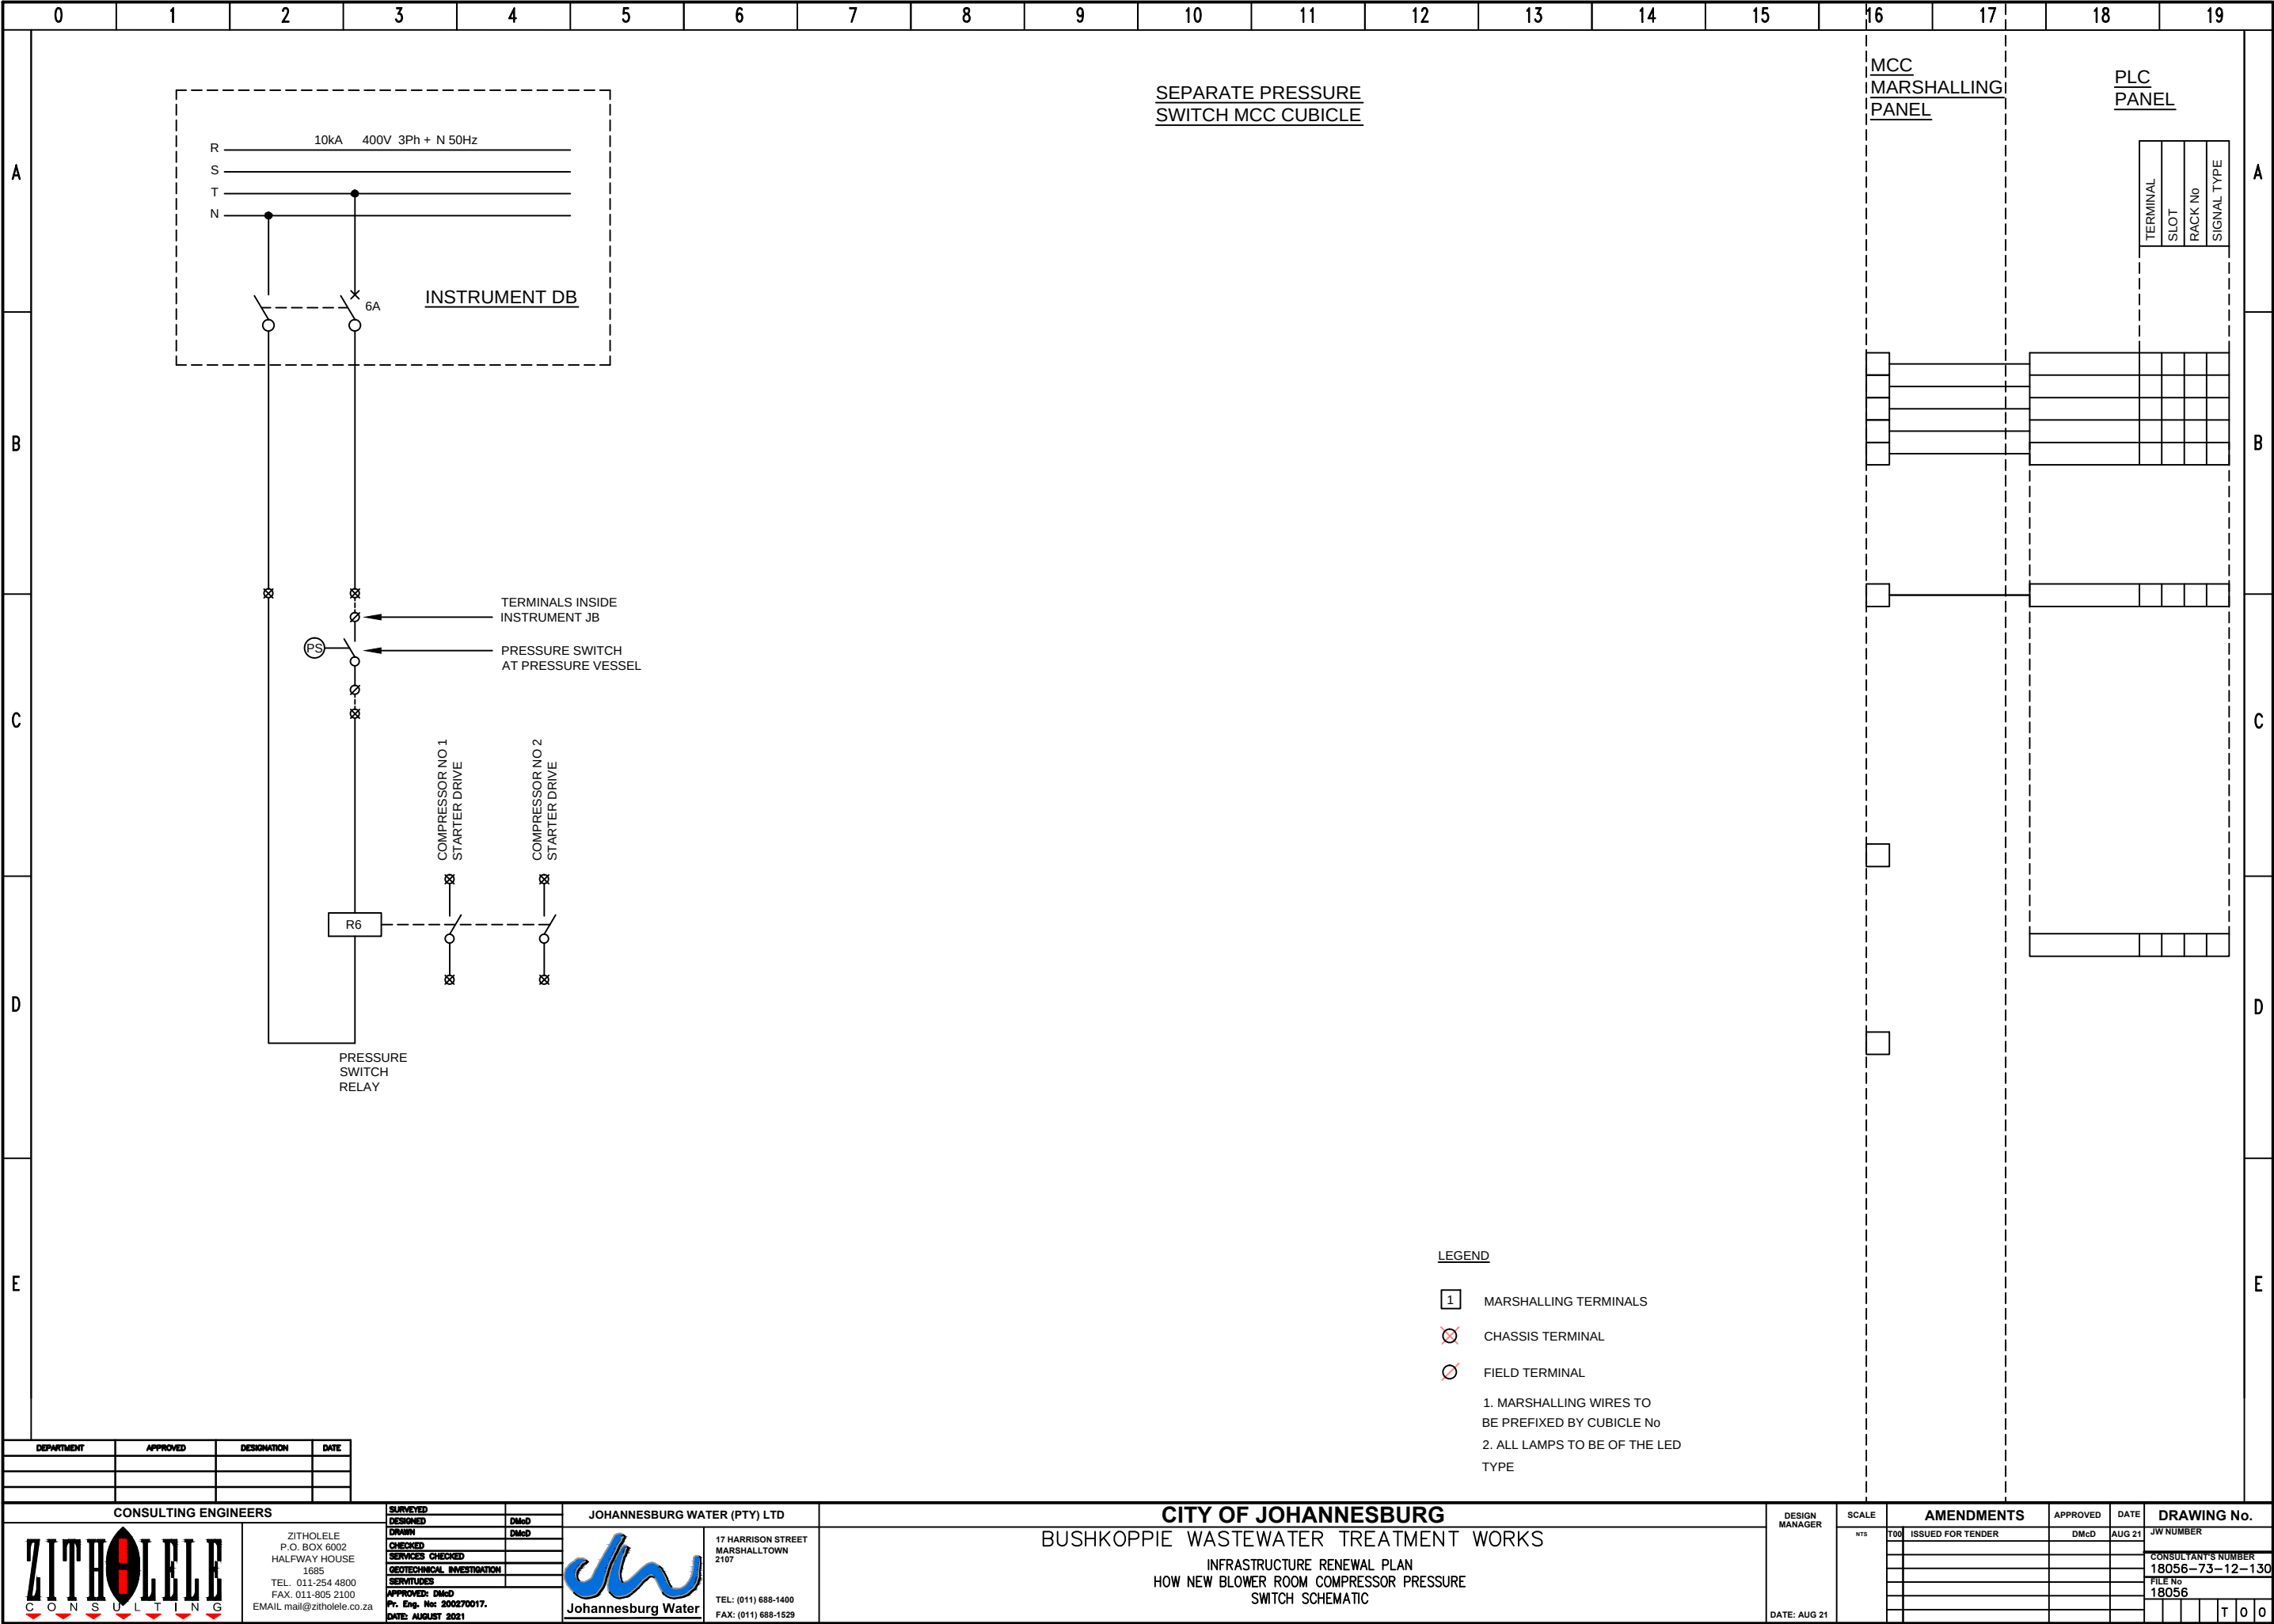


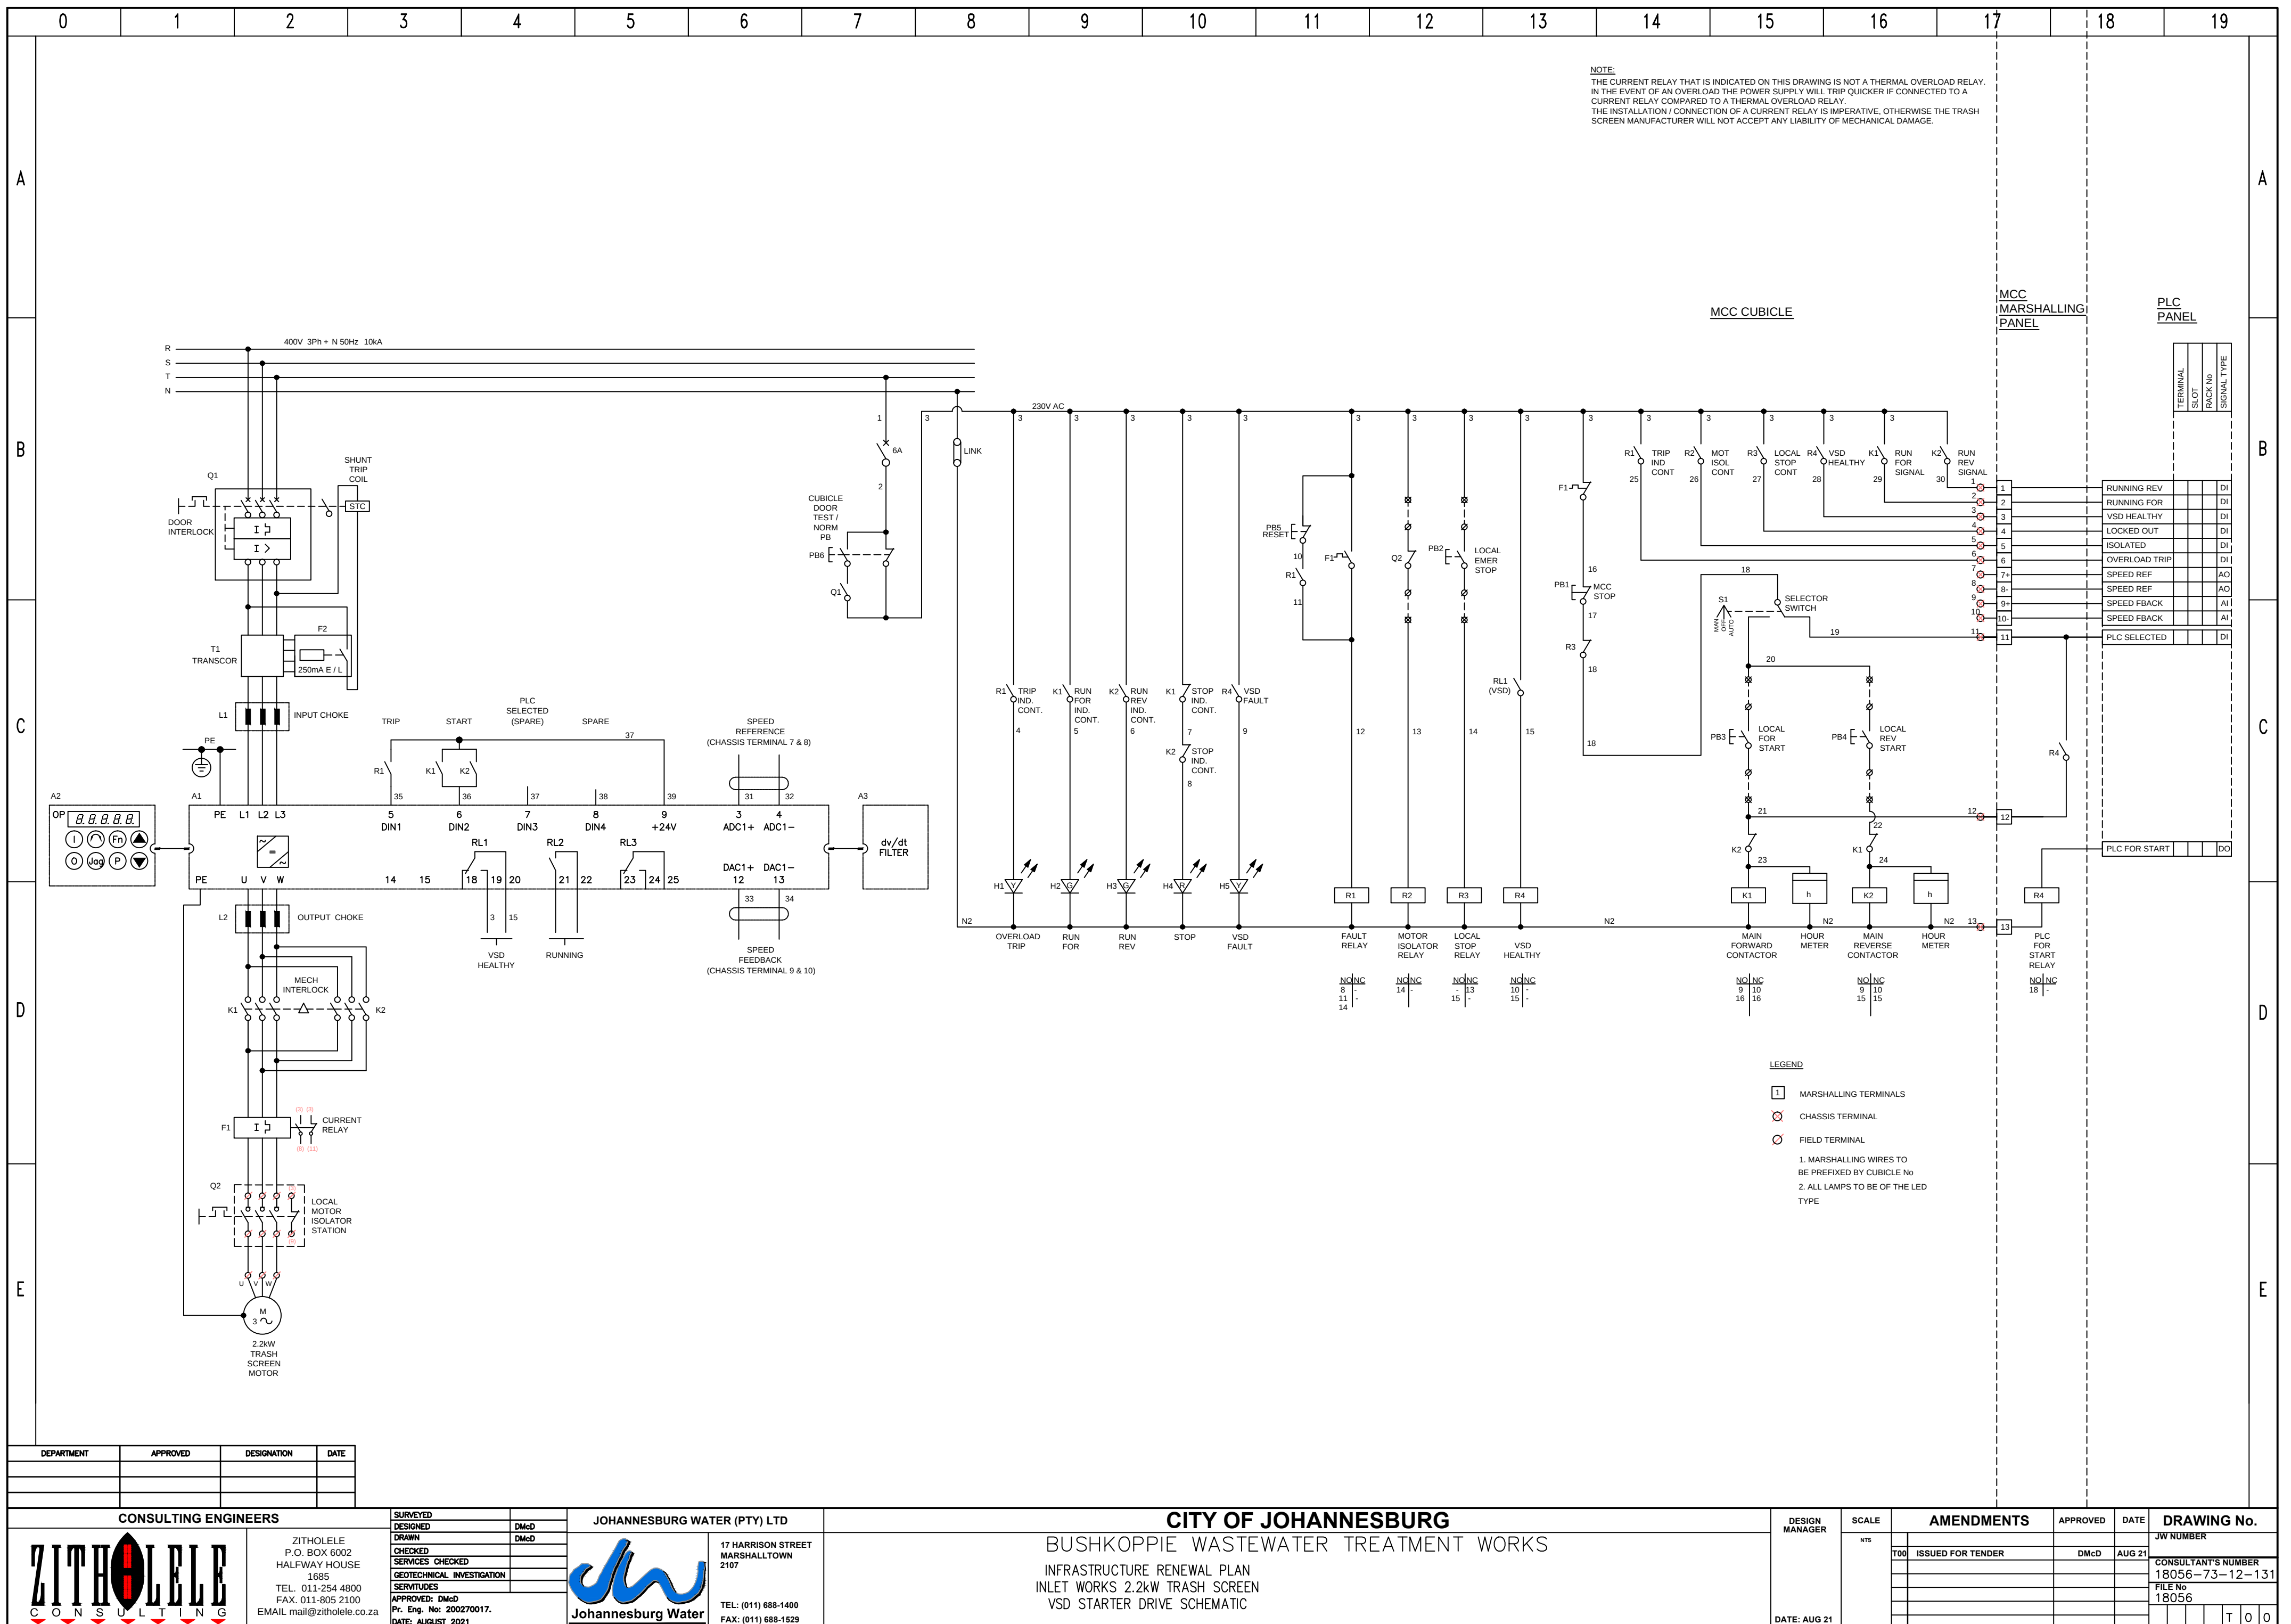


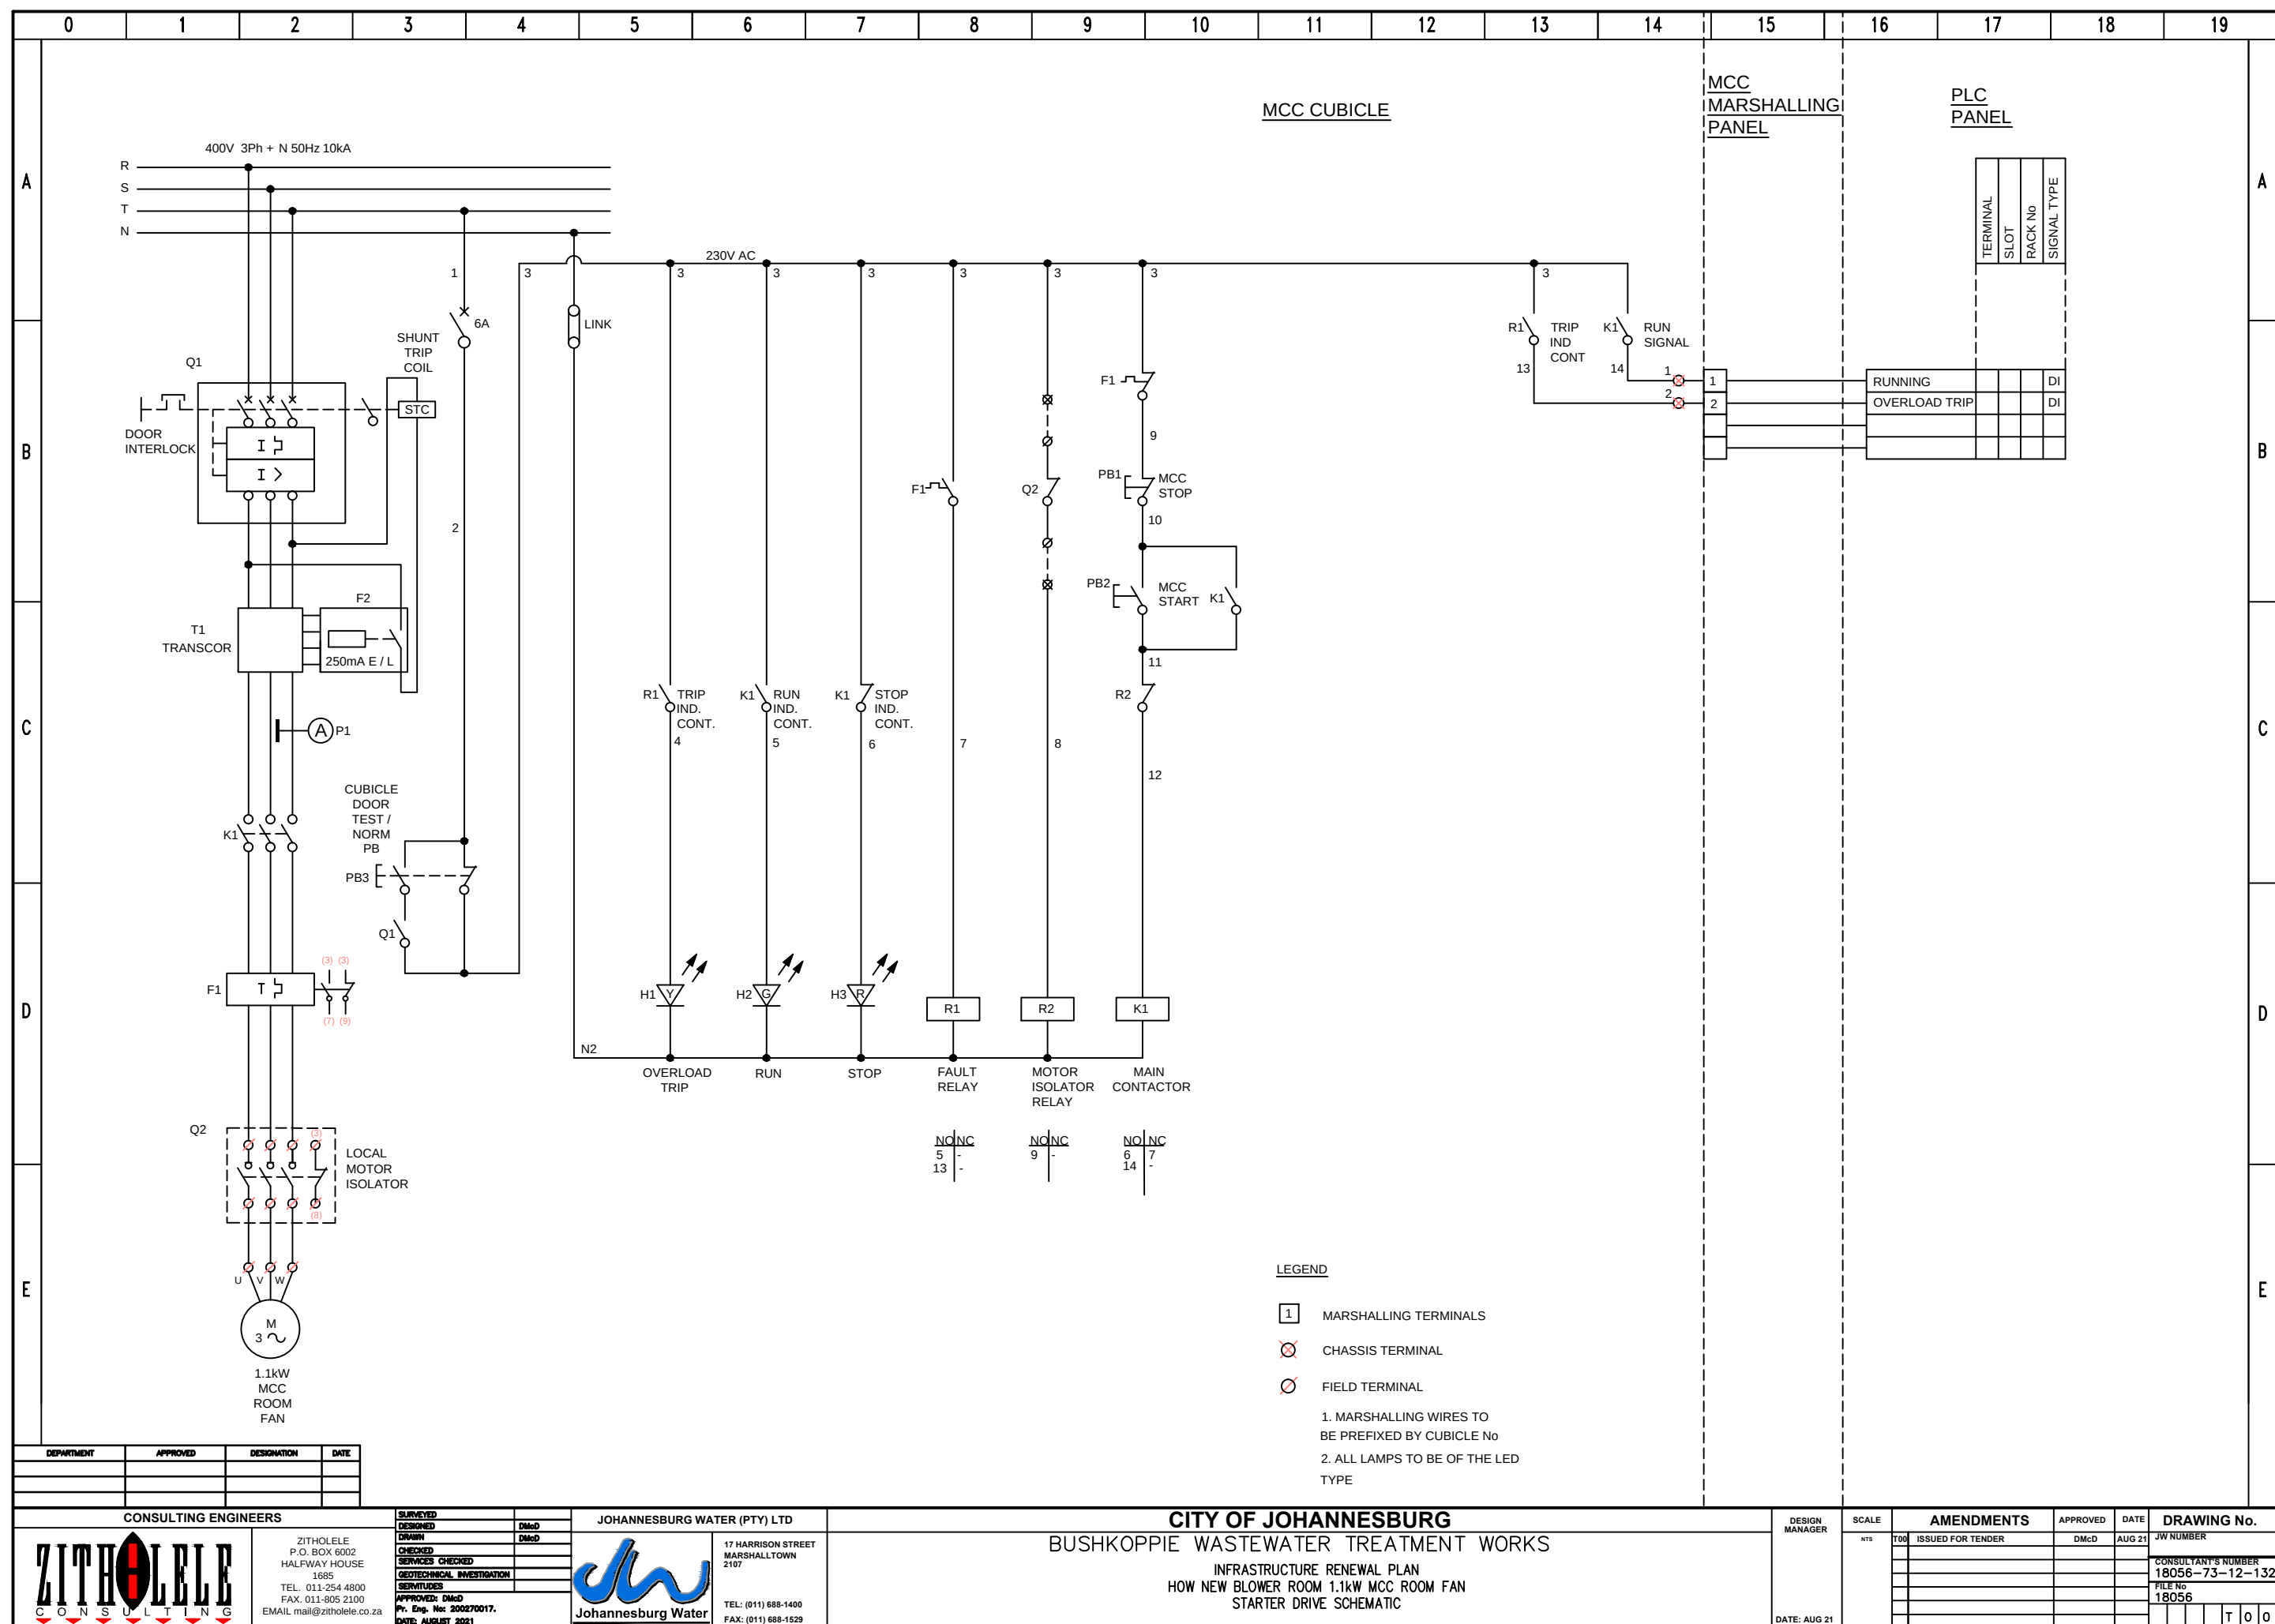


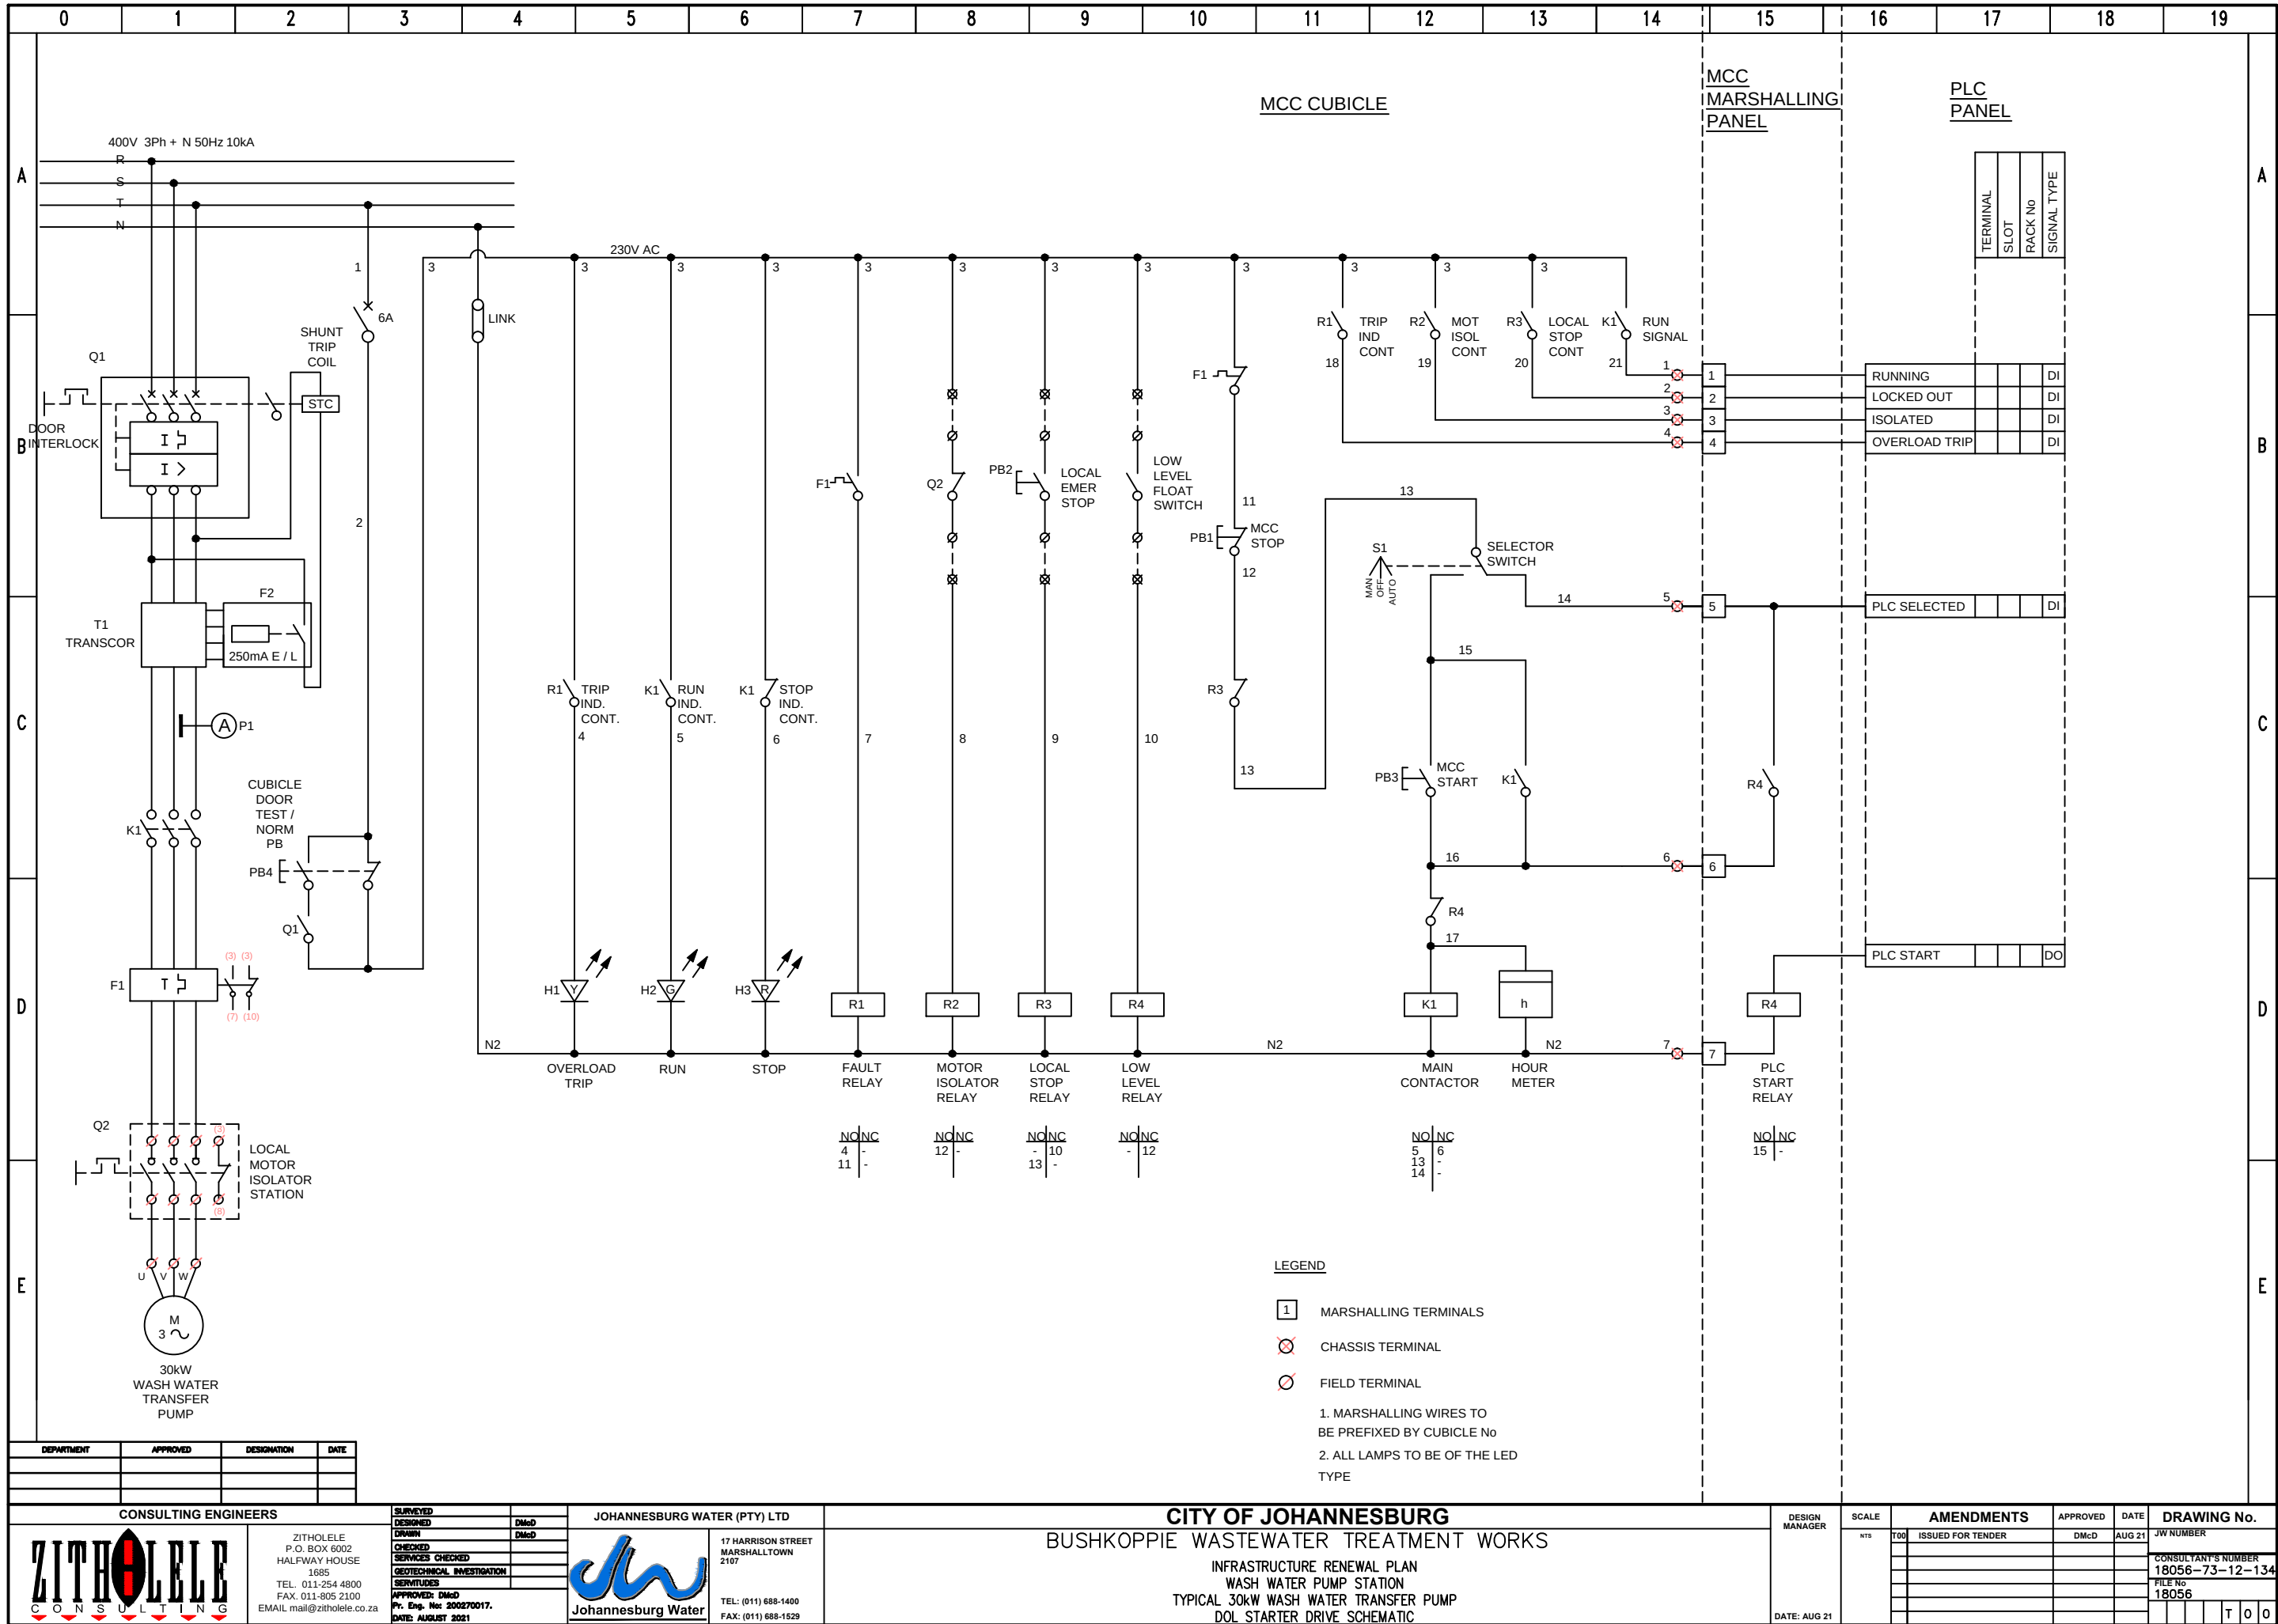


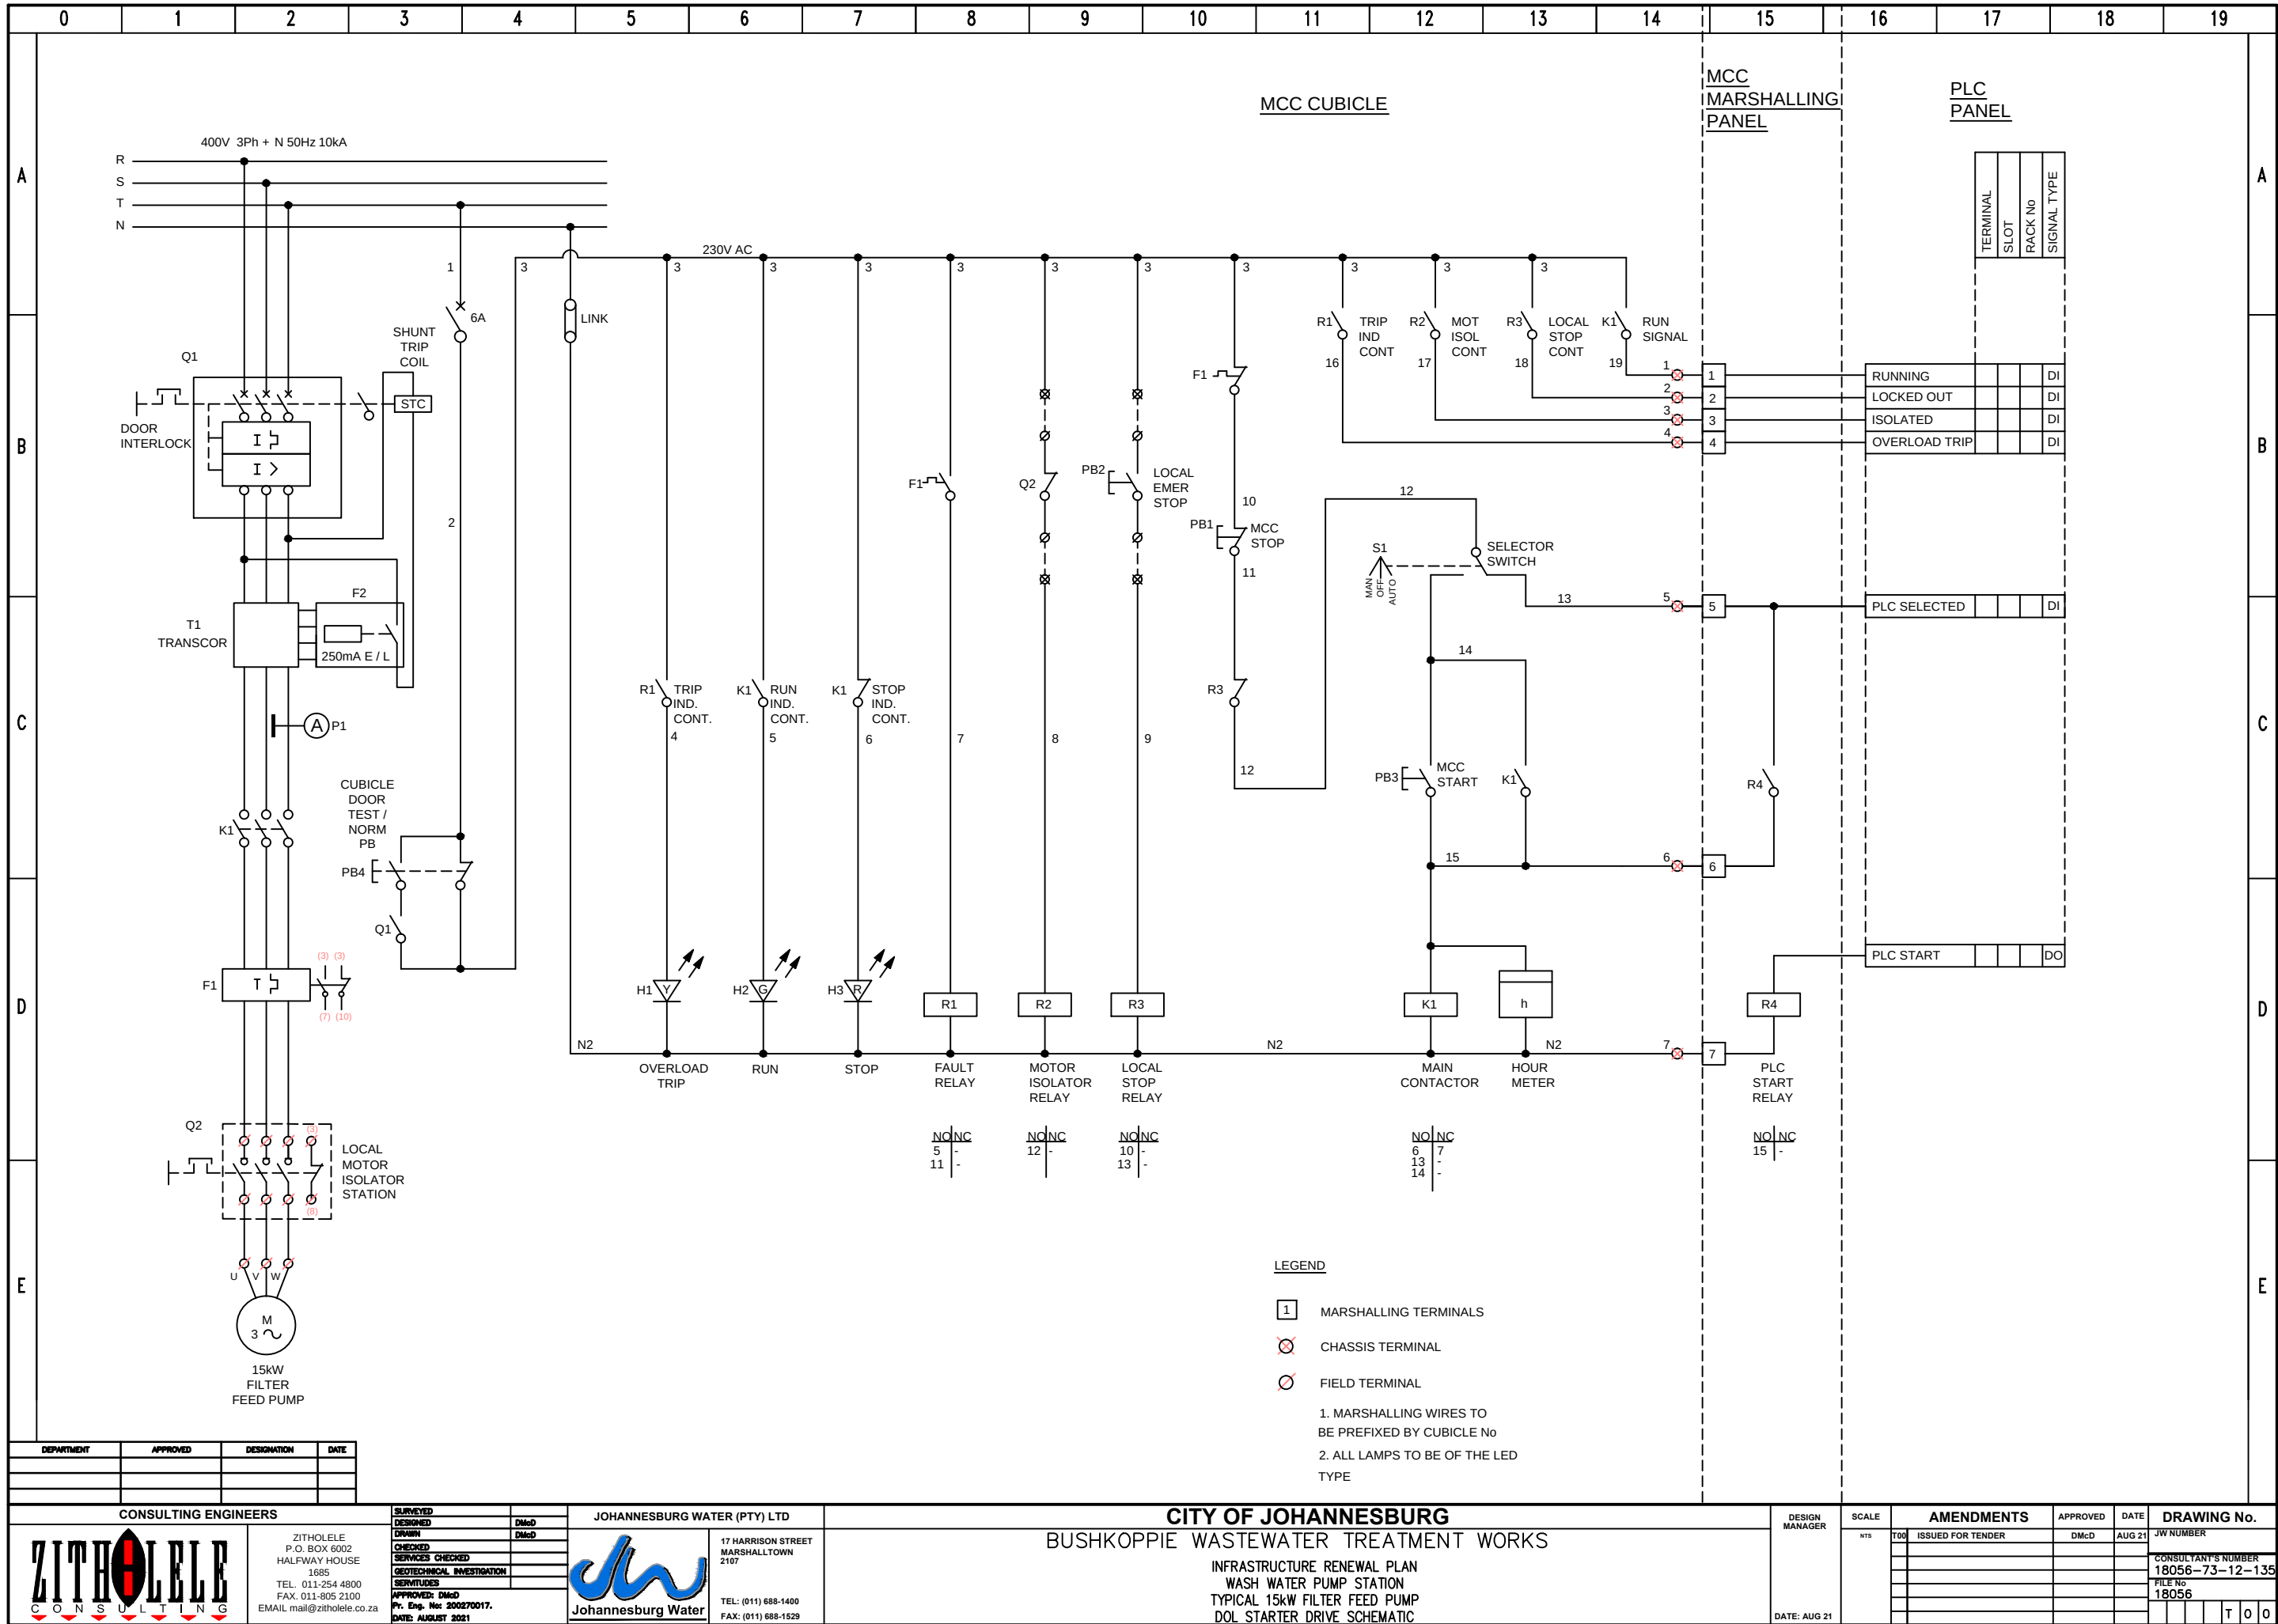


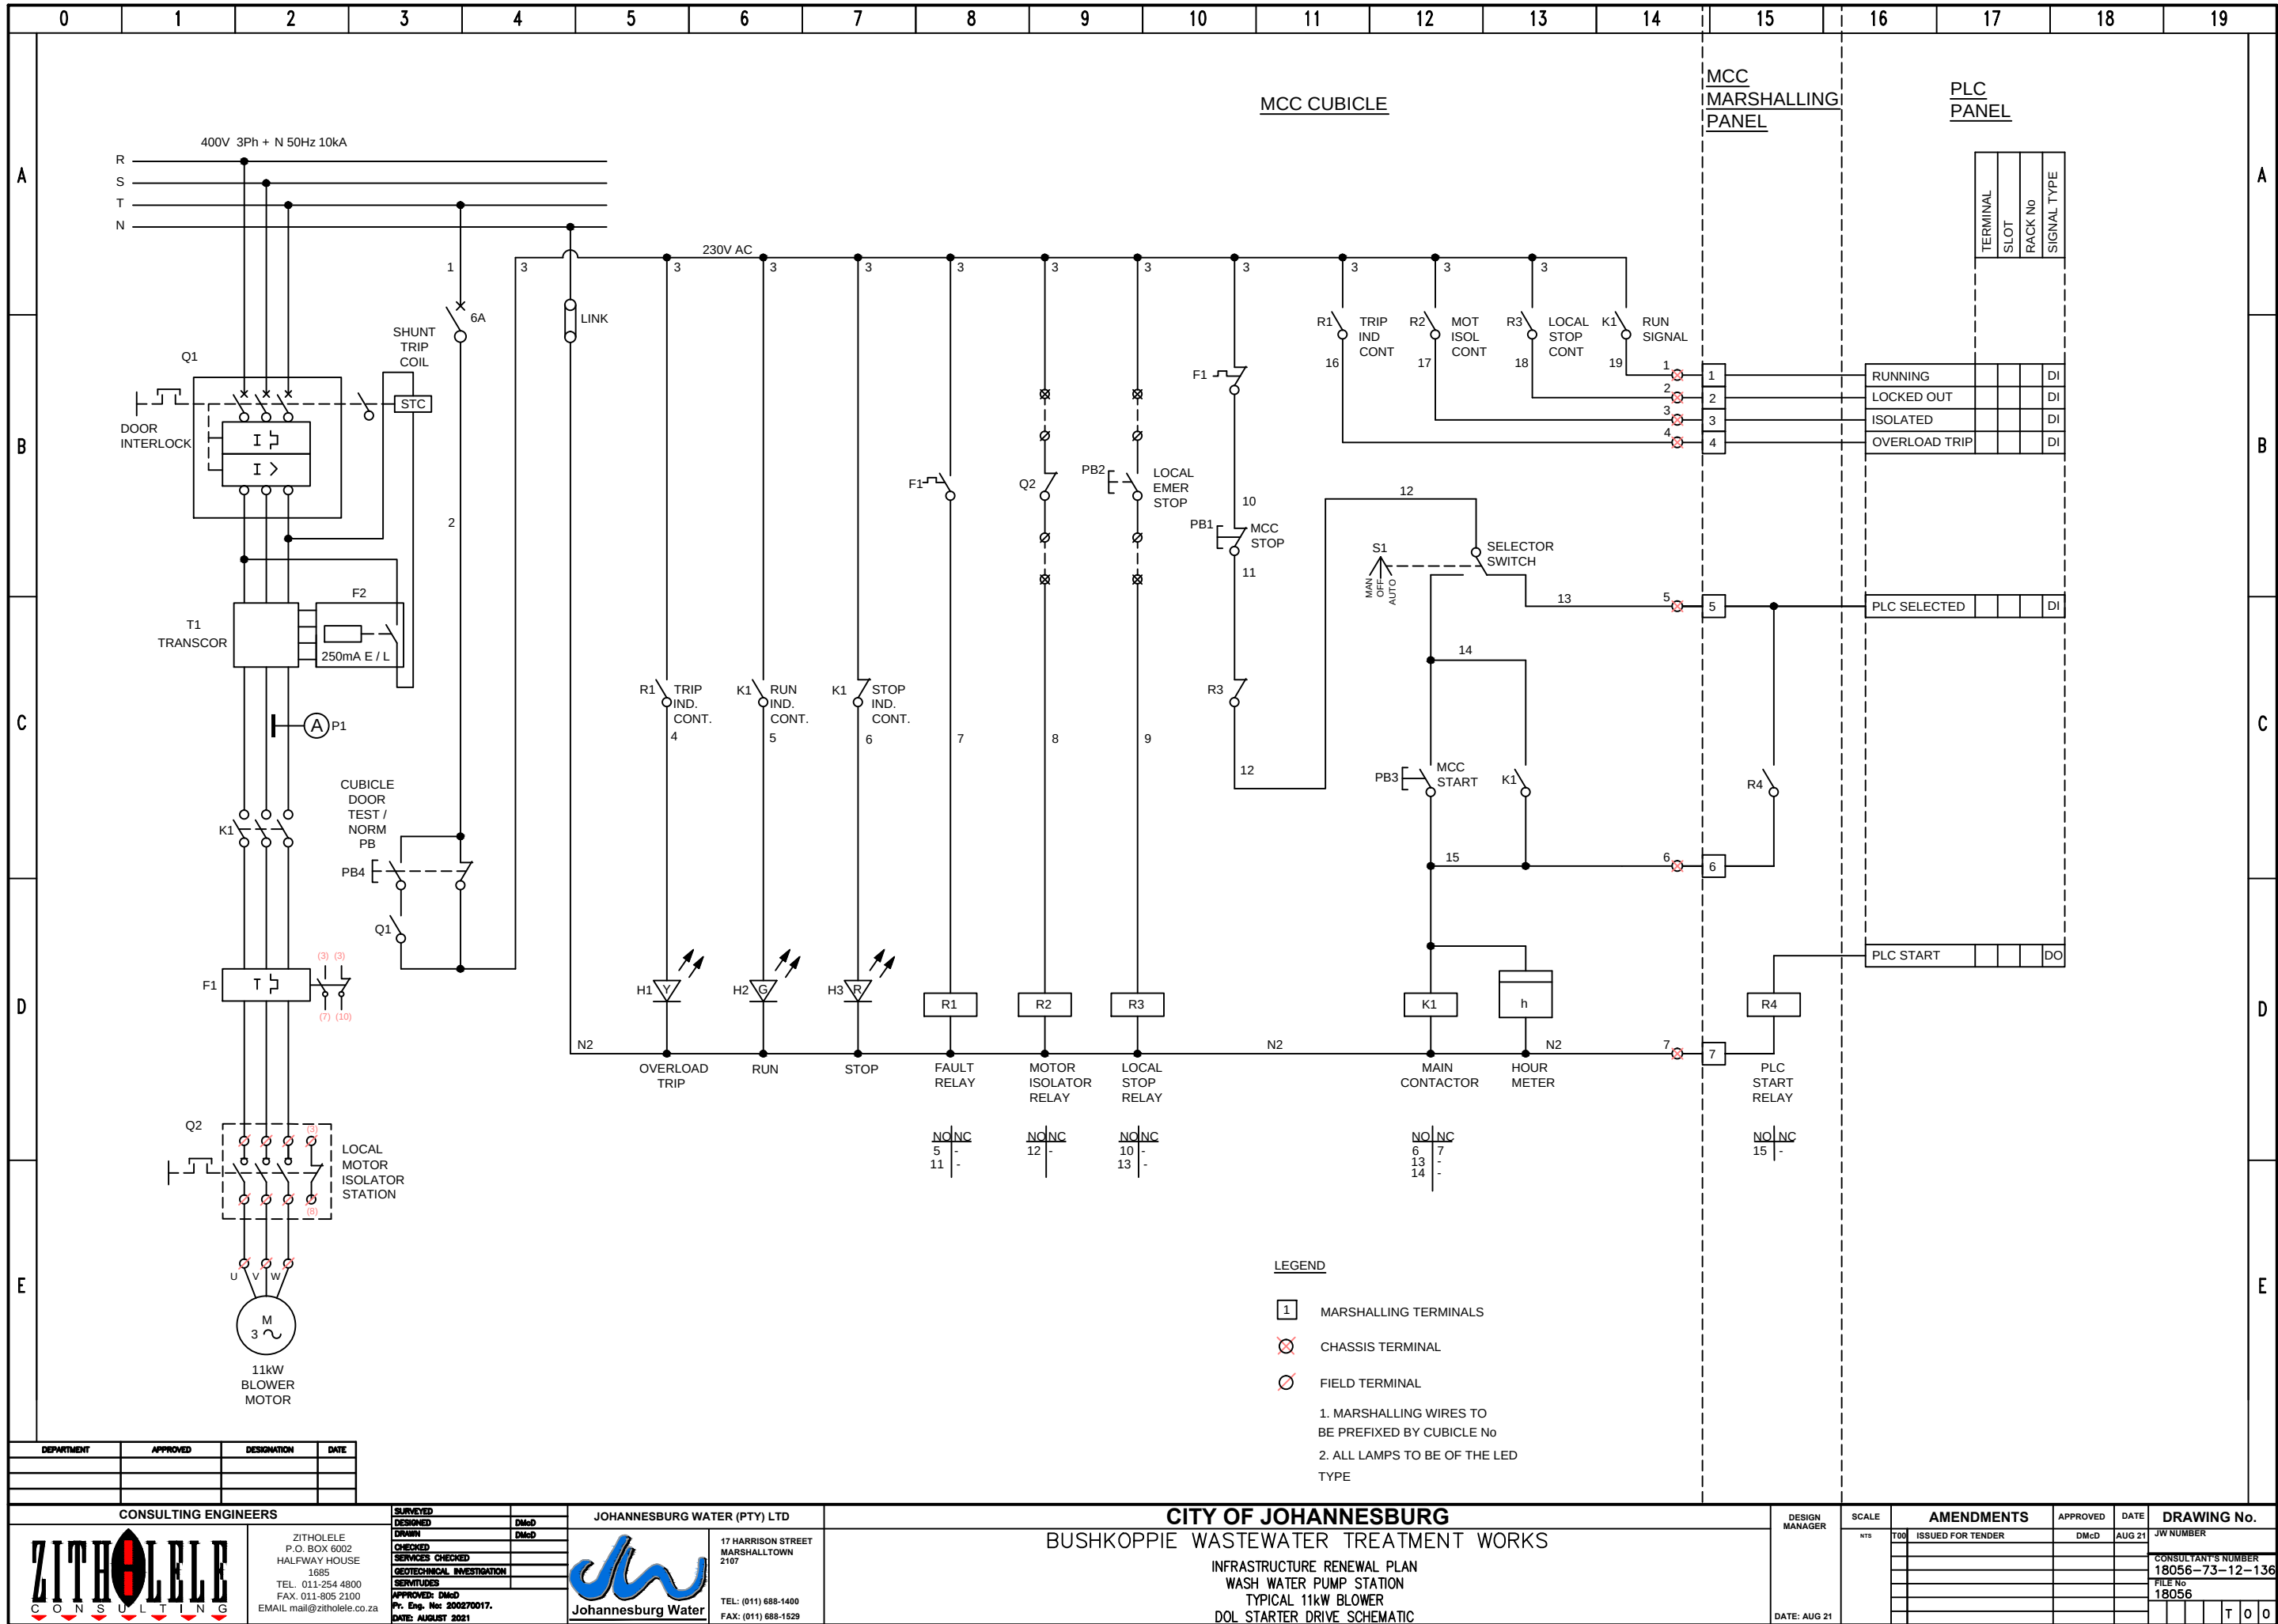


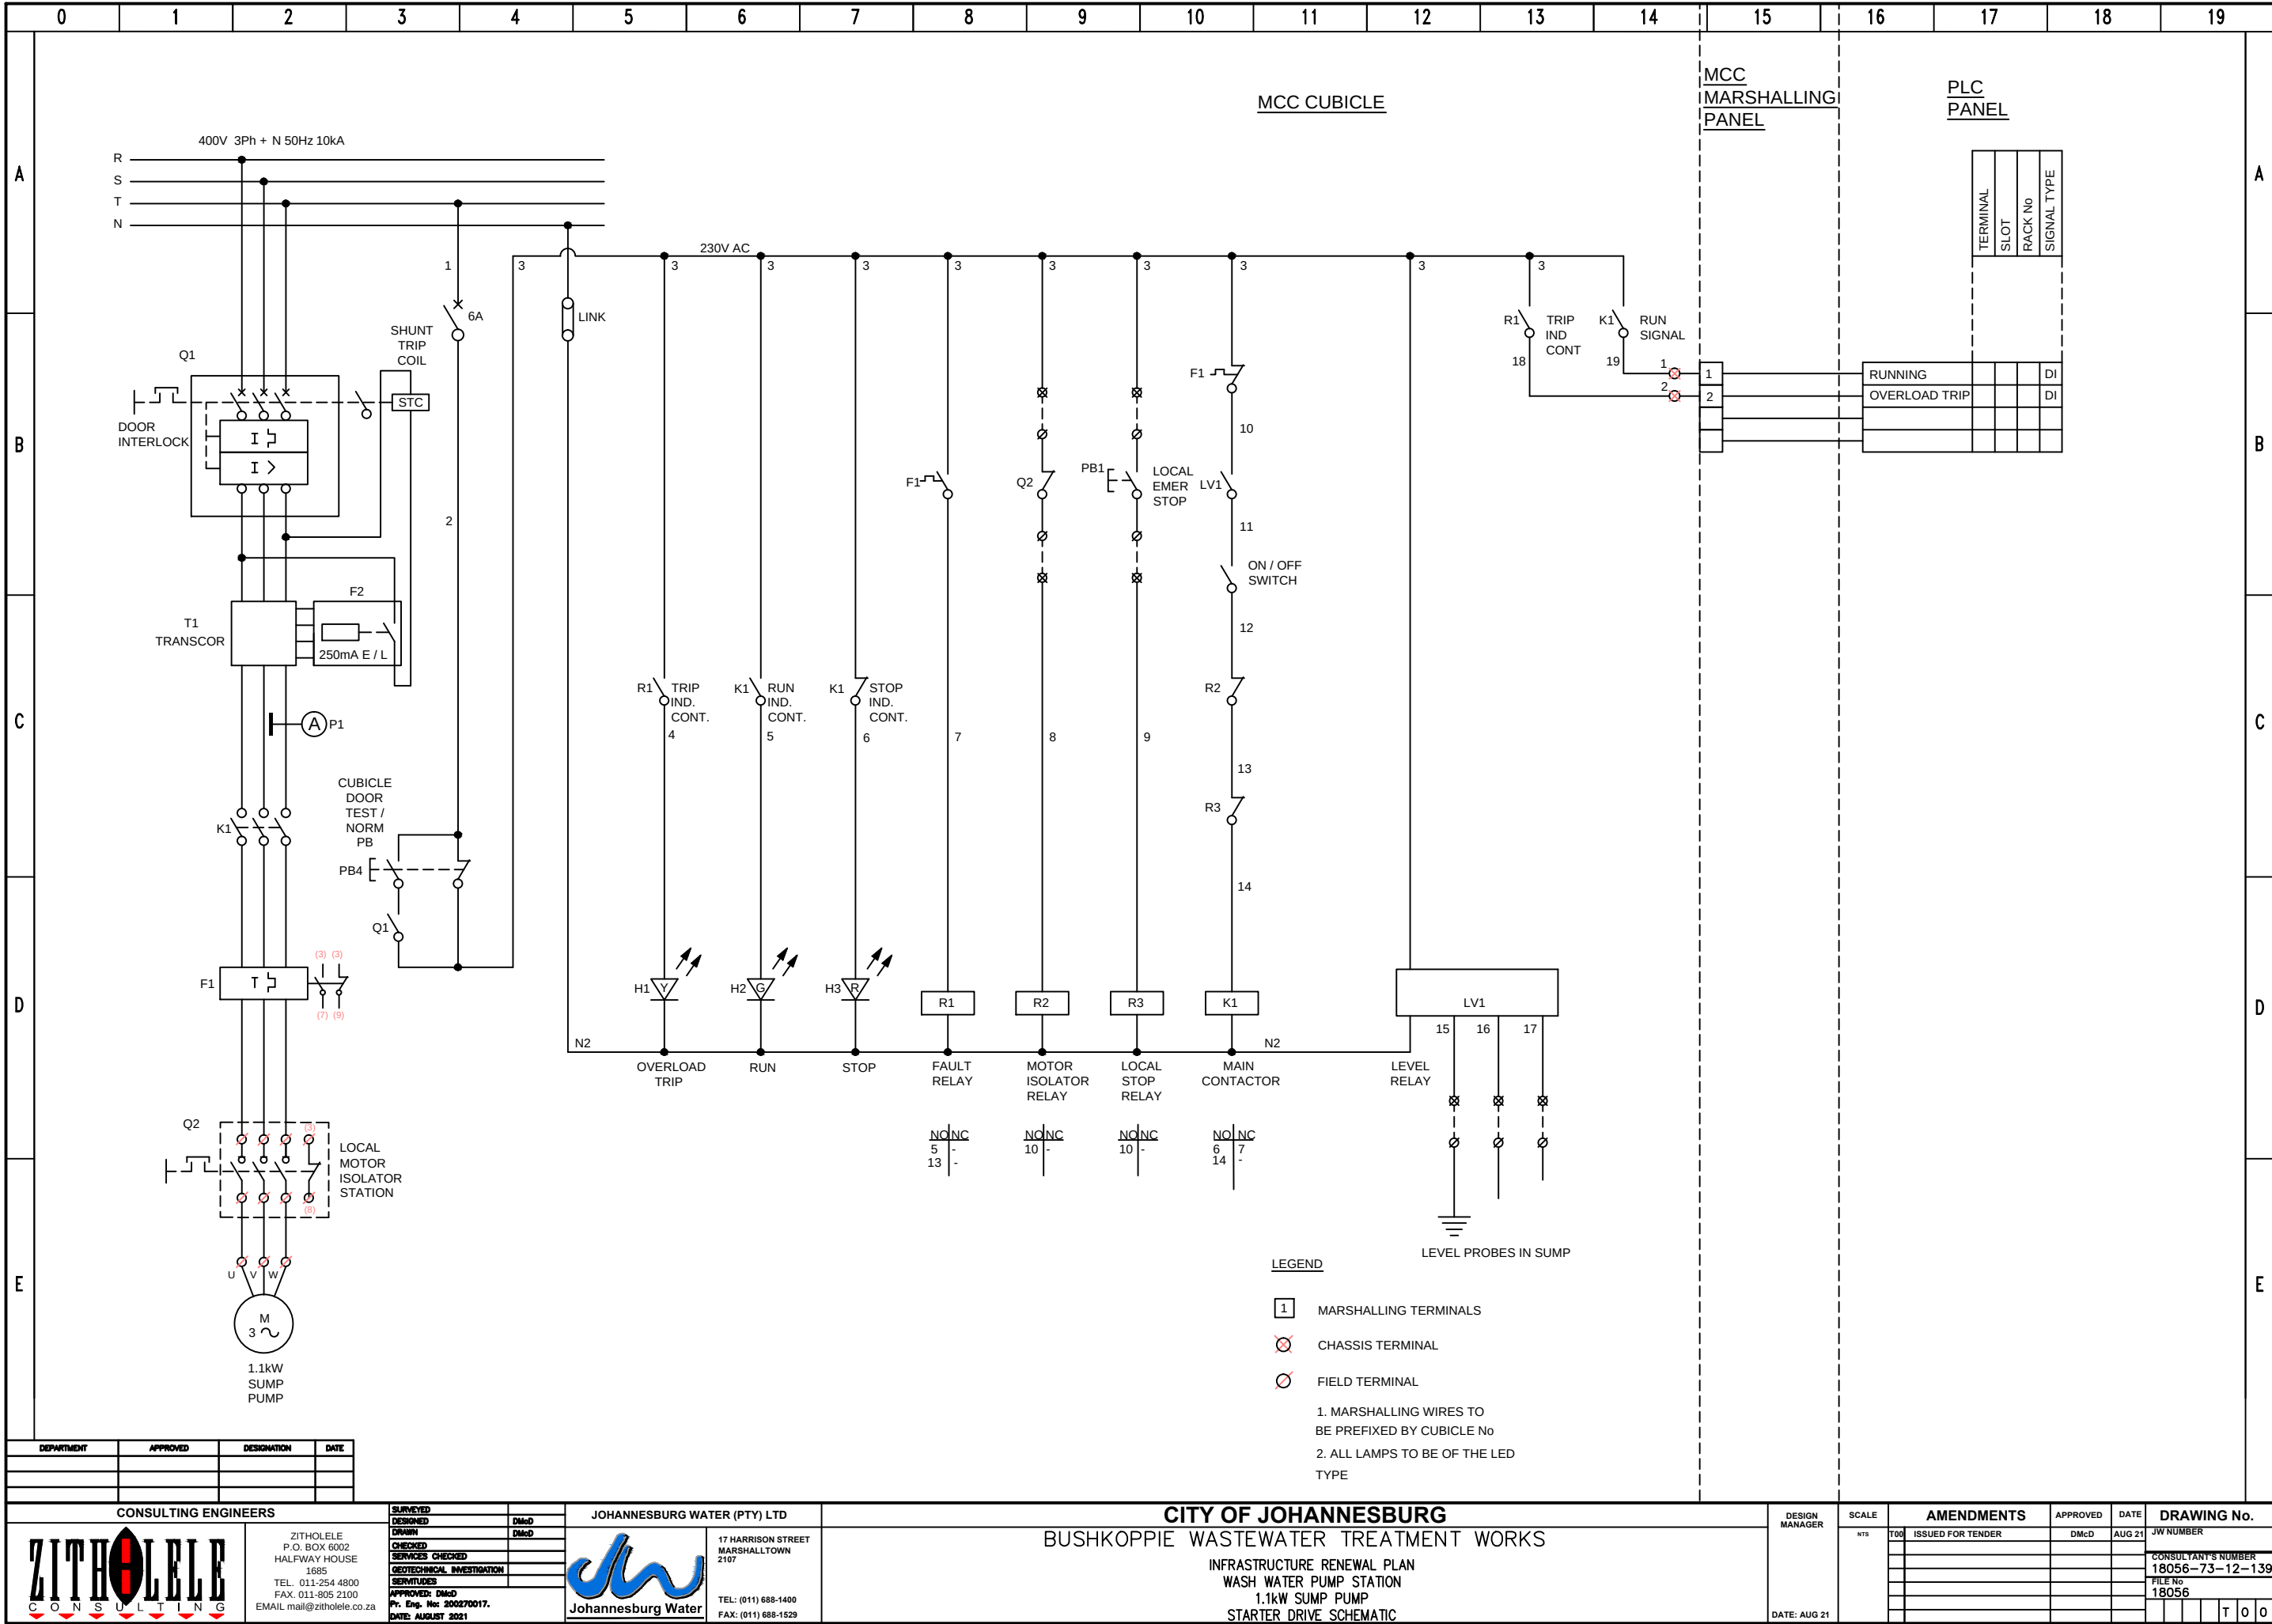

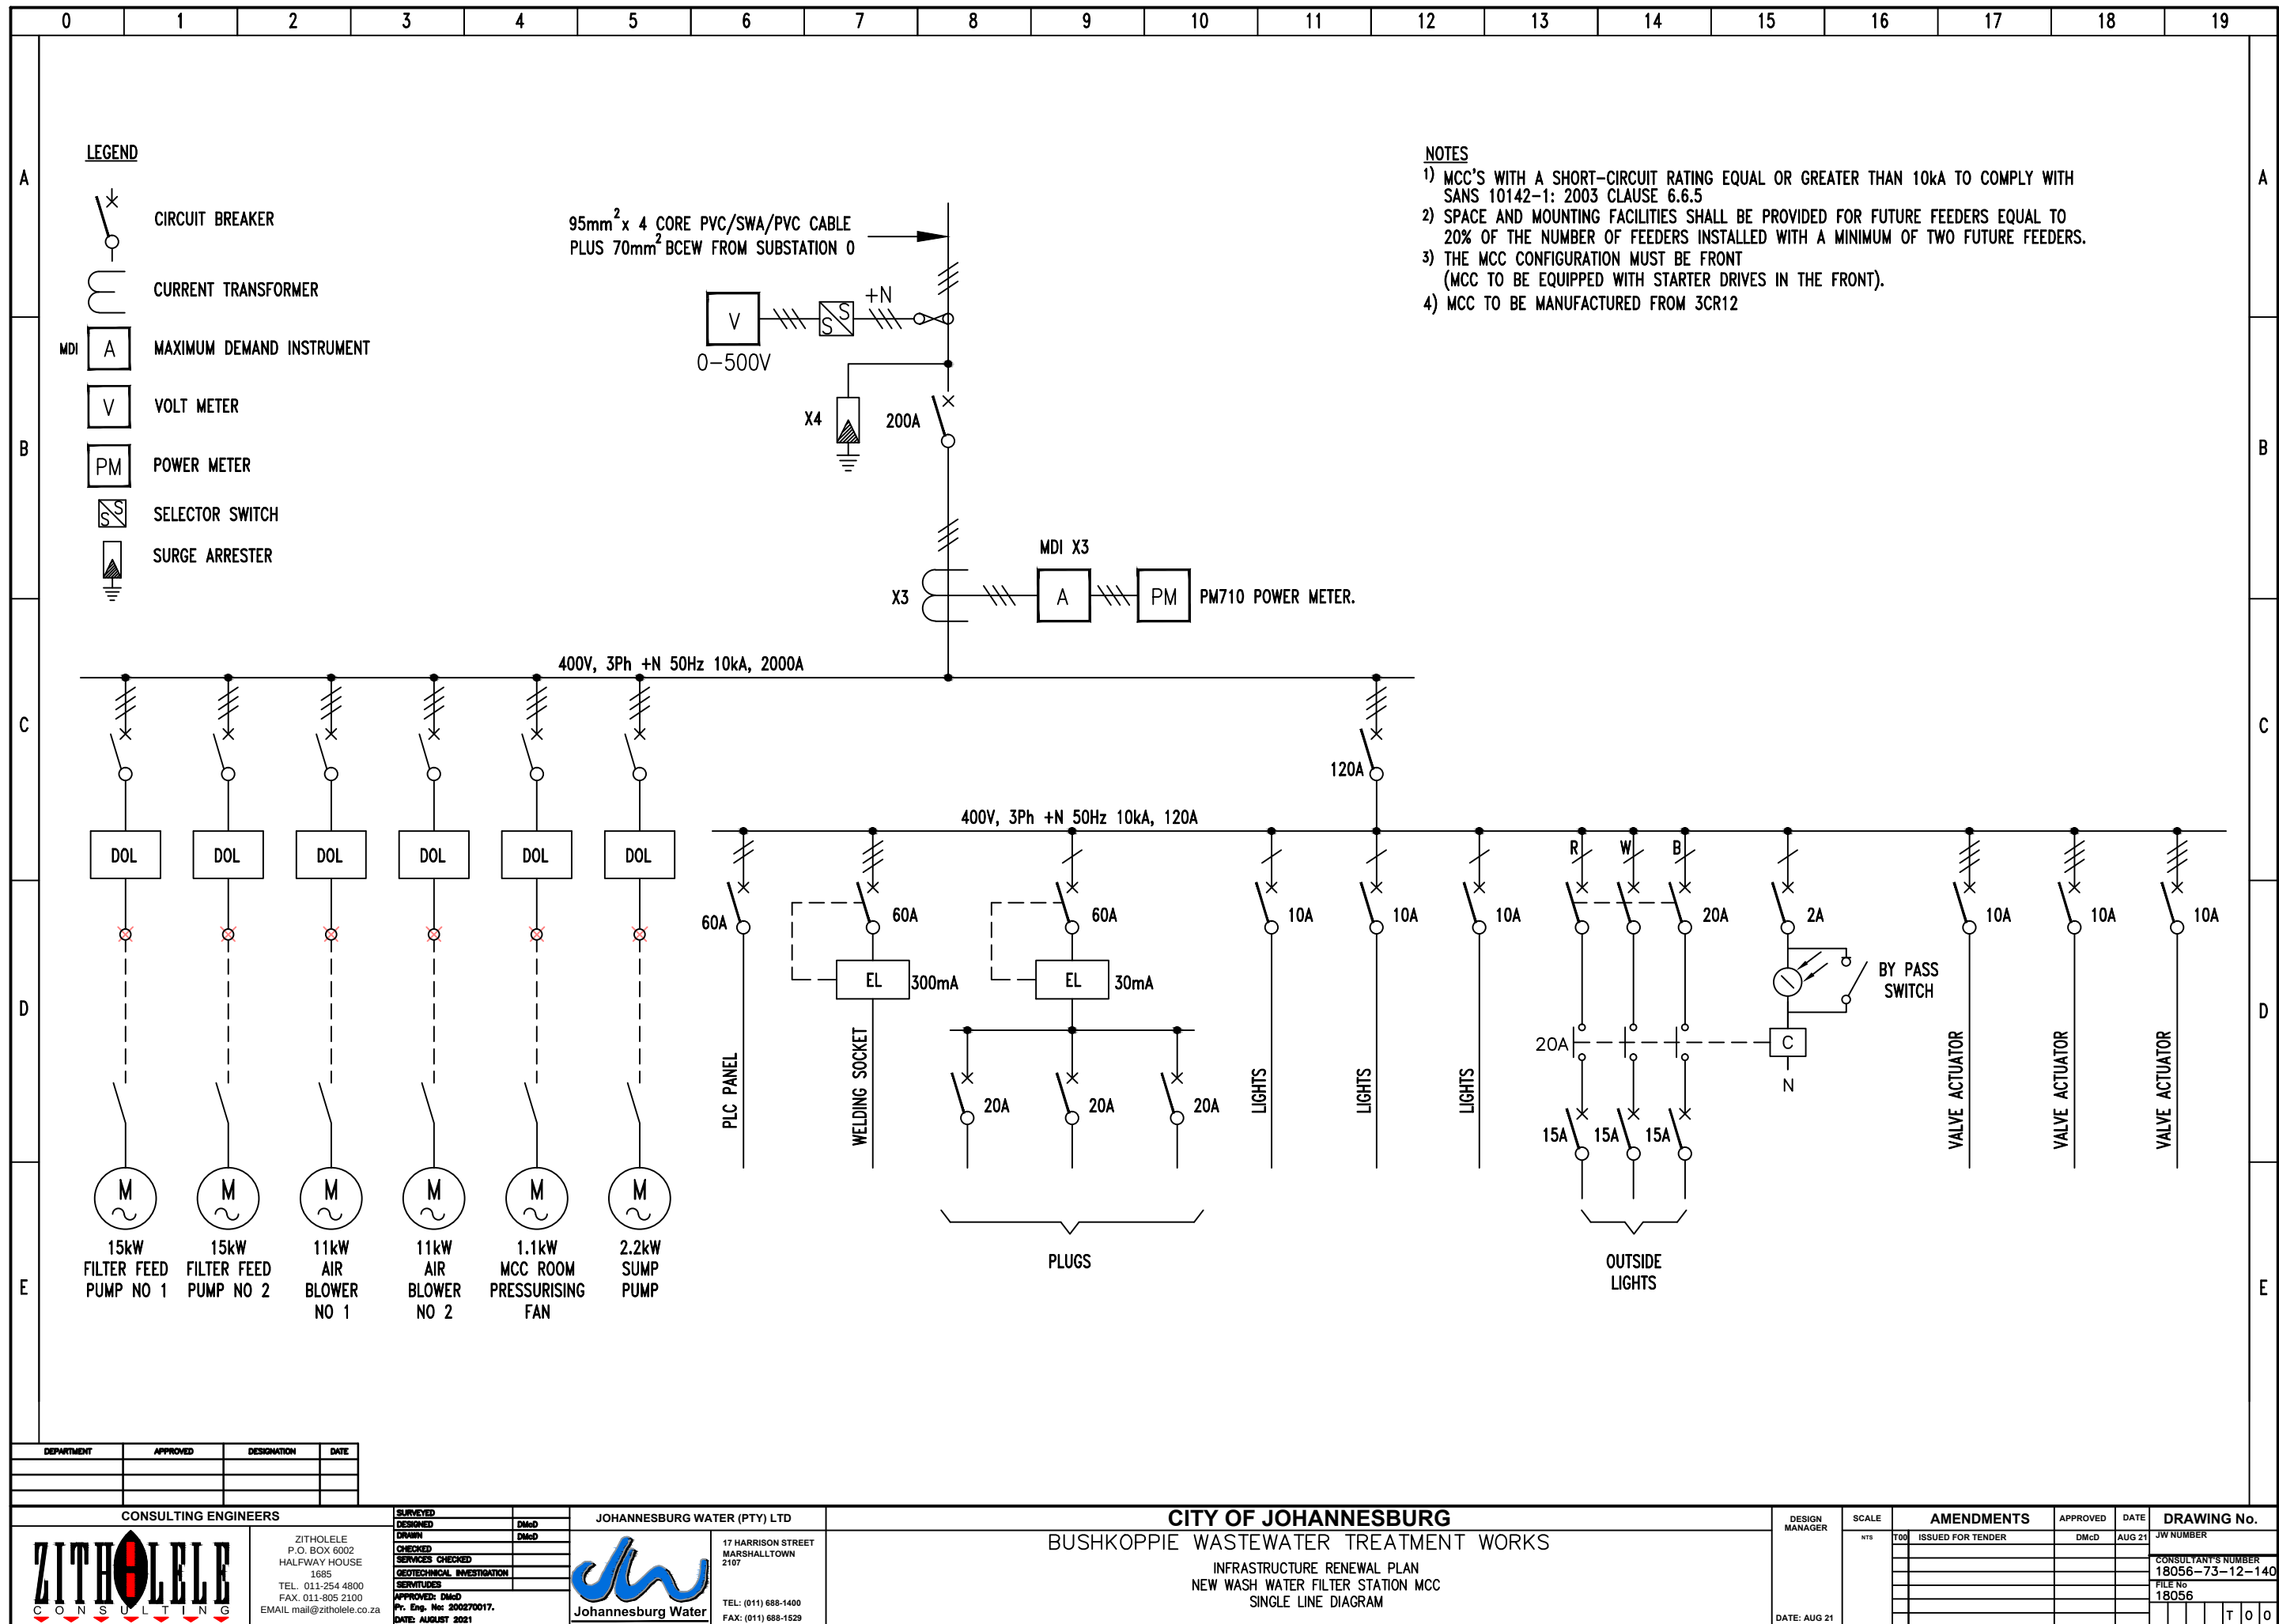

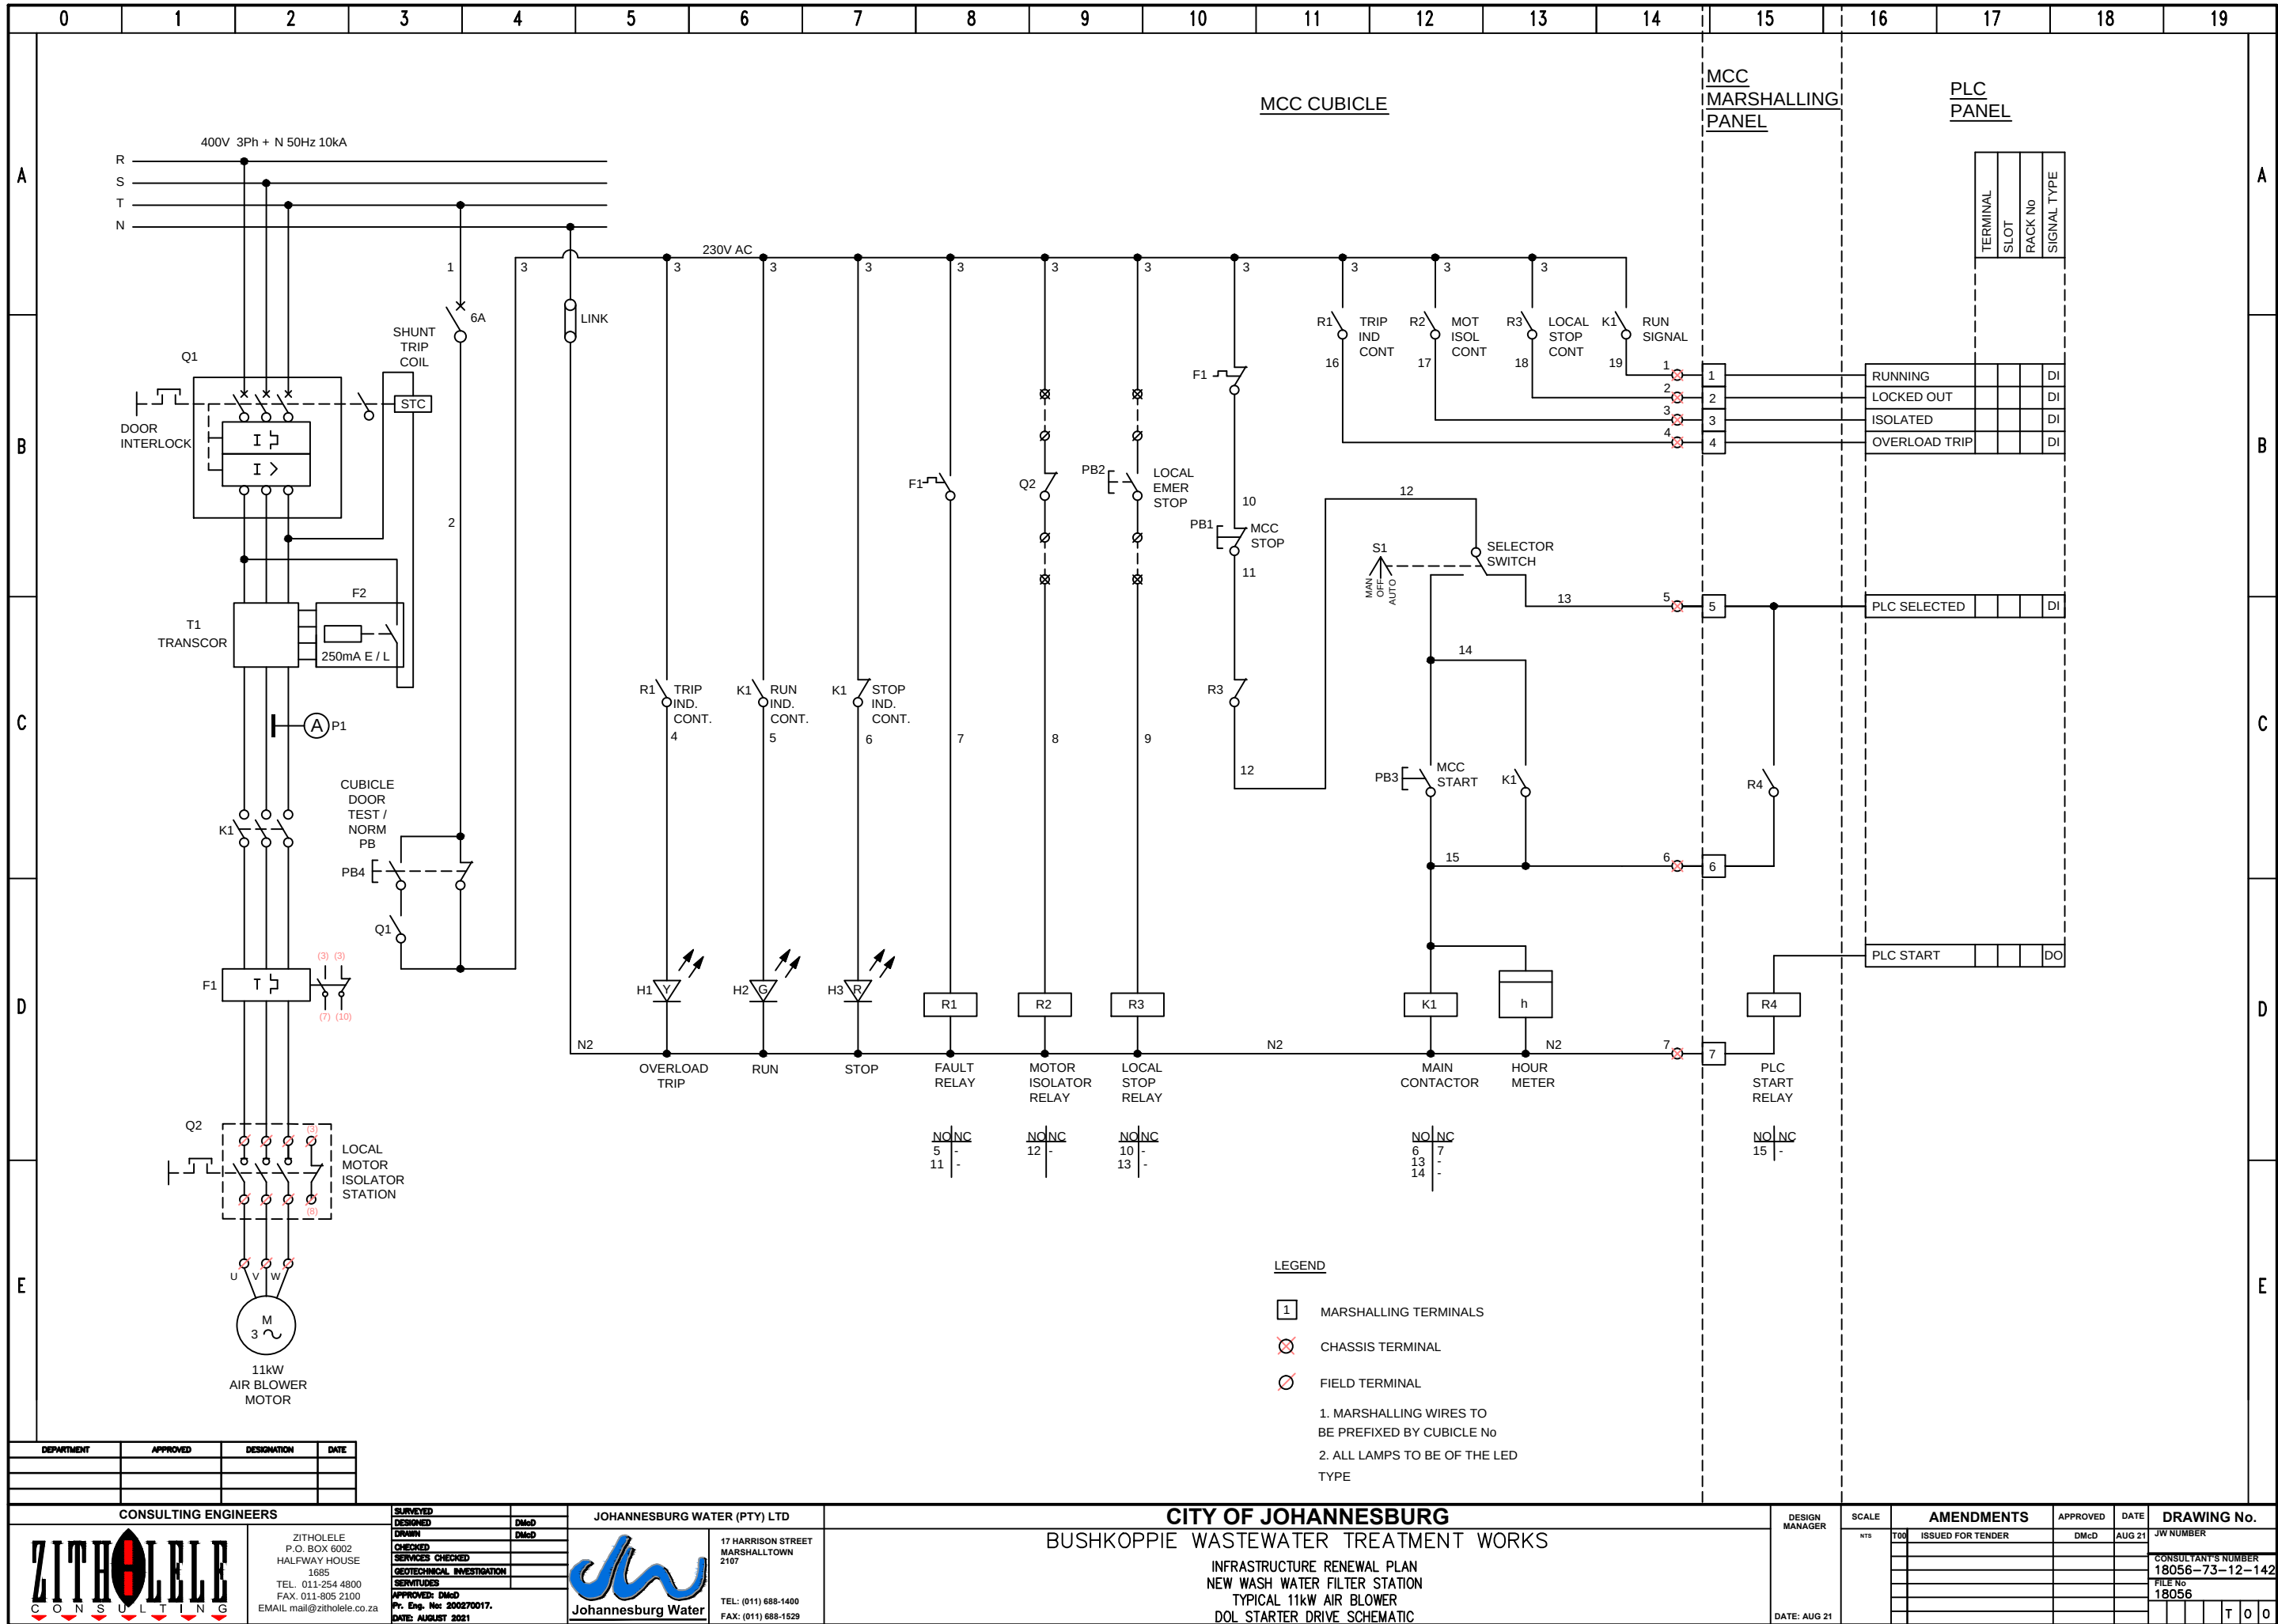


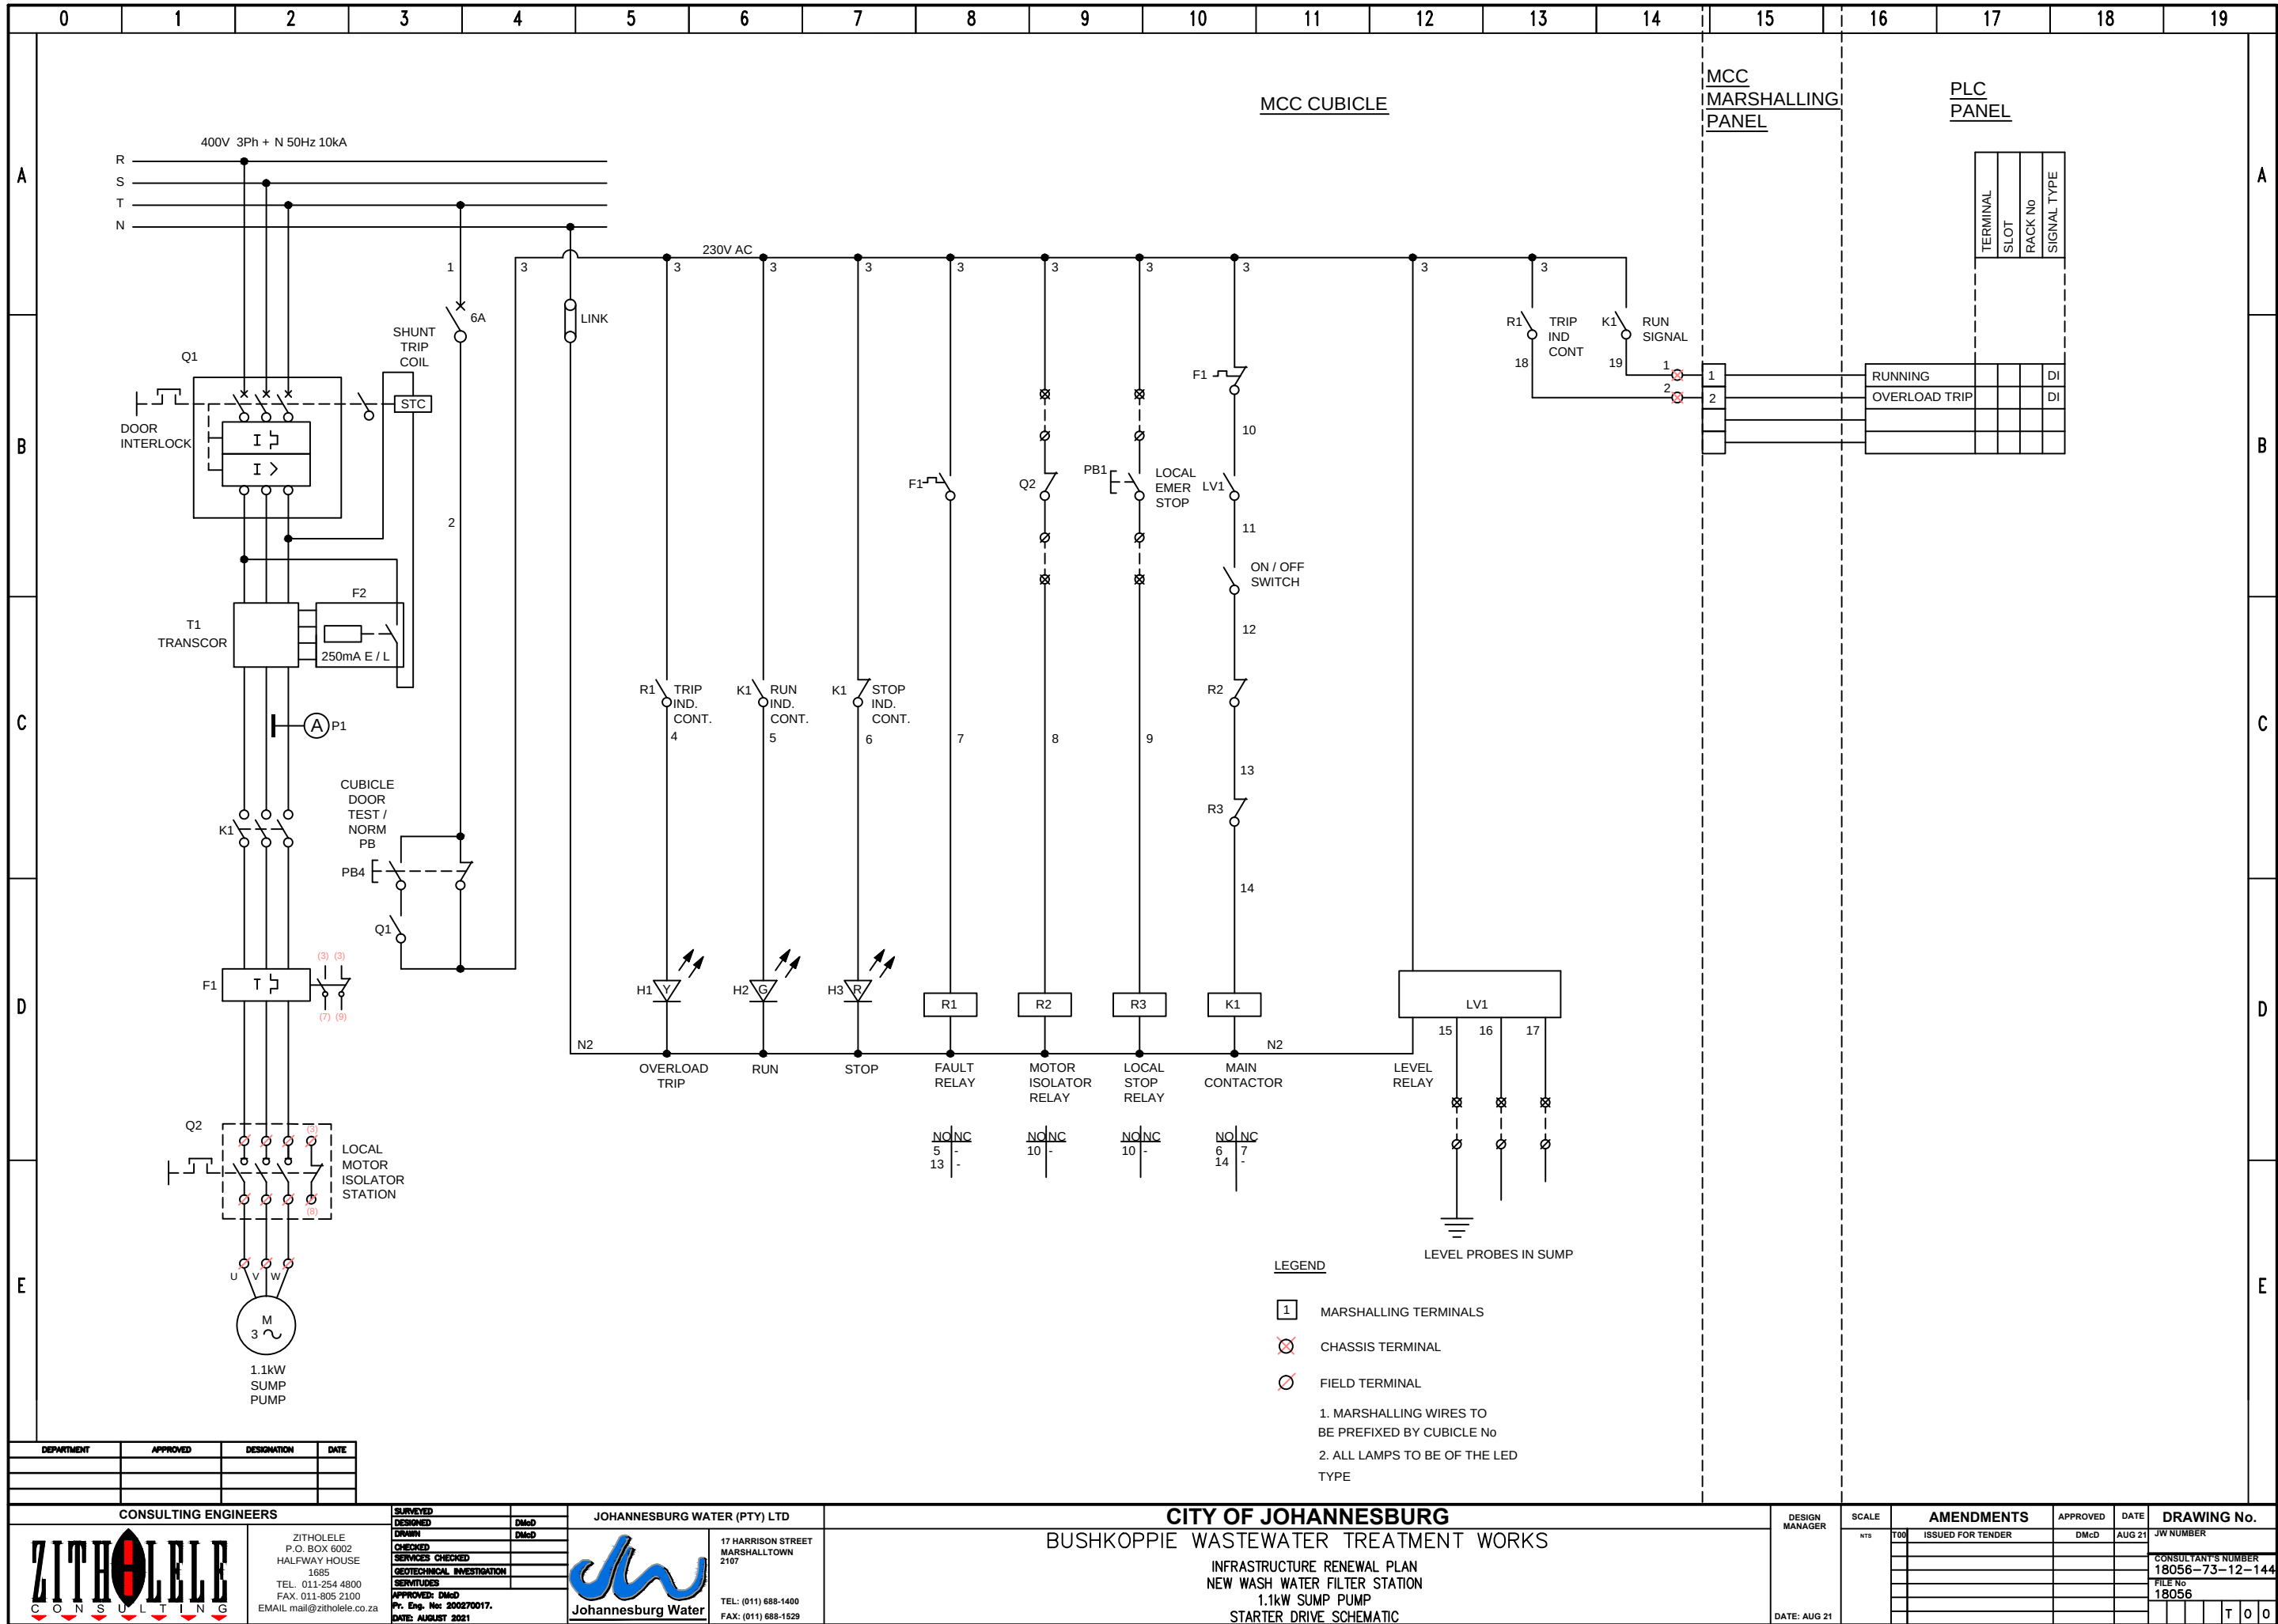

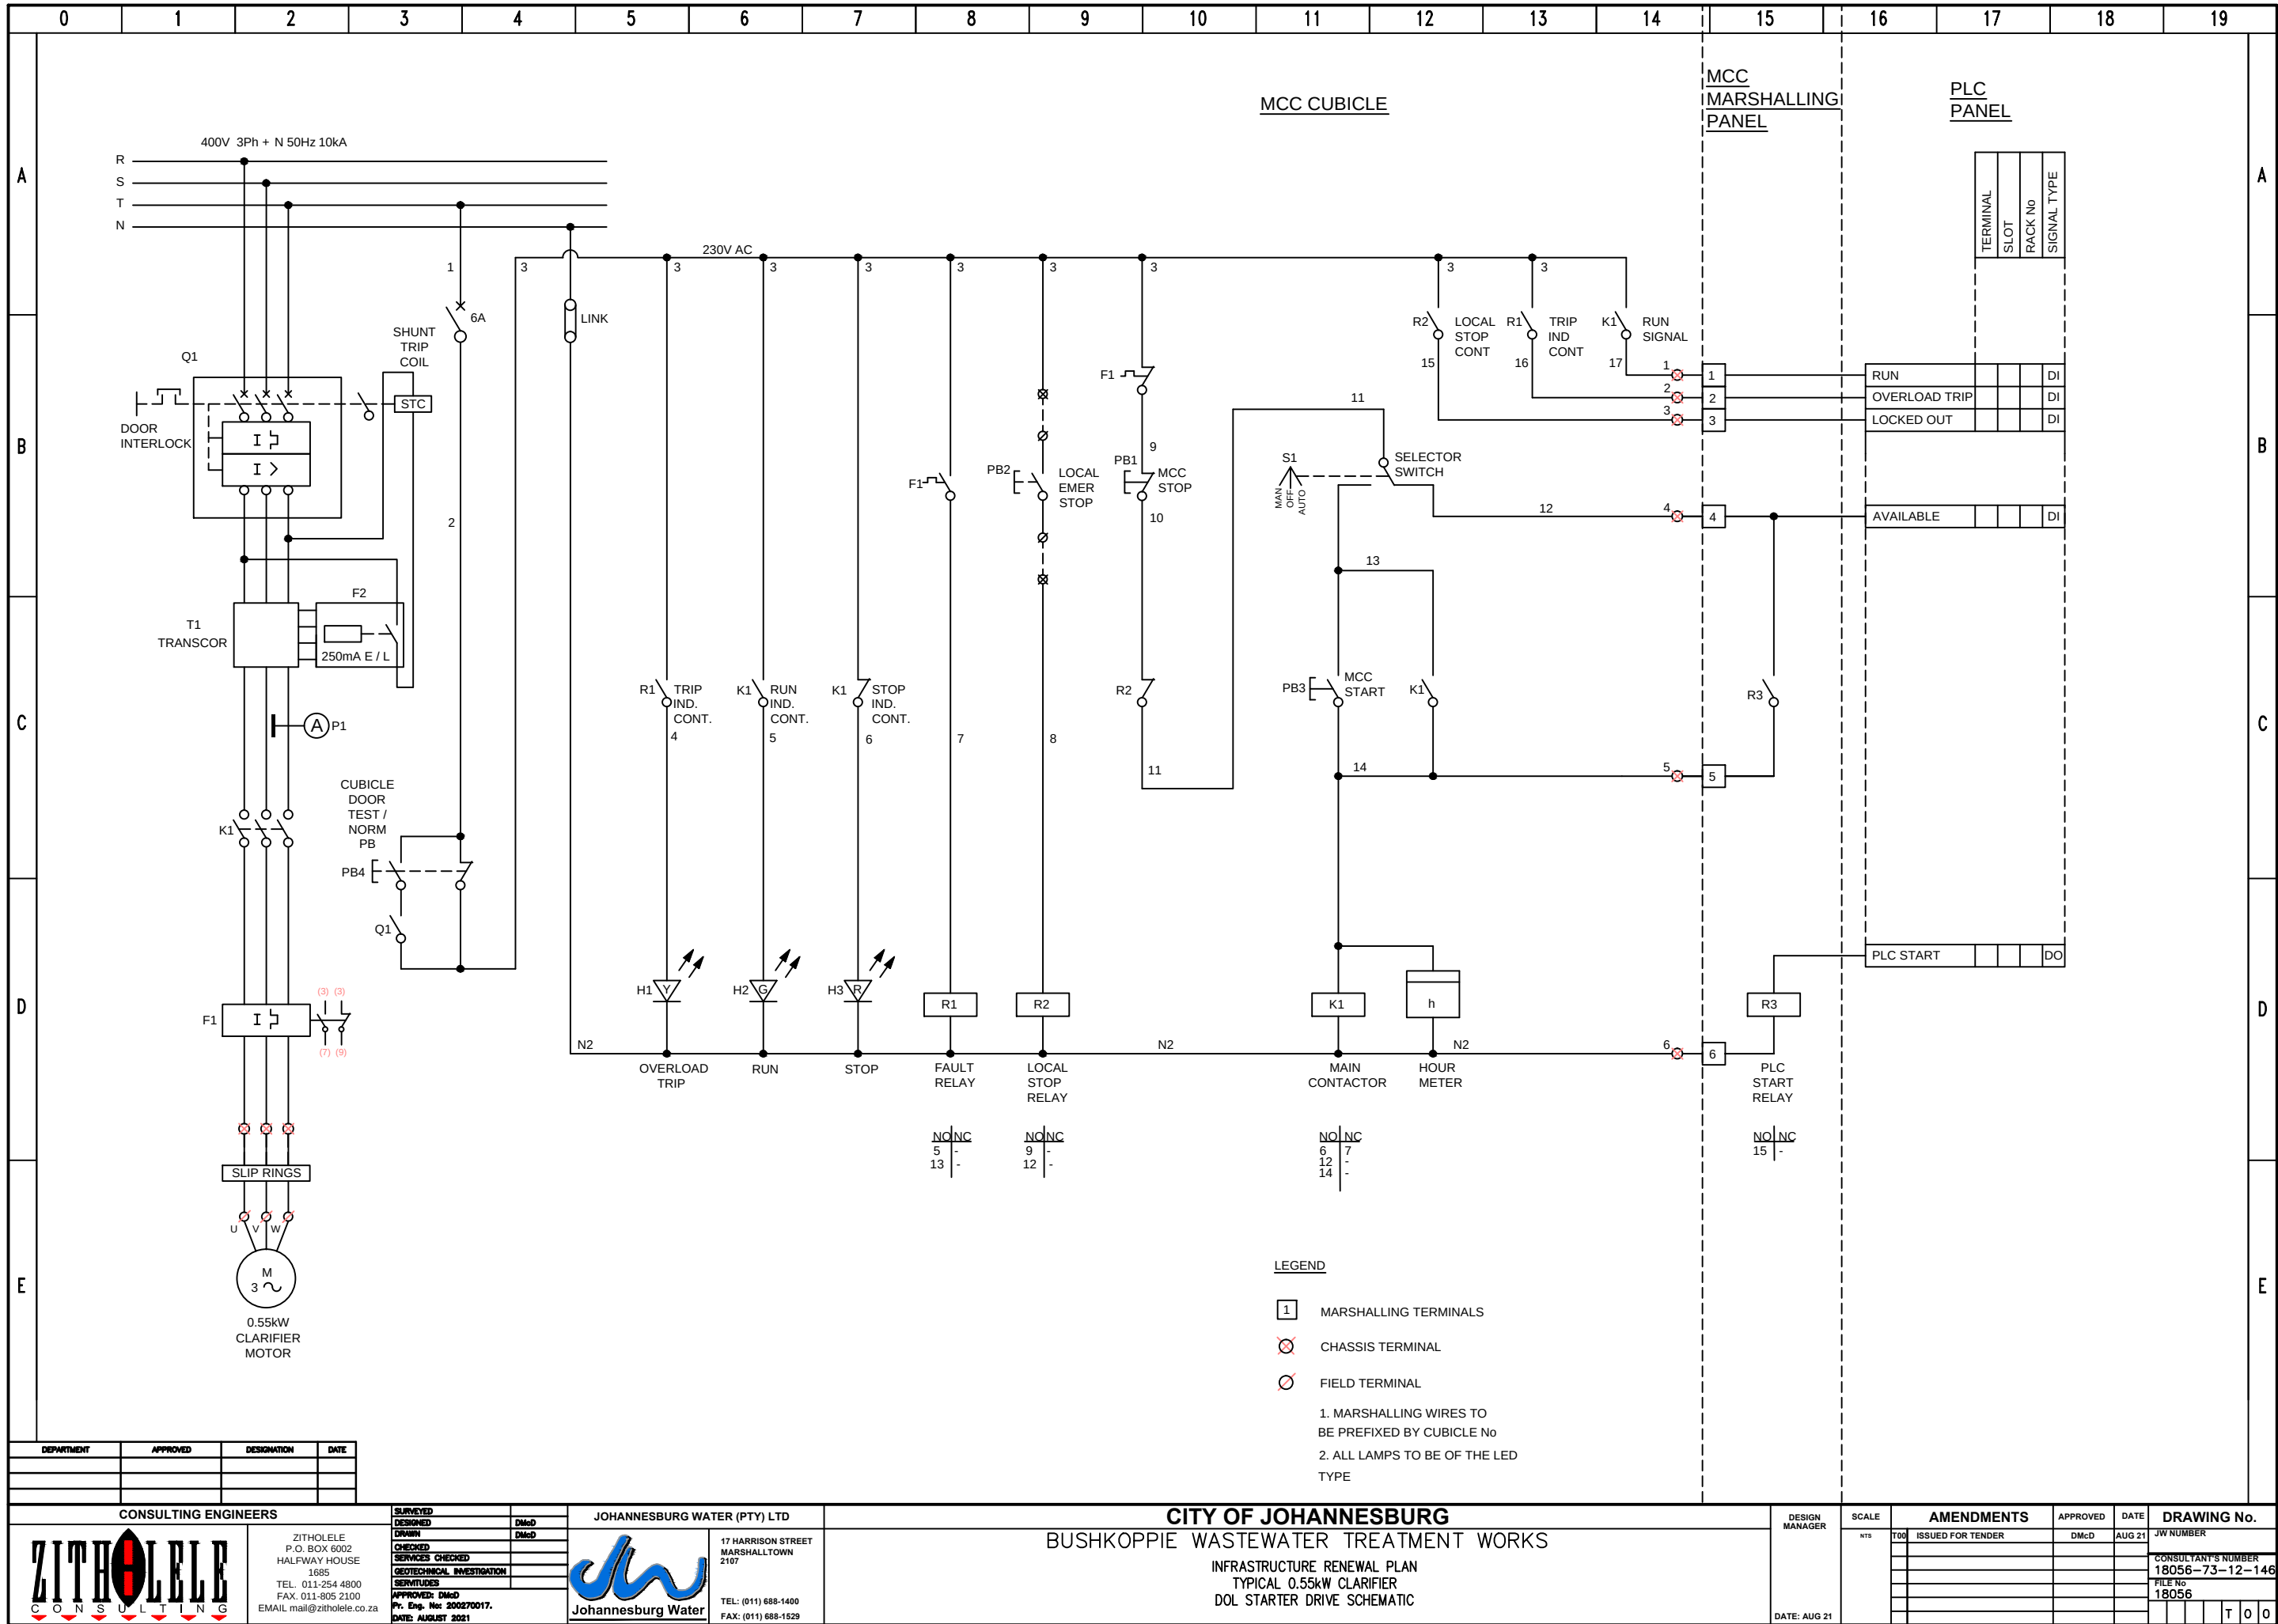






LEGEND:

- 1.2m 46W IP65 POLYCARBONATE LED (NATURAL WHITE) LUMINAIRE.
- 1.2m 46W IP65 POLYCARBONATE LED (NATURAL WHITE) EMERGENCY LUMINAIRE (1 HOUR).
- 18W IP65 LED (NATURAL WHITE) OUTDOOR BULKHEAD.
- PHOTO CELL
- FLUSH MOUNTED 16A ONE LEVER ONE WAY SWITCH
- FLUSH MOUNTED 16A 3 PIN SWITCHED SOCKET OUTLET
- FLUSH MOUNTED DUO 16A 3 PIN SWITCHED SOCKET OUTLET
- SURFACE MOUTED 60A 5 PIN (ROUND) WELDING SOCKET OUTLET
- SURFACE MOUTED 30A 3 PHASE FAN ISOLATOR
- MCC ROOM PRESSURISING FAN

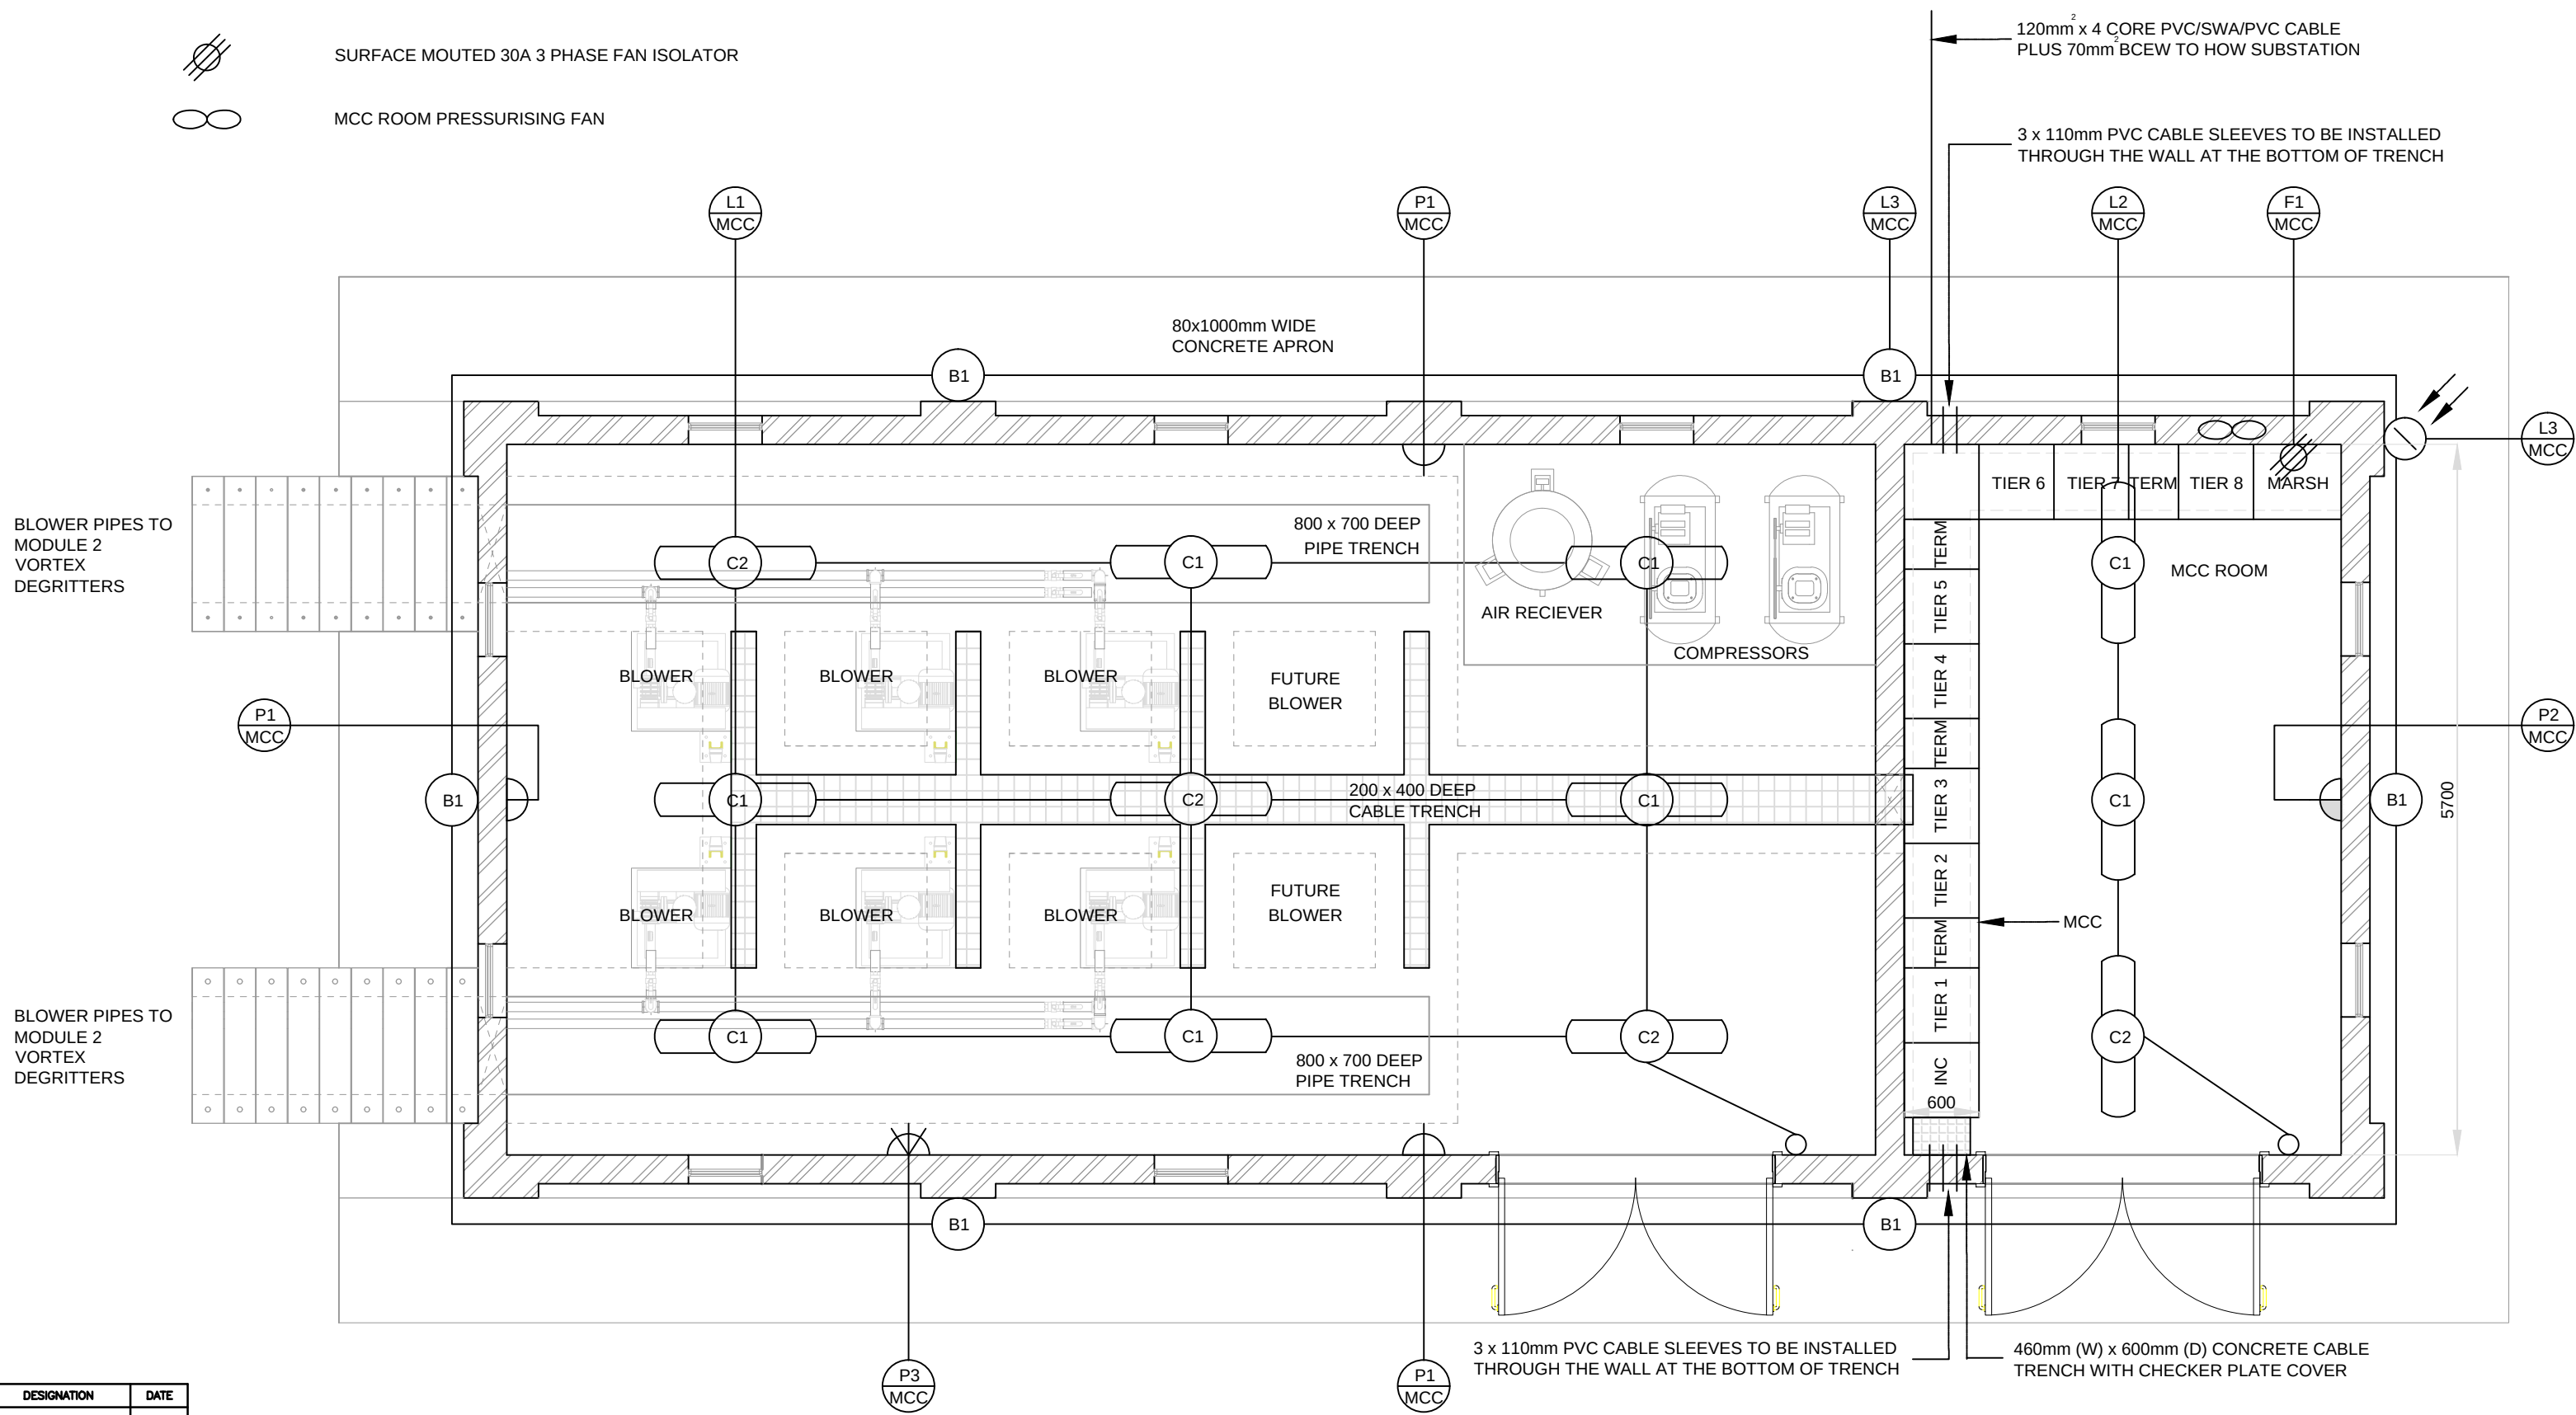

DEPARTMENT	APPROVED	DESIGNATION	DATE

 CONSULTING ENGINEERS				JOHANNESBURG WATER (PTY) LTD		CITY OF JOHANNESBURG				DESIGN MANAGER	SCALE	AMENDMENTS		APPROVED	DATE	DRAWING No.			
	ZITHOLELE P.O. BOX 6002 HALFWAY HOUSE 1685 TEL. 011-254 4800 FAX. 011-805 2100 EMAIL mail@zitholele.co.za			SURVEYED			17 HARRISON STREET MARSHALLTOWN 2107 TEL: (011) 688-1400 FAX: (011) 688-1529					BUSHKOPPIE WASTEWATER TREATMENT WORKS				T00	ISSUED FOR TENDER	DMcD	AUG 21
				DESIGNED	DMcD						T01	ISSUED FOR TENDER	DMcD	MAR 24	CONSULTANT'S NUMBER				
				DRAWN	DMcD										18056-73-12-149				
				CHECKED											FILE No				
				SERVICES CHECKED											18056				
				GEOTECHNICAL INVESTIGATION											T O 1				
				SERVITUDES						INFRASTRUCTURE RENEWAL PLAN MODULE 2 NEW BLOWER BUILDING LIGHTING & SMALL POWER LAYOUT				DATE: AUG 21					
				APPROVED	DMcD														
				Pr. Eng. No.	200270017														
				DATE	AUGUST 2021														

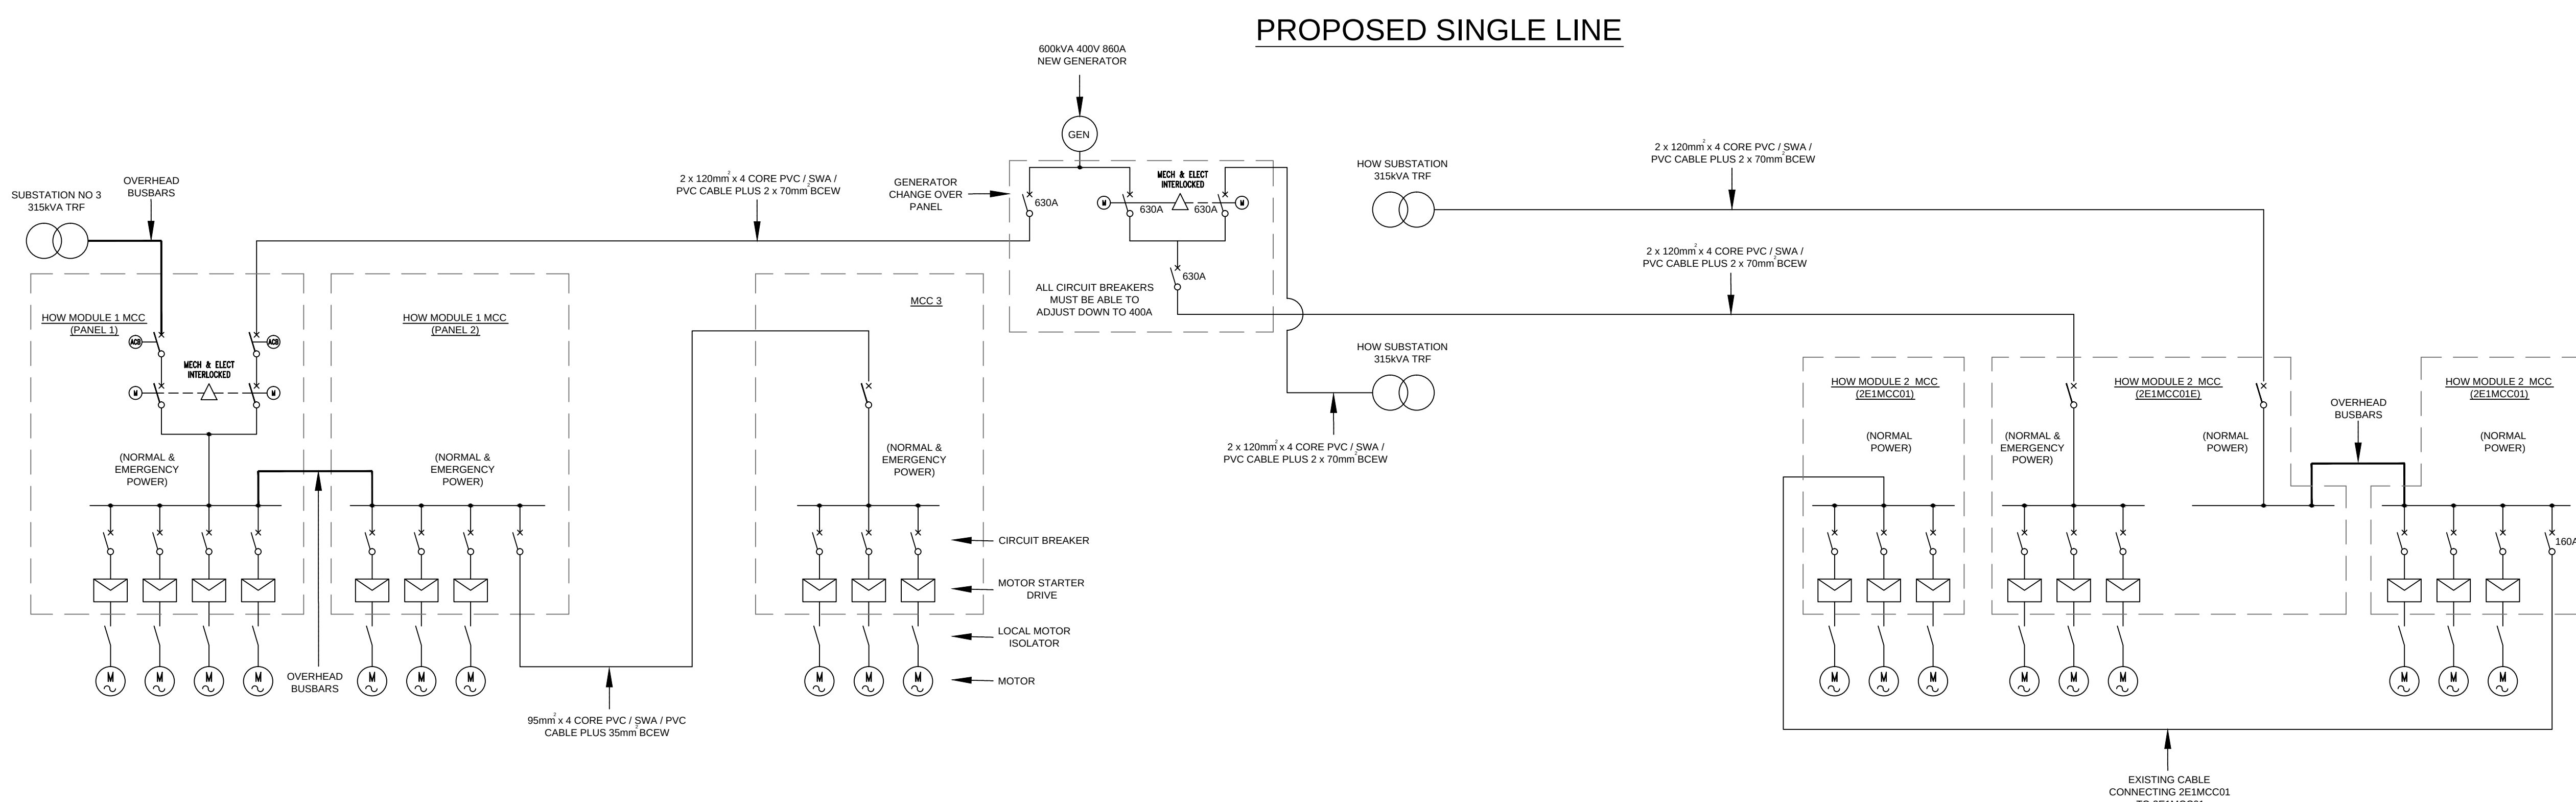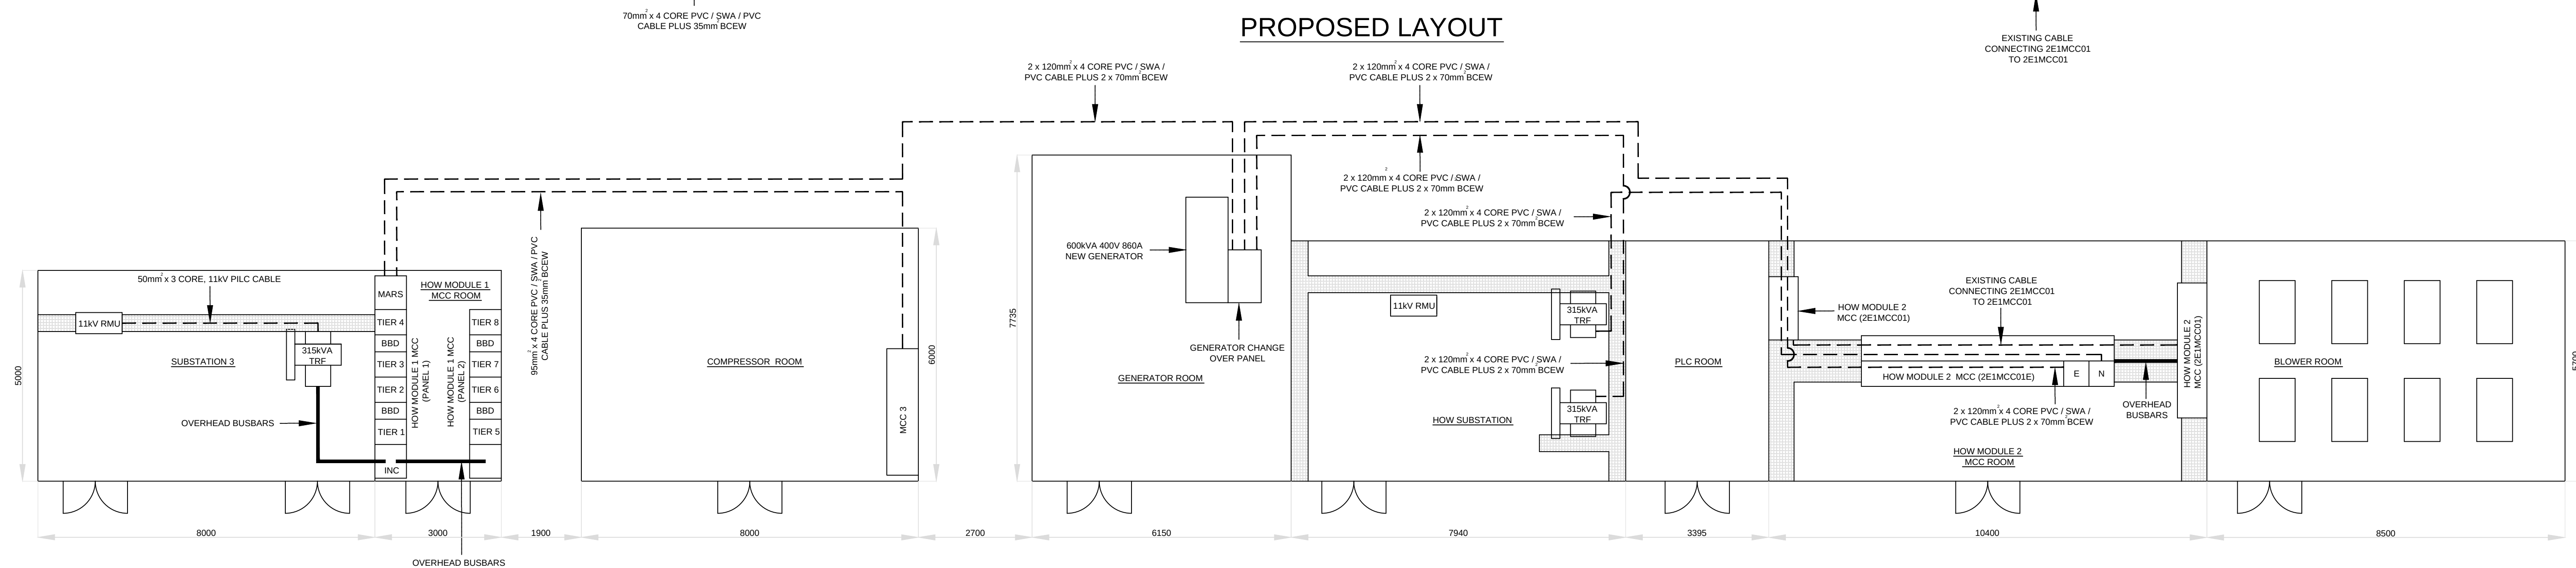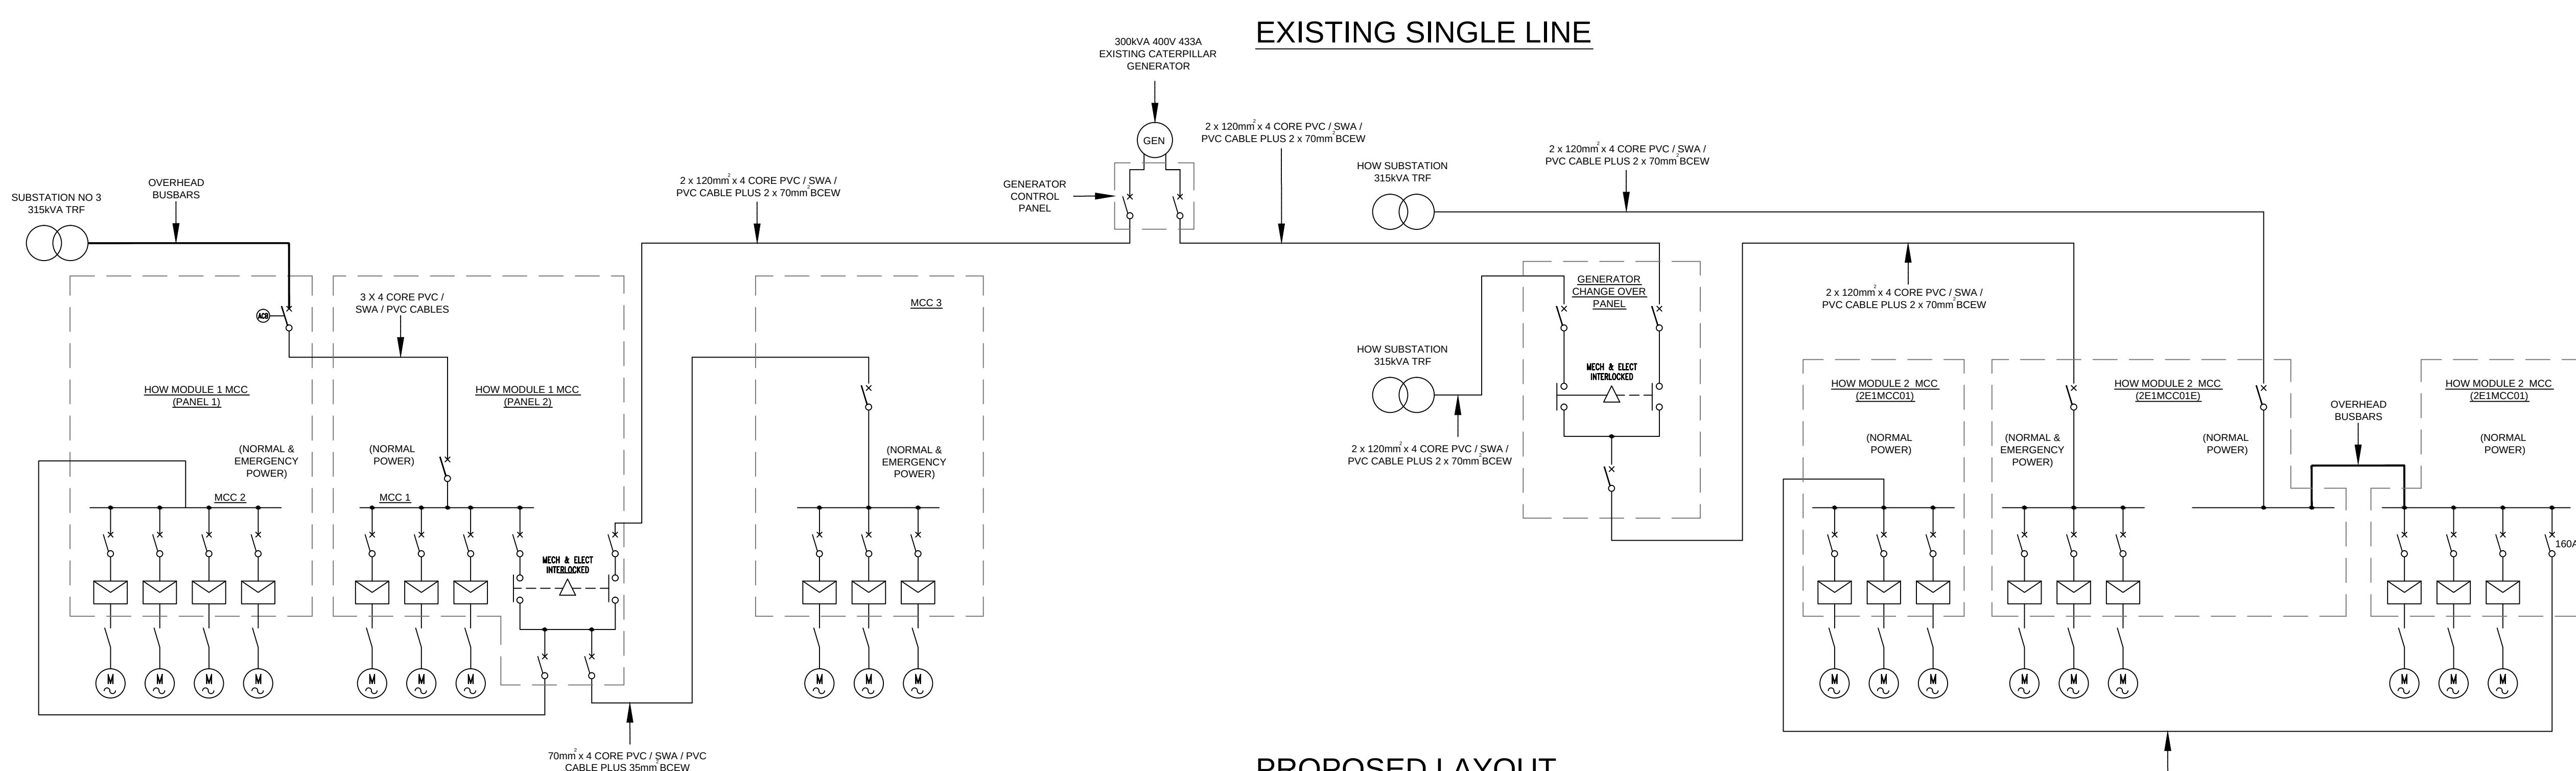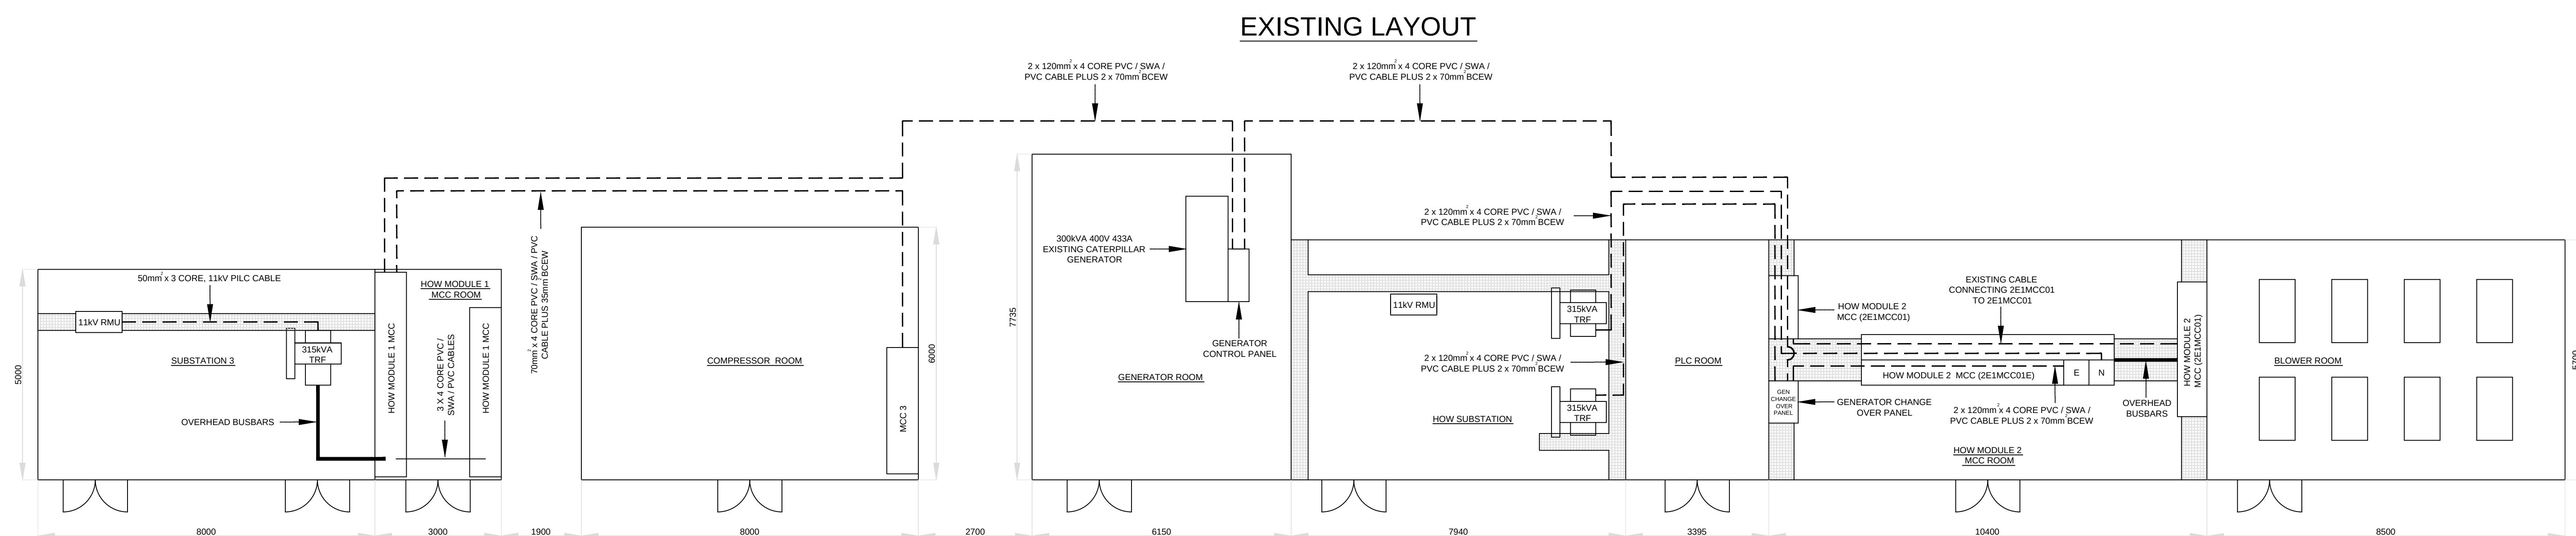

DEPARTMENT	APPROVED	DESIGNATION	DATE

CONSULTING ENGINEERS

ZITHOLELE
C O N S U L T I N G

ZITHOLELE
P.O. BOX 6002
HALFWAY HOUSE
1685
TEL. 011-254 4800
FAX. 011-805 2100
EMAIL mail@zitholele.co.za

SURVEYED	
DESIGNED	
DRAWN	
CHECKED	
SERVICES CHECKED	
GEOTECHNICAL INVESTIGATION	
SERVITUDES	
APPROVED	DMcD
Pr. Eng. No.	200270017
DATE	FEBRUARY 2024

JOHANNESBURG WATER (PTY) LTD



17 HARRISON STREET
MARSHALLTOWN
2107

TEL: (011) 688-1400
FAX: (011) 688-1529

CITY OF JOHANNESBURG

BUSHKOPPIE WASTEWATER TREATMENT WORKS

INFRASTRUCTURE RENEWAL PLAN
HOW LV RETICULATION

DESIGN MANAGER

DATE: FEB 24

SCALE

1.00

AMENDMENTS

T00	
-----	--

T01	
-----	--

ISSUED FOR TENDER

ISSUED FOR TENDER

APPROVED

DMcD

DMcD

DATE	
------	--

FEB 24

MAR 24

DRAWING No.

JW NUMBER


CONSULTANT'S NUMBER


CONSULTANT'S NUMBER
18056-73-12-15

FILE No
10050

1	8	0	5	6					
---	---	---	---	---	--	--	--	--	--

				T	O	
--	--	--	--	---	---	--

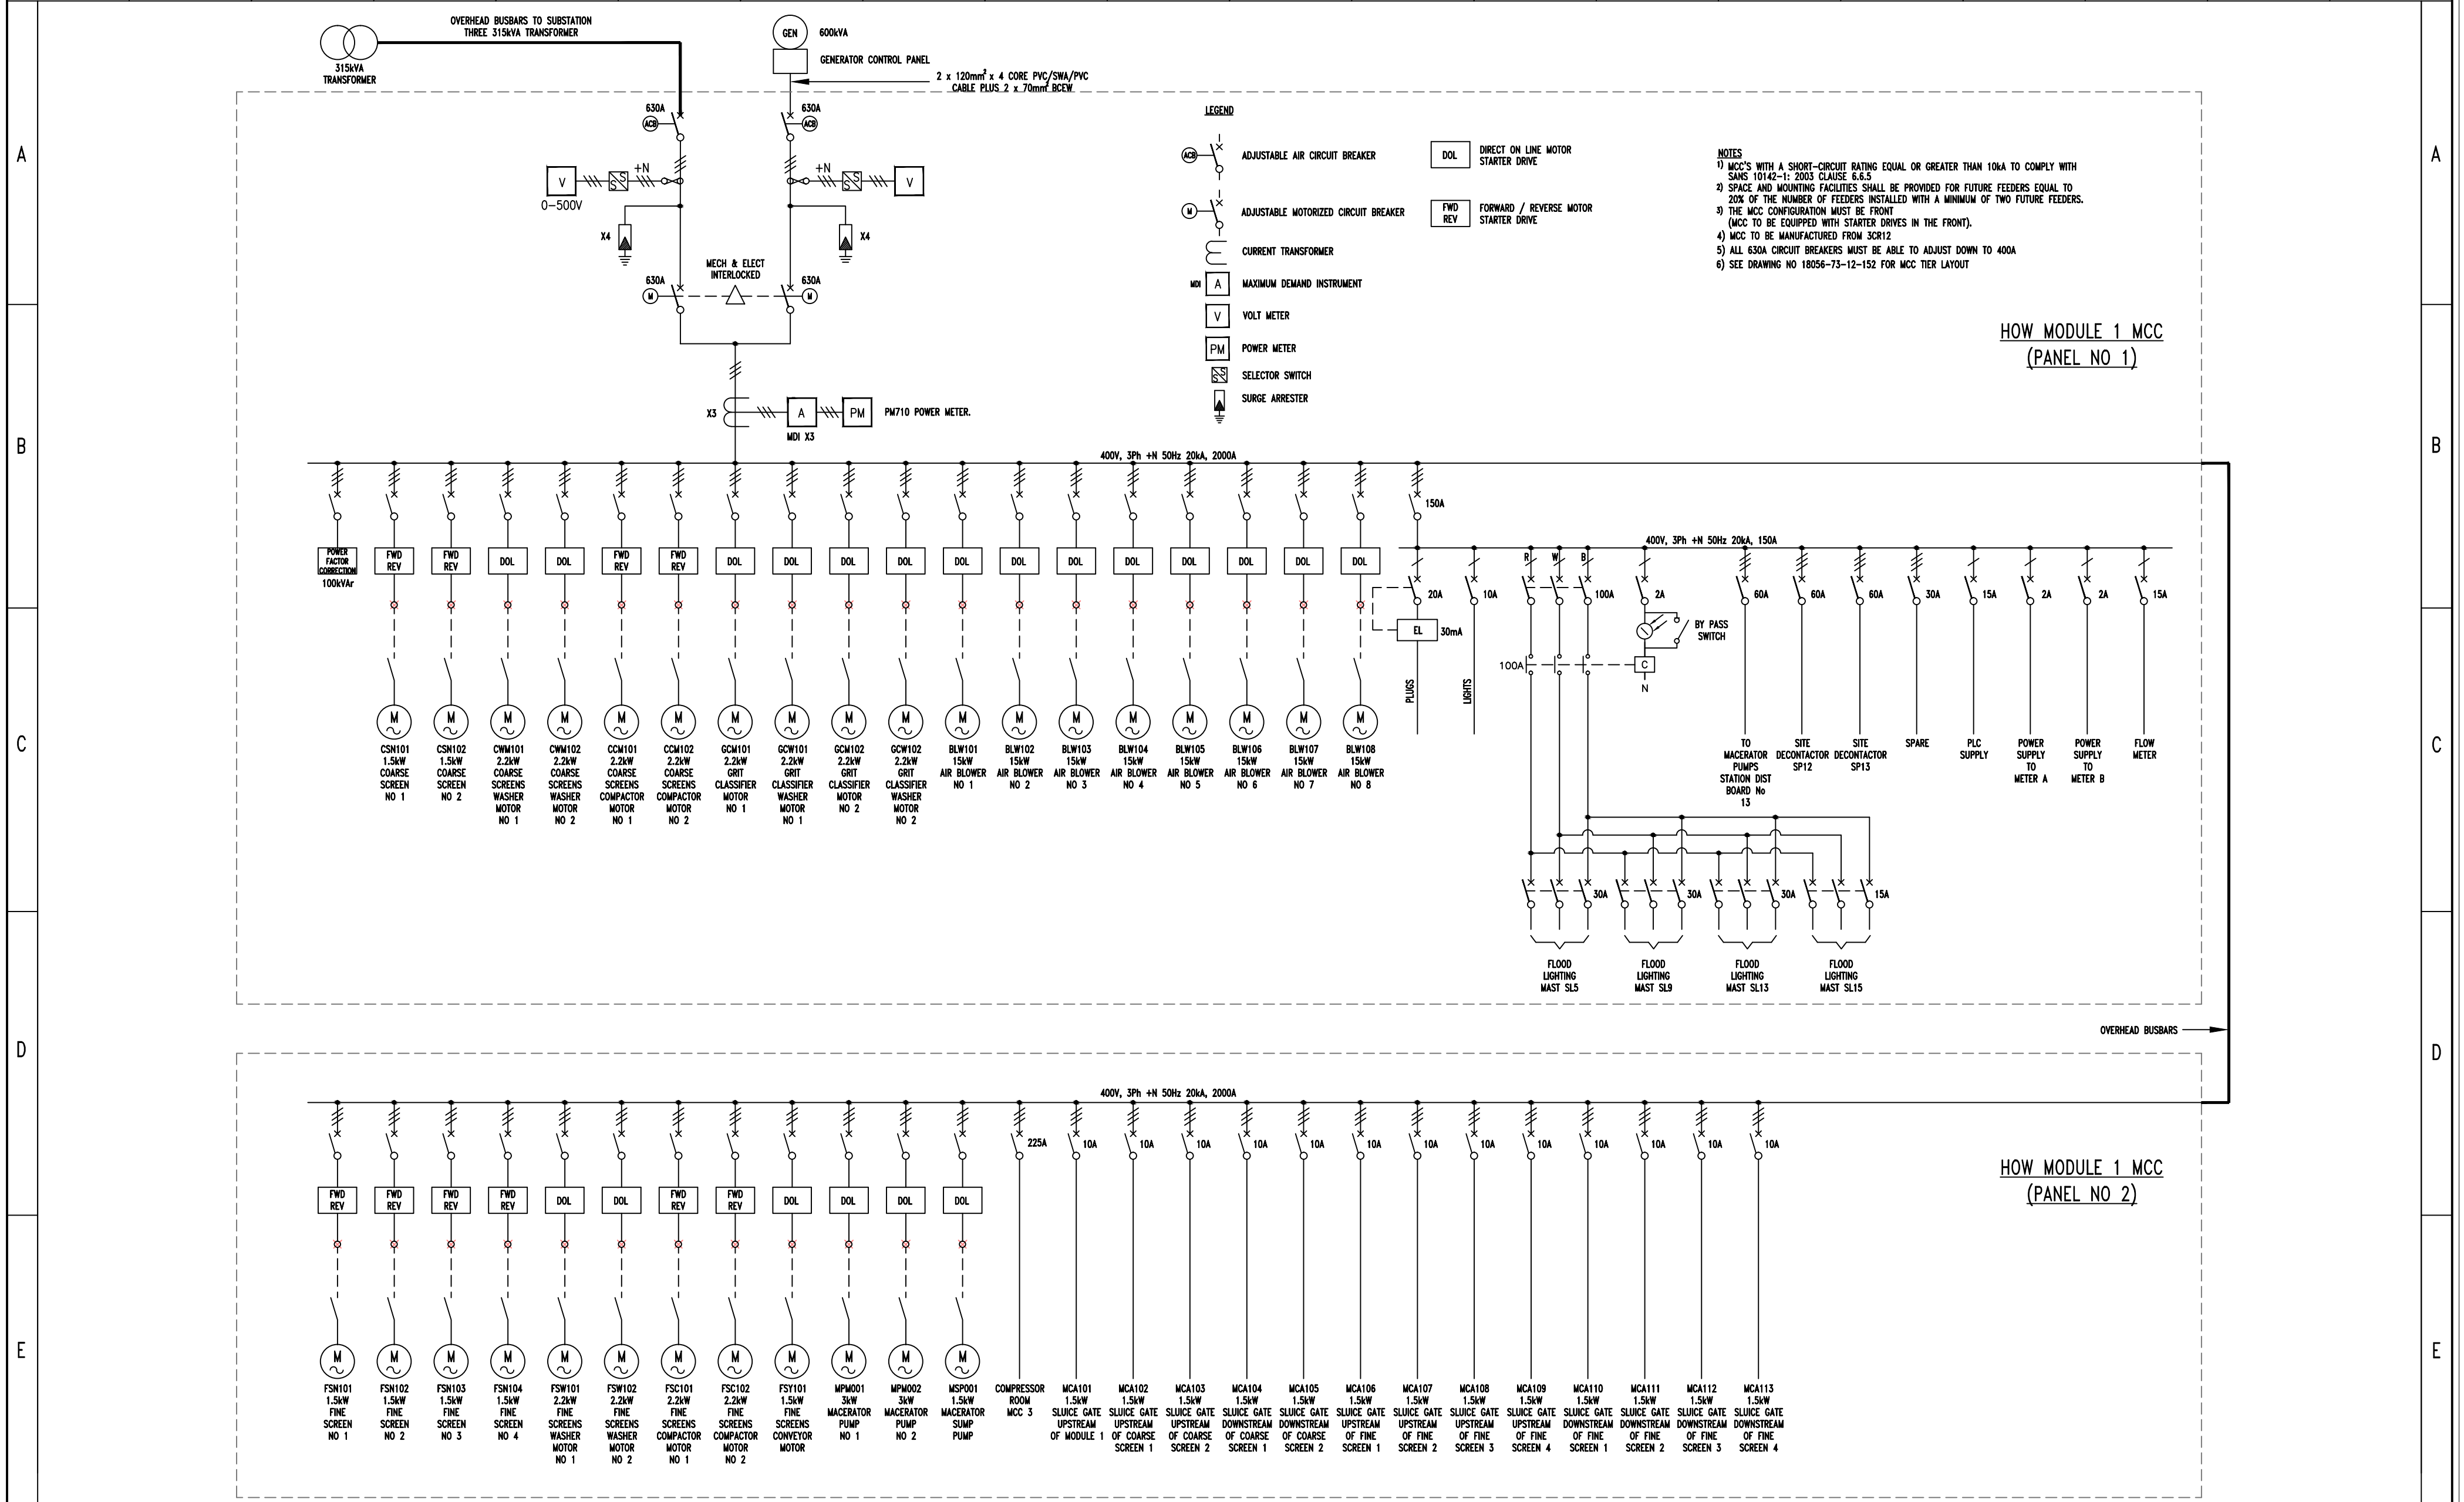

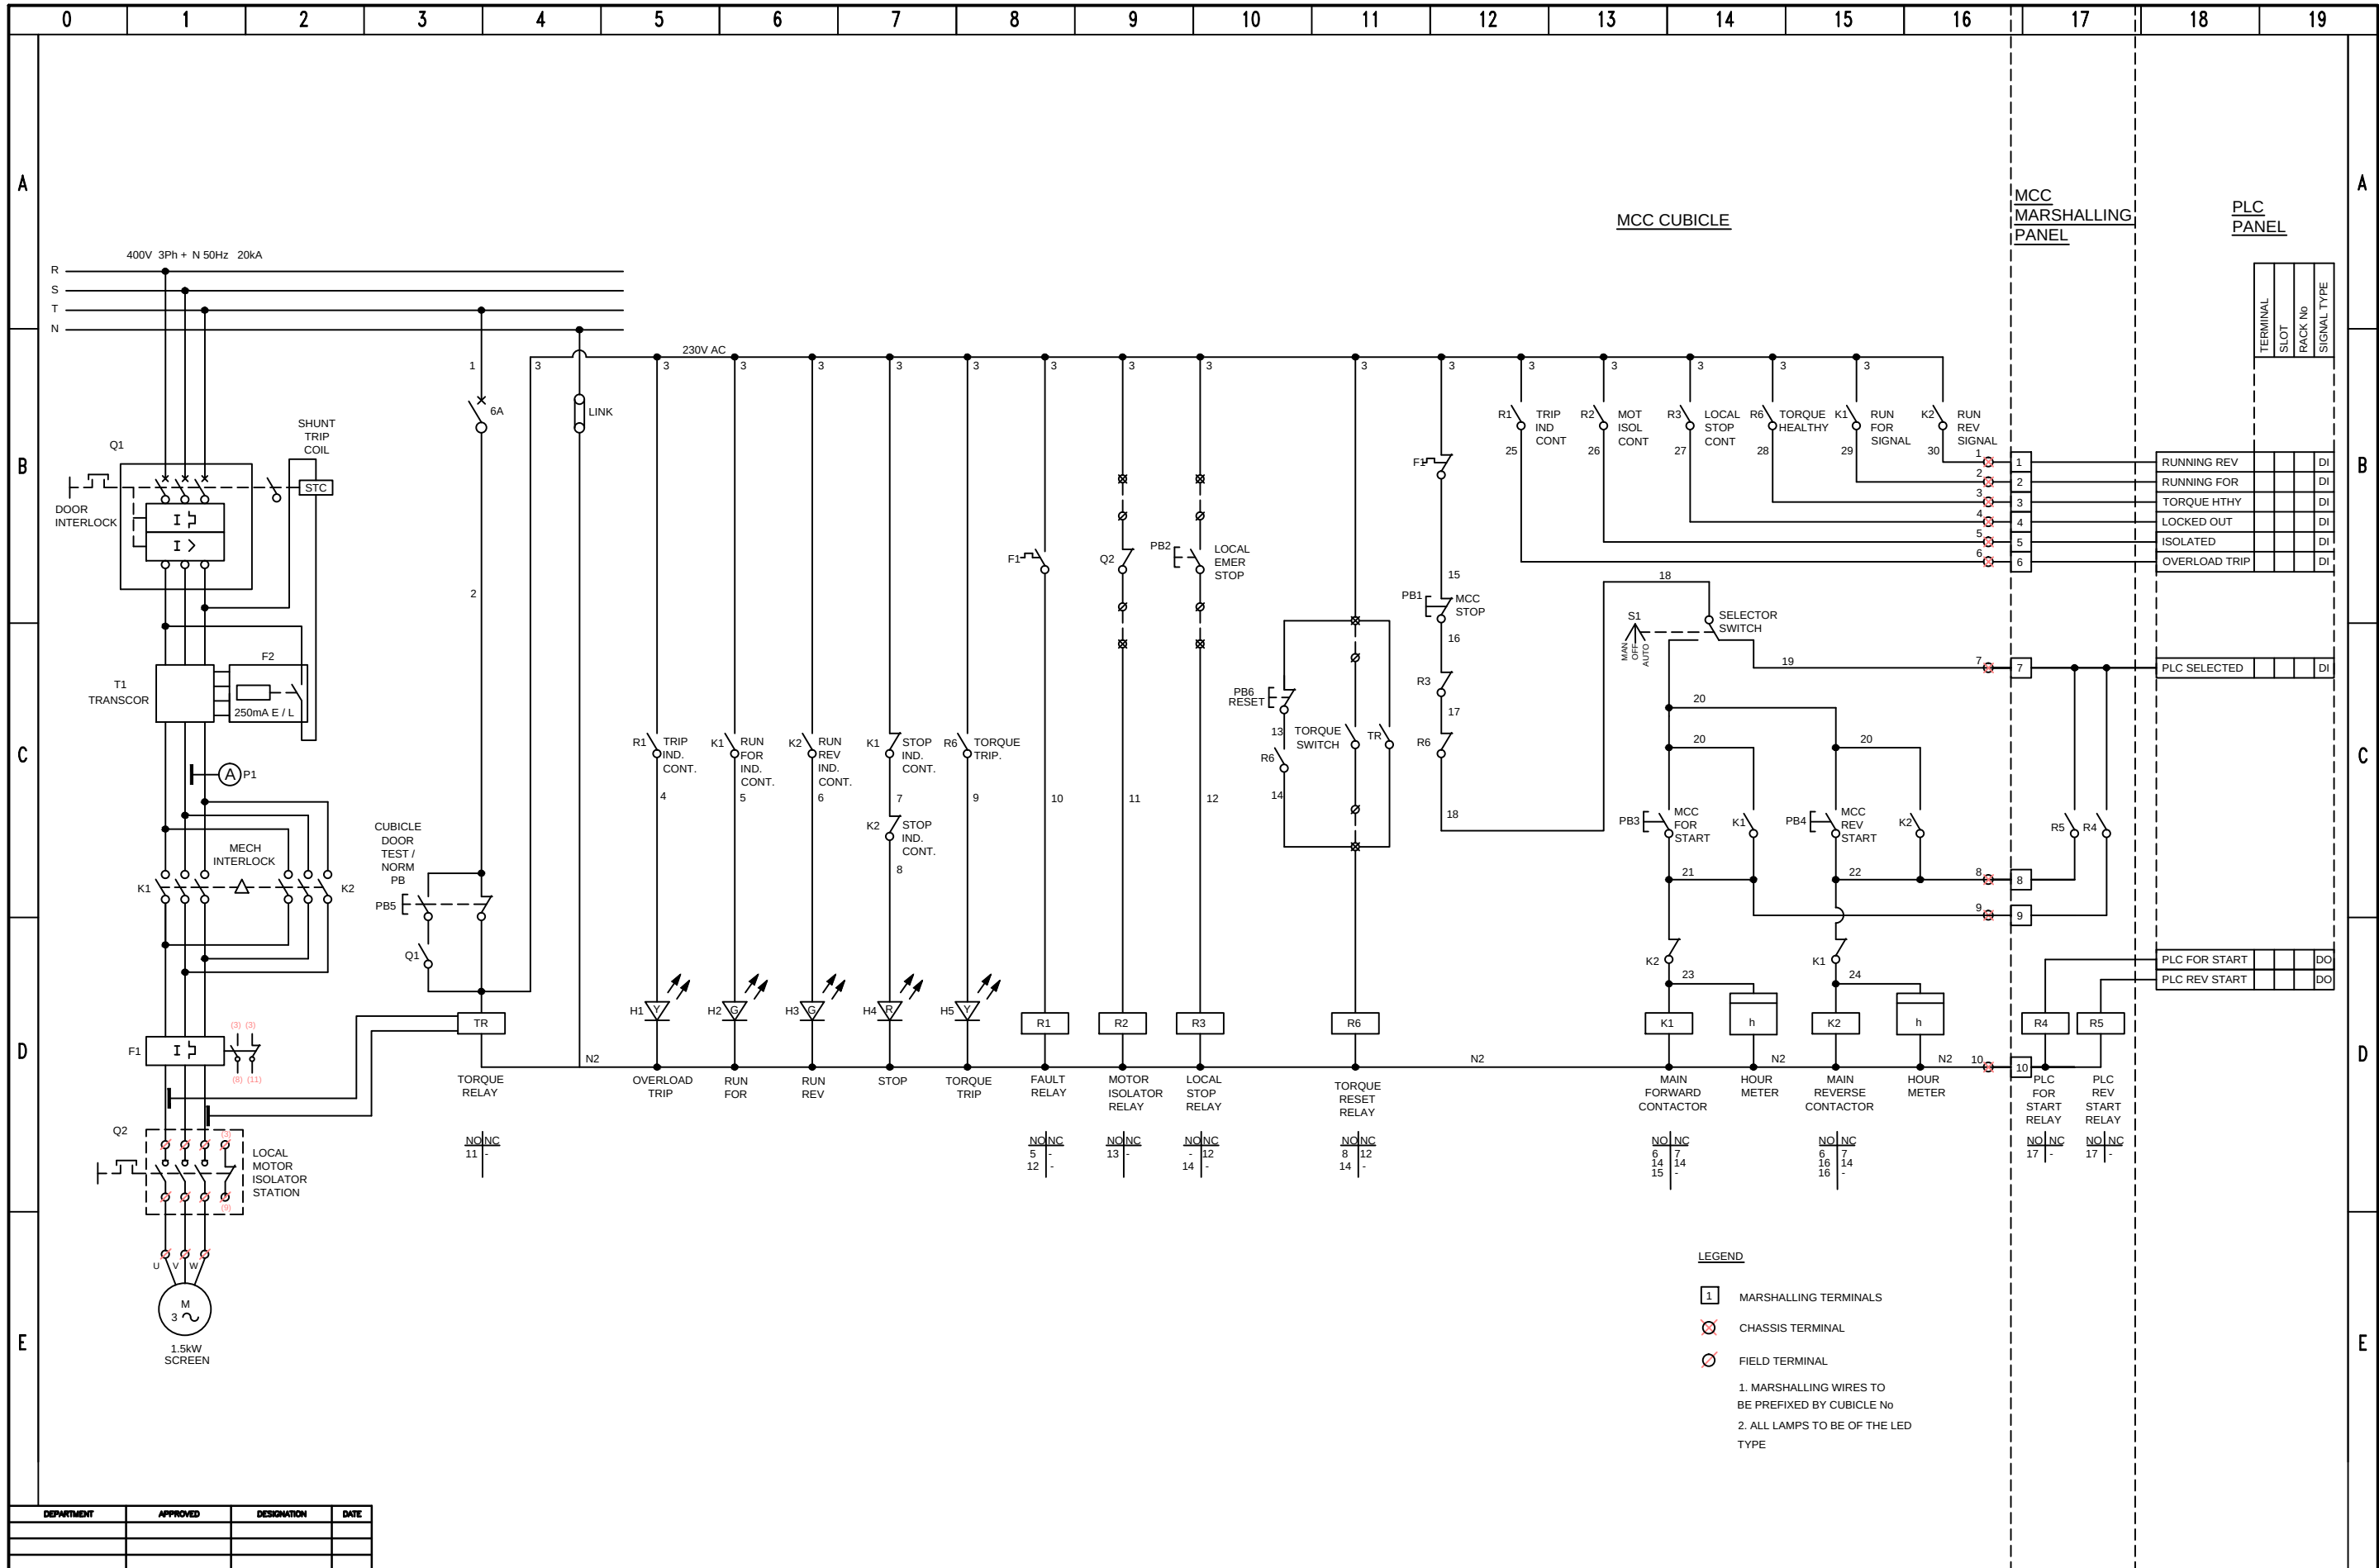

DEPARTMENT	APPROVED	DESIGNATION	DATE

BUSHKOPPIE WWTW IRP: 400V POWER CABLE SCHEDULES

DRG NO: 18056-73-12-155

SHT 1 OF 26

(HOW Module 1 MCC)

REV: T00

MARCH 2024

CABLE NO	CABLE FED FROM	CABLE FEEDING TO	SIZE IN mm ²	NO OF CORES	TYPE	SEPARATE EARTH	EST LENGTH	LOAD Kw
HOW/M1/001/P/001	HOW MODULE 1 MCC	GENERATOR CHANGE OVER PANEL	2 x 120	4	PVC / SWA / PVC	2 x 70	43	
HOW/M1/002/P/001	HOW MODULE 1 MCC	Compressor Room MCC 3	95	4	PVC / SWA / PVC	35	33	
HOW/M2/001/P/001 EMERGENCY	HOW MODULE 2 315kVATRF No 2	GENERATOR CHANGE OVER PANEL	2 x 120	4	PVC / SWA / PVC	2 x 70	31	
HOW/M2/002/P/001 EMERGENCY	GENERATOR CHANGE OVER PANEL	HOW MODULE 2 MCC (2E1MCC01E)	2 x 120	4	PVC / SWA / PVC	2 x 70	34	
HOW/M2/003/P/001	HOW MODULE 2 315kVATRF No 1	HOW MODULE 2 MCC (2E1MCC01E)	2 x 120	4	PVC / SWA / PVC	2 x 70	31	
HOW/M2/004/P/001 EMERGENCY	HOW MODULE 2 MCC (2E1MCC01E) (GENERATOR SUPPLY)	NEW BLOWER ROOM MCC	150	4	PVC / SWA / PVC	70	170	
HOW/M2/005/P/001 NORMAL POWER	HOW MODULE 2 MCC (2E1MCC01) TRANSFORMER SUPPLY	NEW BLOWER ROOM MCC	150	4	PVC / SWA / PVC	70	170	
HOW/M1/003/P/001	HOW MODULE 1 MCC (FWD / REV)	LOCAL ISOLATOR COARSE SCREEN NO 1 CSN101	2.5	4	PVC / SWA / PVC	4th core	150	1.5
HOW/M1/003/P/002	LOCAL ISOLATOR COARSE SCREEN NO 1 CSN101	MOTOR COARSE SCREEN NO 1 CSN101	2.5	4	PVC / SWA / PVC	4th core	5	1.5
HOW/M1/004/P/001	HOW MODULE 1 MCC (FWD / REV)	LOCAL ISOLATOR COARSE SCREEN NO 2 CSN102	2.5	4	PVC / SWA / PVC	4th core	150	1.5
HOW/M1/004/P/002	LOCAL ISOLATOR COARSE SCREEN NO 2 CSN102	MOTOR COARSE SCREEN NO 2 CSN102	2.5	4	PVC / SWA / PVC	4th core	5	1.5
HOW/M1/005/P/001	HOW MODULE 1 MCC	LOCAL ISOLATOR COARSE SCREEN WASHER NO 1 CWM101	2.5	4	PVC / SWA / PVC	4th core	150	2.2
HOW/M1/005/P/002	LOCAL ISOLATOR COARSE SCREEN WASHER NO 1 CWM101	MOTOR COARSE SCREEN WASHER NO 1 CWM101	2.5	4	PVC / SWA / PVC	4th core	5	2.2

BUSHKOPPIE WWTW IRP: 400V POWER CABLE SCHEDULES

DRG NO: 18056-73-12-155

SHT 2 OF 26

(HOW Module 1 MCC)

REV: T00

MARCH 2024

CABLE NO	CABLE FED FROM	CABLE FEEDING TO	SIZE IN mm ²	NO OF CORES	TYPE	SEPARATE EARTH	EST LENGTH	LOAD Kw
HOW/M1/006/P/001	HOW MODULE 1 MCC	LOCAL ISOLATOR COARSE SCREEN WASHER NO 2 CWM102	2.5	4	PVC / SWA / PVC	4th core	150	2.2
HOW/M1/006/P/002	LOCAL ISOLATOR COARSE SCREEN WASHER NO 2 CWM102	MOTOR COARSE SCREEN WASHER NO 2 CWM102	2.5	4	PVC / SWA / PVC	4th core	5	2.2
HOW/M1/007/P/001	HOW MODULE 1 MCC (FWD / REV)	LOCAL ISOLATOR COARSE SCREEN COMPACTOR NO 1 CCM101	2.5	4	PVC / SWA / PVC	4th core	150	2.2
HOW/M1/007/P/002	LOCAL ISOLATOR COARSE SCREEN COMPACTOR NO 1 CCM101	MOTOR COARSE SCREEN COMPACTOR NO 1 CCM101	2.5	4	PVC / SWA / PVC	4th core	5	2.2
HOW/M1/008/P/001	HOW MODULE 1 MCC (FWD / REV)	LOCAL ISOLATOR COARSE SCREEN COMPACTOR NO 2 CCM102	2.5	4	PVC / SWA / PVC	4th core	150	2.2
HOW/M1/008/P/002	LOCAL ISOLATOR COARSE SCREEN COMPACTOR NO 2 CCM102	MOTOR COARSE SCREEN COMPACTOR NO 2 CCM102	2.5	4	PVC / SWA / PVC	4th core	5	2.2
HOW/M1/009/P/001	HOW MODULE 1 MCC	LOCAL ISOLATOR GRIT CLASSIFIER NO 1 GCM101	2.5	4	PVC / SWA / PVC	4th core	100	2.2
HOW/M1/009/P/002	LOCAL ISOLATOR GRIT CLASSIFIER NO 1 GCM101	MOTOR GRIT CLASSIFIER NO 1 GCM101	2.5	4	PVC / SWA / PVC	4th core	5	2.2
HOW/M1/010/P/001	HOW MODULE 1 MCC	LOCAL ISOLATOR GRIT CLASSIFIER WASHER NO 1 GCW101	2.5	4	PVC / SWA / PVC	4th core	100	2.2
HOW/M1/010/P/002	LOCAL ISOLATOR GRIT CLASSIFIER WASHER NO 1 GCW101	MOTOR GRIT CLASSIFIER WASHER NO 1 GCW101	2.5	4	PVC / SWA / PVC	4th core	5	2.2
HOW/M1/011/P/001	HOW MODULE 1 MCC	LOCAL ISOLATOR GRIT CLASSIFIER NO 2 GCM102	2.5	4	PVC / SWA / PVC	4th core	100	2.2
HOW/M1/011/P/002	LOCAL ISOLATOR GRIT CLASSIFIER NO 2 GCM102	MOTOR GRIT CLASSIFIER NO 2 GCM102	2.5	4	PVC / SWA / PVC	4th core	5	2.2

BUSHKOPPIE WWTW IRP: 400V POWER CABLE SCHEDULES

DRG NO: 18056-73-12-155

SHT 3 OF 26

(HOW Module 1 MCC)

REV: T00

MARCH 2024

CABLE NO	CABLE FED FROM	CABLE FEEDING TO	SIZE IN mm ²	NO OF CORES	TYPE	SEPARATE EARTH	EST LENGTH	LOAD Kw
HOW/M1/012/P/001	HOW MODULE 1 MCC	LOCAL ISOLATOR GRIT CLASSIFIER WASHER NO 2 GCW102	2.5	4	PVC / SWA / PVC	4th core	100	2.2
HOW/M1/012/P/002	LOCAL ISOLATOR GRIT CLASSIFIER WASHER NO 2 GCW102	MOTOR GRIT CLASSIFIER WASHER NO 2 GCW102	2.5	4	PVC / SWA / PVC	4th core	5	2.2
HOW/M1/013/P/001	HOW MODULE 1 MCC	LOCAL ISOLATOR AIR BLOWER NO 1	6	4	PVC / SWA / PVC	4th core	72	15
HOW/M1/013/P/002	LOCAL ISOLATOR AIR BLOWER NO 1	MOTOR AIR BLOWER NO 1	6	4	PVC / SWA / PVC	4th core	5	15
HOW/M1/014/P/001	HOW MODULE 1 MCC	LOCAL ISOLATOR AIR BLOWER NO 2	6	4	PVC / SWA / PVC	4th core	72	15
HOW/M1/014/P/002	LOCAL ISOLATOR AIR BLOWER NO 2	MOTOR AIR BLOWER NO 2	6	4	PVC / SWA / PVC	4th core	5	15
HOW/M1/015/P/001	HOW MODULE 1 MCC	LOCAL ISOLATOR AIR BLOWER NO 3	6	4	PVC / SWA / PVC	4th core	72	15
HOW/M1/015/P/002	LOCAL ISOLATOR AIR BLOWER NO 3	MOTOR AIR BLOWER NO 3	6	4	PVC / SWA / PVC	4th core	5	15
HOW/M1/016/P/001	HOW MODULE 1 MCC	LOCAL ISOLATOR AIR BLOWER NO 4	6	4	PVC / SWA / PVC	4th core	72	15
HOW/M1/016/P/002	LOCAL ISOLATOR AIR BLOWER NO 4	MOTOR AIR BLOWER NO 4	6	4	PVC / SWA / PVC	4th core	5	15
HOW/M1/017/P/001	HOW MODULE 1 MCC	LOCAL ISOLATOR AIR BLOWER NO 5	6	4	PVC / SWA / PVC	4th core	72	15
HOW/M1/017/P/002	LOCAL ISOLATOR AIR BLOWER NO 5	MOTOR AIR BLOWER NO 5	6	4	PVC / SWA / PVC	4th core	5	15

BUSHKOPPIE WWTW IRP: 400V POWER CABLE SCHEDULES

DRG NO: 18056-73-12-155

SHT 4 OF 26

(HOW Module 1 MCC)

REV: T00

MARCH 2024

CABLE NO	CABLE FED FROM	CABLE FEEDING TO	SIZE IN mm ²	NO OF CORES	TYPE	SEPARATE EARTH	EST LENGTH	LOAD Kw
HOW/M1/018/P/001	HOW MODULE 1 MCC	LOCAL ISOLATOR AIR BLOWER NO 6	6	4	PVC / SWA / PVC	4th core	72	15
HOW/M1/018/P/002	LOCAL ISOLATOR AIR BLOWER NO 6	MOTOR AIR BLOWER NO 6	6	4	PVC / SWA / PVC	4th core	5	15
HOW/M1/019/P/001	HOW MODULE 1 MCC	LOCAL ISOLATOR AIR BLOWER NO 7	6	4	PVC / SWA / PVC	4th core	72	15
HOW/M1/019/P/002	LOCAL ISOLATOR AIR BLOWER NO 7	MOTOR AIR BLOWER NO 7	6	4	PVC / SWA / PVC	4th core	5	15
HOW/M1/020/P/001	HOW MODULE 1 MCC	LOCAL ISOLATOR AIR BLOWER NO 8	6	4	PVC / SWA / PVC	4th core	72	15
HOW/M1/020/P/002	LOCAL ISOLATOR AIR BLOWER NO 8	MOTOR AIR BLOWER NO 8	6	4	PVC / SWA / PVC	4th core	5	15
HOW/M1/021/P/001	HOW MODULE 1 MCC (FWD / REV)	LOCAL ISOLATOR FINE SCREEN NO 1 FSN101	2.5	4	PVC / SWA / PVC	4th core	120	1.5
HOW/M1/021/P/002	LOCAL ISOLATOR FINE SCREEN NO 1 FSN101	MOTOR FINE SCREEN NO 1 FSN101	2.5	4	PVC / SWA / PVC	4th core	5	1.5
HOW/M1/022/P/001	HOW MODULE 1 MCC (FWD / REV)	LOCAL ISOLATOR FINE SCREEN NO 2 FSN102	2.5	4	PVC / SWA / PVC	4th core	120	1.5
HOW/M1/022/P/002	LOCAL ISOLATOR FINE SCREEN NO 2 FSN102	MOTOR FINE SCREEN NO 2 FSN102	2.5	4	PVC / SWA / PVC	4th core	5	1.5
HOW/M1/023/P/001	HOW MODULE 1 MCC (FWD / REV)	LOCAL ISOLATOR FINE SCREEN NO 3 FSN103	2.5	4	PVC / SWA / PVC	4th core	120	1.5
HOW/M1/023/P/002	LOCAL ISOLATOR FINE SCREEN NO 3 FSN103	MOTOR FINE SCREEN NO 3 FSN103	2.5	4	PVC / SWA / PVC	4th core	5	1.5

BUSHKOPPIE WWTW IRP: 400V POWER CABLE SCHEDULES

DRG NO: 18056-73-12-155

SHT 5 OF 26

(HOW Module 1 MCC)

REV: T00

MARCH 2024

CABLE NO	CABLE FED FROM	CABLE FEEDING TO	SIZE IN mm ²	NO OF CORES	TYPE	SEPARATE EARTH	EST LENGTH	LOAD Kw
HOW/M1/024/P/001	HOW MODULE 1 MCC (FWD / REV)	LOCAL ISOLATOR FINE SCREEN NO 4 FSN104	2.5	4	PVC / SWA / PVC	4th core	120	1.5
HOW/M1/024/P/002	LOCAL ISOLATOR FINE SCREEN NO 4 FSN104	MOTOR FINE SCREEN NO 4 FSN104	2.5	4	PVC / SWA / PVC	4th core	5	1.5
HOW/M1/025/P/001	HOW MODULE 1 MCC	LOCAL ISOLATOR FINE SCREEN WASHER NO 1 FSW101	2.5	4	PVC / SWA / PVC	4th core	120	2.2
HOW/M1/025/P/002	LOCAL ISOLATOR FINE SCREEN WASHER NO 1 FSW101	MOTOR FINE SCREEN WASHER NO 1 FSW101	2.5	4	PVC / SWA / PVC	4th core	5	2.2
HOW/M1/026/P/001	HOW MODULE 1 MCC	LOCAL ISOLATOR FINE SCREEN WASHER NO 2 FSW102	2.5	4	PVC / SWA / PVC	4th core	120	2.2
HOW/M1/026/P/002	LOCAL ISOLATOR FINE SCREEN WASHER NO 2 FSW102	MOTOR FINE SCREEN WASHER NO 2 FSW102	2.5	4	PVC / SWA / PVC	4th core	5	2.2
HOW/M1/027/P/001	HOW MODULE 1 MCC (FWD / REV)	LOCAL ISOLATOR FINE SCREEN COMPACTOR NO 1 FSC101	2.5	4	PVC / SWA / PVC	4th core	120	2.2
HOW/M1/027/P/002	LOCAL ISOLATOR FINE SCREEN COMPACTOR NO 1 FSC101	MOTOR FINE SCREEN COMPACTOR NO 1 FSC101	2.5	4	PVC / SWA / PVC	4th core	5	2.2
HOW/M1/028/P/001	HOW MODULE 1 MCC (FWD / REV)	LOCAL ISOLATOR FINE SCREEN COMPACTOR NO 2 FSC102	2.5	4	PVC / SWA / PVC	4th core	120	2.2
HOW/M1/028/P/002	LOCAL ISOLATOR FINE SCREEN COMPACTOR NO 2 FSC102	MOTOR FINE SCREEN COMPACTOR NO 2 FSC102	2.5	4	PVC / SWA / PVC	4th core	5	2.2
HOW/M1/029/P/001	HOW MODULE 1 MCC	LOCAL ISOLATOR FINE SCREEN CONVEYOR FSY101	2.5	4	PVC / SWA / PVC	4th core	120	1.5
HOW/M1/029/P/002	LOCAL ISOLATOR FINE SCREEN CONVEYOR FSY101	MOTOR FINE SCREEN CONVEYOR FSY101	2.5	4	PVC / SWA / PVC	4th core	5	1.5

BUSHKOPPIE WWTW IRP: 400V POWER CABLE SCHEDULES

DRG NO: 18056-73-12-155

SHT 6 OF 26

(HOW Module 1 MCC)

REV: T00

MARCH 2024

CABLE NO	CABLE FED FROM	CABLE FEEDING TO	SIZE IN mm ²	NO OF CORES	TYPE	SEPARATE EARTH	EST LENGTH	LOAD Kw
HOW/M1/030/P/001	HOW MODULE 1 MCC	LOCAL ISOLATOR MACERATOR NO 1 MPM001	2.5	4	PVC / SWA / PVC	4th core	120	3
HOW/M1/030/P/002	LOCAL ISOLATOR MACERATOR NO 1 MPM001	MOTOR MACERATOR NO 1 MPM001	2.5	4	PVC / SWA / PVC	4th core	5	3
HOW/M1/031/P/001	HOW MODULE 1 MCC	LOCAL ISOLATOR MACERATOR NO 2 MPM002	2.5	4	PVC / SWA / PVC	4th core	120	3
HOW/M1/031/P/002	LOCAL ISOLATOR MACERATOR NO 2 MPM002	MOTOR MACERATOR NO 2 MPM002	2.5	4	PVC / SWA / PVC	4th core	5	3
HOW/M1/032/P/001	HOW MODULE 1 MCC	LOCAL ISOLATOR MACERATOR SUMP PUMP MSP001	2.5	4	PVC / SWA / PVC	4th core	120	1.5
HOW/M1/032/P/002	LOCAL ISOLATOR MACERATOR SUMP PUMP MSP001	MOTOR MACERATOR SUMP PUMP MSP001	2.5	4	PVC / SWA / PVC	4th core	5	1.5
HOW/M1/033/P/001	HOW MODULE 1 MCC	SLUICE GATE UPSTREAM OF MODULE 1 ACTUATOR MCA101	2.5	4	PVC / SWA / PVC	4th core	120	1.5
HOW/M1/034/P/001	HOW MODULE 1 MCC	SLUICE GATE UPSTREAM OF COARSE SCREEN 1 ACTUATOR MCA102	2.5	4	PVC / SWA / PVC	4th core	120	1.5
HOW/M1/035/P/001	HOW MODULE 1 MCC	SLUICE GATE UPSTREAM OF COARSE SCREEN 2 ACTUATOR MCA103	2.5	4	PVC / SWA / PVC	4th core	120	1.5
HOW/M1/036/P/001	HOW MODULE 1 MCC	SLUICE GATE DWSTREAM OF COARSE SCREEN 1 ACTUATOR MCA104	2.5	4	PVC / SWA / PVC	4th core	120	1.5
HOW/M1/037/P/001	HOW MODULE 1 MCC	SLUICE GATE DWSTREAM OF COARSE SCREEN 2 ACTUATOR MCA105	2.5	4	PVC / SWA / PVC	4th core	120	1.5
HOW/M1/038/P/001	HOW MODULE 1 MCC	SLUICE GATE UPSTREAM OF FINE SCREEN 1 ACTUATOR MCA106	2.5	4	PVC / SWA / PVC	4th core	120	1.5

BUSHKOPPIE WWTW IRP: 400V POWER CABLE SCHEDULES				
DRG NO: 18056-73-12-155	SHT 7 OF 26	(HOW Module 1 MCC)	REV: T00	MARCH 2024

CABLE NO

CABLE FED FROM

CABLE FEEDING TO

TYPE	SEPARATE EARTH
------	----------------

EST LENGTH	LOAD Kw
---------------	------------

[illegible]

BUSHKOPPIE WWTW IRP: 400V POWER CABLE SCHEDULES

DRG NO: 18056-73-12-155

SHT 8 OF 26

(HOW Module 2 MCC)

REV: T00

MARCH 2024

CABLE NO	CABLE FED FROM	CABLE FEEDING TO	SIZE IN mm ²	NO OF CORES	TYPE	SEPARATE EARTH	EST LENGTH	LOAD Kw
HOW/M2/006/P/001	HOW MODULE 2 MCC	LOCAL ISOLATOR GRIT CLASSIFIER NO 1 GCM201	2.5	4	PVC / SWA / PVC	4th core	100	2.2
HOW/M2/006/P/002	LOCAL ISOLATOR GRIT CLASSIFIER NO 1 GCM201	MOTOR GRIT CLASSIFIER NO 1 GCM201	2.5	4	PVC / SWA / PVC	4th core	5	2.2
HOW/M2/007/P/001	HOW MODULE 2 MCC	LOCAL ISOLATOR GRIT CLASSIFIER WASHER NO 1 GCW201	2.5	4	PVC / SWA / PVC	4th core	100	2.2
HOW/M2/007/P/002	LOCAL ISOLATOR GRIT CLASSIFIER WASHER NO 1 GCW201	MOTOR GRIT CLASSIFIER WASHER NO 1 GCW201	2.5	4	PVC / SWA / PVC	4th core	5	2.2
HOW/M2/008/P/001	HOW MODULE 2 MCC	LOCAL ISOLATOR GRIT CLASSIFIER NO 2 GCM202	2.5	4	PVC / SWA / PVC	4th core	100	2.2
HOW/M2/008/P/002	LOCAL ISOLATOR GRIT CLASSIFIER NO 2 GCM202	MOTOR GRIT CLASSIFIER NO 2 GCM202	2.5	4	PVC / SWA / PVC	4th core	5	2.2
HOW/M2/009/P/001	HOW MODULE 2 MCC	LOCAL ISOLATOR GRIT CLASSIFIER WASHER NO 2 GCW202	2.5	4	PVC / SWA / PVC	4th core	100	2.2
HOW/M2/009/P/002	LOCAL ISOLATOR GRIT CLASSIFIER WASHER NO 2 GCW202	MOTOR GRIT CLASSIFIER WASHER NO 2 GCW202	2.5	4	PVC / SWA / PVC	4th core	5	2.2
HOW/M2/010/P/001	HOW MODULE 2 MCC	LOCAL ISOLATOR GRIT CONVEYOR GCY201	2.5	4	PVC / SWA / PVC	4th core	100	2.2
HOW/M2/010/P/002	LOCAL ISOLATOR GRIT CONVEYOR GCY201	MOTOR GRIT CONVEYOR GCY201	2.5	4	PVC / SWA / PVC	4th core	5	2.2
HOW/M2/011/P/001	HOW MODULE 2 MCC	LOCAL ISOLATOR GRIT BIN SELECTOR GBS201	2.5	4	PVC / SWA / PVC	4th core	100	2.2
HOW/M2/011/P/002	LOCAL ISOLATOR GRIT BIN SELECTOR GBS201	MOTOR GRIT BIN SELECTOR GBS201	2.5	4	PVC / SWA / PVC	4th core	5	2.2

BUSHKOPPIE WWTW IRP: 400V POWER CABLE SCHEDULES				
DRG NO: 18056-73-12-155	SHT 9 OF 26	(HOW Module 2 MCC)	REV: T00	MARCH 2024

CABLE NO

CABLE FED FROM

CABLE FEEDING TO

TYPE	SEPARATE EARTH
------	----------------

EST LENGTH	LOAD Kw
---------------	------------

[illegible]

BUSHKOPPIE WWTW IRP: 400V POWER CABLE SCHEDULES				
DRG NO: 18056-73-12-155	SHT 10 OF 26	(HOW Module 1 Compressor MCC)	REV: T00	MARCH 2024

BUSHKOPPIE WWTW IRP: 400V POWER CABLE SCHEDULES				
DRG NO: 18056-73-12-155	SHT 10 OF 26	(HOW Module 1 Compressor MCC)	REV: T00	MARCH 2024

BUSHKOPPIE WWTW IRP: 400V POWER CABLE SCHEDULES				
DRG NO: 18056-73-12-155	SHT 10 OF 26	(HOW Module 1 Compressor MCC)	REV: T00	MARCH 2024

BUSHKOPPIE WWTW IRP: 400V POWER CABLE SCHEDULES				
DRG NO: 18056-73-12-155	SHT 10 OF 26	(HOW Module 1 Compressor MCC)	REV: T00	MARCH 2024

BUSHKOPPIE WWTW IRP: 400V POWER CABLE SCHEDULES				
DRG NO: 18056-73-12-155	SHT 10 OF 26	(HOW Module 1 Compressor MCC)	REV: T00	MARCH 2024

BUSHKOPPIE WWTW IRP: 400V POWER CABLE SCHEDULES				
DRG NO: 18056-73-12-155	SHT 10 OF 26	(HOW Module 1 Compressor MCC)	REV: T00	MARCH 2024

[illegible]

BUSHKOPPIE WWTW IRP: 400V POWER CABLE SCHEDULES

DRG NO: 18056-73-12-155

SHT 11 OF 26

(M2 New Blower Room MCC)

REV: T00

MARCH 2024

CABLE NO	CABLE FED FROM	CABLE FEEDING TO	SIZE IN mm ²	NO OF CORES	TYPE	SEPARATE EARTH	EST LENGTH	LOAD Kw
BLW/M2/001/P/001	NEW BLOWER ROOM MCC	LOCAL ISOLATOR AIR BLOWER NO 1 BLW201	6	4	PVC / SWA / PVC	4th core	13	15
BLW/M2/001/P/002	LOCAL ISOLATOR AIR BLOWER NO 1 BLW201	MOTOR AIR BLOWER NO 1 BLW201	6	4	PVC / SWA / PVC	4th core	5	15
BLW/M2/002/P/001	NEW BLOWER ROOM MCC	LOCAL ISOLATOR AIR BLOWER NO 2 BLW202	6	4	PVC / SWA / PVC	4th core	13	15
BLW/M2/002/P/002	LOCAL ISOLATOR AIR BLOWER NO 2 BLW202	MOTOR AIR BLOWER NO 2 BLW202	6	4	PVC / SWA / PVC	4th core	5	15
BLW/M2/003/P/001	NEW BLOWER ROOM MCC	LOCAL ISOLATOR AIR BLOWER NO 3 BLW203	6	4	PVC / SWA / PVC	4th core	15	15
BLW/M2/003/P/002	LOCAL ISOLATOR AIR BLOWER NO 3 BLW203	MOTOR AIR BLOWER NO 3 BLW203	6	4	PVC / SWA / PVC	4th core	5	15
BLW/M2/004/P/001	NEW BLOWER ROOM MCC	LOCAL ISOLATOR AIR BLOWER NO 4 BLW204	6	4	PVC / SWA / PVC	4th core	15	15
BLW/M2/004/P/002	LOCAL ISOLATOR AIR BLOWER NO 4 BLW204	MOTOR AIR BLOWER NO 4 BLW204	6	4	PVC / SWA / PVC	4th core	5	15
BLW/M2/005/P/001	NEW BLOWER ROOM MCC	LOCAL ISOLATOR AIR BLOWER NO 5 BLW205	6	4	PVC / SWA / PVC	4th core	18	15
BLW/M2/005/P/002	LOCAL ISOLATOR AIR BLOWER NO 5 BLW205	MOTOR AIR BLOWER NO 5 BLW205	6	4	PVC / SWA / PVC	4th core	5	15
BLW/M2/006/P/001	NEW BLOWER ROOM MCC	LOCAL ISOLATOR AIR BLOWER NO 6 BLW206	6	4	PVC / SWA / PVC	4th core	18	15
BLW/M2/006/P/002	LOCAL ISOLATOR AIR BLOWER NO 6 BLW206	MOTOR AIR BLOWER NO 6 BLW206	6	4	PVC / SWA / PVC	4th core	5	15

BUSHKOPPIE WWTW IRP: 400V POWER CABLE SCHEDULES

DRG NO: 18056-73-12-155

SHT 12 OF 26

(M2 New Blower Room MCC)

REV: T00

MARCH 2024

CABLE NO	CABLE FED FROM	CABLE FEEDING TO	SIZE IN mm ²	NO OF CORES	TYPE	SEPARATE EARTH	EST LENGTH	LOAD Kw
BLW/M2/007/P/001	NEW BLOWER ROOM MCC	LOCAL ISOLATOR AIR BLOWER NO 7 BLW207	6	4	PVC / SWA / PVC	4th core	20	15
BLW/M2/007/P/002	LOCAL ISOLATOR AIR BLOWER NO 7 BLW207	MOTOR AIR BLOWER NO 7 BLW207	6	4	PVC / SWA / PVC	4th core	5	15
BLW/M2/008/P/001	NEW BLOWER ROOM MCC	LOCAL ISOLATOR AIR BLOWER NO 8 BLW208	6	4	PVC / SWA / PVC	4th core	20	15
BLW/M2/008/P/002	LOCAL ISOLATOR AIR BLOWER NO 8 BLW208	MOTOR AIR BLOWER NO 8 BLW208	6	4	PVC / SWA / PVC	4th core	5	15
BLW/M2/009/P/001	NEW BLOWER ROOM MCC	LOCAL ISOLATOR AIR COMPRESSOR NO 1 CMP201	6	4	PVC / SWA / PVC	4th core	10	15
BLW/M2/009/P/002	LOCAL ISOLATOR AIR COMPRESSOR NO 1 CMP201	MOTOR AIR COMPRESSOR NO 1 CMP201	6	4	PVC / SWA / PVC	4th core	5	15
BLW/M2/010/P/001	NEW BLOWER ROOM MCC	LOCAL ISOLATOR AIR COMPRESSOR NO 2 CMP202	6	4	PVC / SWA / PVC	4th core	10	15
BLW/M2/010/P/002	LOCAL ISOLATOR AIR COMPRESSOR NO 2 CMP202	MOTOR AIR COMPRESSOR NO 2 CMP202	6	4	PVC / SWA / PVC	4th core	5	15
BLW/M2/011/P/001	NEW BLOWER ROOM MCC	LOCAL ISOLATOR INLET WORKS TRASH SCREEN ITS001	4	4	PVC / SWA / PVC	4th core	195	2.2
BLW/M2/011/P/002	LOCAL ISOLATOR INLET WORKS TRASH SCREEN ITS001	MOTOR INLET WORKS TRASH SCREEN ITS001	4	4	PVC / SWA / PVC	4th core	5	2.2
BLW/M2/012/P/001	NEW BLOWER ROOM MCC	LOCAL ISOLATOR MCC ROOM FAN BBF201	2.5	4	PVC / SWA / PVC	4th core	7	1.1
BLW/M2/012/P/002	LOCAL ISOLATOR MCC ROOM FAN BBF201	FAN MOTOR MCC ROOM FAN BBF201	2.5	4	PVC / SWA / PVC	4th core	1	1.1

BUSHKOPPIE WWTW IRP: 400V POWER CABLE SCHEDULES

DRG NO: 18056-73-12-155

SHT 13 OF 26

(M2 New Blower Room MCC)

REV: T00

MARCH 2024

CABLE NO	CABLE FED FROM	CABLE FEEDING TO	SIZE IN mm ²	NO OF CORES	TYPE	SEPARATE EARTH	EST LENGTH	LOAD Kw
BLW/M2/013/P/001	NEW BLOWER ROOM MCC	LOCAL ISOLATOR WW BOOSTER PUMP NO 1 MODULE 1 PMP101	10	4	PVC / SWA / PVC	4th core	45	22
BLW/M2/013/P/002	LOCAL ISOLATOR WW BOOSTER PUMP NO 1 MODULE 1 PMP101	MOTOR WW BOOSTER PUMP NO 1 MODULE 1 PMP101	10	4	PVC / SWA / PVC	4th core	5	22
BLW/M2/014/P/001	NEW BLOWER ROOM MCC	LOCAL ISOLATOR WW BOOSTER PUMP NO 2 MODULE 1 PMP102	10	4	PVC / SWA / PVC	4th core	45	22
BLW/M2/014/P/002	LOCAL ISOLATOR WW BOOSTER PUMP NO 2 MODULE 1 PMP102	MOTOR WW BOOSTER PUMP NO 2 MODULE 1 PMP102	10	4	PVC / SWA / PVC	4th core	5	22
BLW/M2/015/P/001	NEW BLOWER ROOM MCC	LOCAL ISOLATOR WW BOOSTER PUMP NO 1 MODULE 2 PMP201	10	4	PVC / SWA / PVC	4th core	45	22
BLW/M2/015/P/002	LOCAL ISOLATOR WW BOOSTER PUMP NO 1 MODULE 2 PMP201	MOTOR WW BOOSTER PUMP NO 1 MODULE 2 PMP201	10	4	PVC / SWA / PVC	4th core	5	22
BLW/M2/016/P/001	NEW BLOWER ROOM MCC	LOCAL ISOLATOR WW BOOSTER PUMP NO 2 MODULE 2 PMP202	10	4	PVC / SWA / PVC	4th core	45	22
BLW/M2/016/P/002	LOCAL ISOLATOR WW BOOSTER PUMP NO 2 MODULE 2 PMP202	MOTOR WW BOOSTER PUMP NO 2 MODULE 2 PMP202	10	4	PVC / SWA / PVC	4th core	5	22
BLW/M2/017/P/001	NEW BLOWER ROOM MCC	LOCAL ISOLATOR IW TRASH SCREEN CRAWL BEAM	4	4	PVC / SWA / PVC	4th core	195	
BLW/M2/017/P/002	LOCAL ISOLATOR IW TRASH SCREEN CRAWL BEAM	MOTOR IW TRASH SCREEN CRAWL BEAM	4	4	PVC / SWA / PVC	4th core	5	
BLW/M2/018/P/001	NEW BLOWER ROOM MCC	VALVE ACTUATOR NO 1	2.5	4	PVC / SWA / PVC	4th core	200	1.5
BLW/M2/019/P/001	NEW BLOWER ROOM MCC	VALVE ACTUATOR NO 2	2.5	4	PVC / SWA / PVC	4th core	110	1.5
BLW/M2/020/P/001	NEW BLOWER ROOM MCC	VALVE ACTUATOR NO 3	2.5	4	PVC / SWA / PVC	4th core	110	1.5

BUSHKOPPIE WWTW IRP: 400V POWER CABLE SCHEDULES

DRG NO: 18056-73-12-155

SHT 14 OF 26

(Existing Wash Water PS MCC)

REV: T00

MARCH 2024

CABLE NO	CABLE FED FROM	CABLE FEEDING TO	SIZE IN mm ²	NO OF CORES	TYPE	SEPARATE EARTH	EST LENGTH	LOAD Kw
WWPS/001/P/001	WASH WATER PS MCC	LOCAL ISOLATOR WASH WATER TRANSFER PUMP NO 1	16	4	PVC / SWA / PVC	4th core	16	30
WWPS/001/P/002	LOCAL ISOLATOR WASH WATER TRANSFER PUMP NO 1	MOTOR WASH WATER TRANSFER PUMP NO 1	16	4	PVC / SWA / PVC	4th core	5	30
WWPS/002/P/001	WASH WATER PS MCC	LOCAL ISOLATOR WASH WATER TRANSFER PUMP NO 2	16	4	PVC / SWA / PVC	4th core	16	30
WWPS/002/P/002	LOCAL ISOLATOR WASH WATER TRANSFER PUMP NO 2	MOTOR WASH WATER TRANSFER PUMP NO 2	16	4	PVC / SWA / PVC	4th core	5	30
WWPS/003/P/001	WASH WATER PS MCC	LOCAL ISOLATOR WASH WATER TRANSFER PUMP NO 3	16	4	PVC / SWA / PVC	4th core	16	30
WWPS/003/P/002	LOCAL ISOLATOR WASH WATER TRANSFER PUMP NO 3	MOTOR WASH WATER TRANSFER PUMP NO 3	16	4	PVC / SWA / PVC	4th core	5	30
WWPS/004/P/001	WASH WATER PS MCC	LOCAL ISOLATOR FILTER FEED PUMP NO 1	6	4	PVC / SWA / PVC	4th core	15	15
WWPS/004/P/002	LOCAL ISOLATOR FILTER FEED PUMP NO 1	MOTOR FILTER FEED PUMP NO 1	6	4	PVC / SWA / PVC	4th core	5	15
WWPS/005/P/001	WASH WATER PS MCC	LOCAL ISOLATOR FILTER FEED PUMP NO 2	6	4	PVC / SWA / PVC	4th core	15	15
WWPS/005/P/002	LOCAL ISOLATOR FILTER FEED PUMP NO 2	MOTOR FILTER FEED PUMP NO 2	6	4	PVC / SWA / PVC	4th core	5	15
WWPS/006/P/001	WASH WATER PS MCC	LOCAL ISOLATOR BLOWER NO 1	6	4	PVC / SWA / PVC	4th core	17	11
WWPS/006/P/002	LOCAL ISOLATOR BLOWER NO 1	MOTOR BLOWER NO 1	6	4	PVC / SWA / PVC	4th core	5	11

BUSHKOPPIE WWTW IRP: 400V POWER CABLE SCHEDULES

DRG NO: 18056-73-12-155

SHT 15 OF 26

(Existing Wash Water PS MCC)

REV: T00

MARCH 2024

CABLE NO	CABLE FED FROM	CABLE FEEDING TO	SIZE IN mm ²	NO OF CORES	TYPE	SEPARATE EARTH	EST LENGTH	LOAD Kw
WWPS/007/P/001	WASH WATER PS MCC	LOCAL ISOLATOR BLOWER NO 2	6	4	PVC / SWA / PVC	4th core	17	11
WWPS/007/P/002	LOCAL ISOLATOR BLOWER NO 2	MOTOR BLOWER NO 2	6	4	PVC / SWA / PVC	4th core	5	11
WWPS/008/P/001	WASH WATER PS MCC	LOCAL ISOLATOR PUMP STATION EXTRACTION FAN	2.5	4	PVC / SWA / PVC	4th core	8	1.5
WWPS/008/P/002	LOCAL ISOLATOR PUMP STATION EXTRACTION FAN	FAN MOTOR PUMP STATION EXTRACTION FAN	2.5	4	PVC / SWA / PVC	4th core	1	1.5
WWPS/009/P/001	WASH WATER PS MCC	LOCAL ISOLATOR MCC ROOM PRESSURISING FAN	2.5	4	PVC / SWA / PVC	4th core	8	1.1
WWPS/009/P/002	LOCAL ISOLATOR MCC ROOM PRESSURISING FAN	FAN MOTOR MCC ROOM PRESSURISING FAN	2.5	4	PVC / SWA / PVC	4th core	1	1.1
WWPS/010/P/001	WASH WATER PS MCC	LOCAL ISOLATOR SUMP PUMP	2.5	4	PVC / SWA / PVC	4th core	17	2.2
WWPS/010/P/002	LOCAL ISOLATOR SUMP PUMP	MOTOR SUMP PUMP	2.5	4	PVC / SWA / PVC	4th core	2	2.2
WWPS/011/P/001	WASH WATER PS MCC	VALVE ACTUATOR NO 1	2.5	4	PVC / SWA / PVC	4th core	90	1.5
WWPS/012/P/001	WASH WATER PS MCC	VALVE ACTUATOR NO 2	2.5	4	PVC / SWA / PVC	4th core	90	1.5
WWPS/013/P/001	WASH WATER PS MCC	VALVE ACTUATOR NO 3	2.5	4	PVC / SWA / PVC	4th core	90	1.5

BUSHKOPPIE WWTW IRP: 400V POWER CABLE SCHEDULES

DRG NO: 18056-73-12-155

SHT 16 OF 26

(New Wash Water Filter MCC)

REV: T00

MARCH 2024

CABLE NO	CABLE FED FROM	CABLE FEEDING TO	SIZE IN mm ²	NO OF CORES	TYPE	SEPARATE EARTH	EST LENGTH	LOAD Kw
WWFS/001/P/001	WASH WATER FS MCC	LOCAL ISOLATOR FILTER FEED PUMP NO 1	6	4	PVC / SWA / PVC	4th core	15	15
WWFS/001/P/002	LOCAL ISOLATOR FILTER FEED PUMP NO 1	MOTOR FILTER FEED PUMP NO 1	6	4	PVC / SWA / PVC	4th core	5	15
WWFS/002/P/001	WASH WATER FS MCC	LOCAL ISOLATOR FILTER FEED PUMP NO 2	6	4	PVC / SWA / PVC	4th core	15	15
WWFS/002/P/002	LOCAL ISOLATOR FILTER FEED PUMP NO 2	MOTOR FILTER FEED PUMP NO 2	6	4	PVC / SWA / PVC	4th core	5	15
WWFS/003/P/001	WASH WATER FS MCC	LOCAL ISOLATOR AIR BLOWER NO 1	6	4	PVC / SWA / PVC	4th core	15	11
WWFS/003/P/002	LOCAL ISOLATOR AIR BLOWER NO 1	MOTOR AIR BLOWER NO 1	6	4	PVC / SWA / PVC	4th core	5	11
WWFS/004/P/001	WASH WATER FS MCC	LOCAL ISOLATOR AIR BLOWER NO 2	6	4	PVC / SWA / PVC	4th core	15	11
WWFS/004/P/002	LOCAL ISOLATOR AIR BLOWER NO 2	MOTOR AIR BLOWER NO 2	6	4	PVC / SWA / PVC	4th core	5	11
WWFS/005/P/001	WASH WATER FS MCC	LOCAL ISOLATOR MCC ROOM PRESSURISING FAN	2.5	4	PVC / SWA / PVC	4th core	8	1.1
WWFS/005/P/002	LOCAL ISOLATOR MCC ROOM PRESSURISING FAN	FAN MOTOR MCC ROOM PRESSURISING FAN	2.5	4	PVC / SWA / PVC	4th core	1	1.1
WWFS/006/P/001	WASH WATER FS MCC	LOCAL ISOLATOR SUMP PUMP	2.5	4	PVC / SWA / PVC	4th core	16	2.2
WWFS/006/P/002	LOCAL ISOLATOR SUMP PUMP	MOTOR SUMP PUMP	2.5	4	PVC / SWA / PVC	4th core	2	2.2

BUSHKOPPIE WWTW IRP: 400V POWER CABLE SCHEDULES				
DRG NO: 18056-73-12-155	SHT 17 OF 26	(New Wash Water Filter MCC)	REV: T00	MARCH 2024

DRG NO: 18056-73-12-155

SHT 17 OF 26

(New Wash Water Filter MCC)

REV: T00

MARCH 2024

[illegible]

BUSHKOPPIE WWTW IRP: 230V CONTROL CABLE SCHEDULES

DRG NO: 18056-73-12-155

SHT 18 OF 26

(HOW Module 1 MCC)

REV: T00

MARCH 2024

CABLE NO	CABLE FED FROM	CABLE FEEDING TO	SIZE IN mm ²	NO OF CORES	TYPE	SEPARATE EARTH	EST LENGTH	LOAD Kw
HOW/M1/003/C/001	HOW MODULE 1 MCC (FWD / REV)	LOCAL ISOLATOR COARSE SCREEN NO 1 CSN101	1.5	7	PVC / SWA / PVC		150	
HOW/M1/004/C/001	HOW MODULE 1 MCC (FWD / REV)	LOCAL ISOLATOR COARSE SCREEN NO 2 CSN102	1.5	7	PVC / SWA / PVC		150	
HOW/M1/005/C/001	HOW MODULE 1 MCC	LOCAL ISOLATOR COARSE SCREEN WASHER NO 1 CWM101	1.5	7	PVC / SWA / PVC		150	
HOW/M1/006/C/001	HOW MODULE 1 MCC	LOCAL ISOLATOR COARSE SCREEN WASHER NO 2 CWM102	1.5	7	PVC / SWA / PVC		150	
HOW/M1/007/C/001	HOW MODULE 1 MCC (FWD / REV)	LOCAL ISOLATOR COARSE SCREEN COMPACTOR NO 1 CCM101	1.5	7	PVC / SWA / PVC		150	
HOW/M1/008/C/001	HOW MODULE 1 MCC (FWD / REV)	LOCAL ISOLATOR COARSE SCREEN COMPACTOR NO 2 CCM102	1.5	7	PVC / SWA / PVC		150	
HOW/M1/009/C/001	HOW MODULE 1 MCC	LOCAL ISOLATOR GRIT CLASSIFIER NO 1 GCM101	1.5	7	PVC / SWA / PVC		100	
HOW/M1/010/C/001	HOW MODULE 1 MCC	LOCAL ISOLATOR GRIT CLASSIFIER WASHER NO 1 GCW101	1.5	7	PVC / SWA / PVC		100	
HOW/M1/011/C/001	HOW MODULE 1 MCC	LOCAL ISOLATOR GRIT CLASSIFIER NO 2 GCM102	1.5	7	PVC / SWA / PVC		100	
HOW/M1/012/C/001	HOW MODULE 1 MCC	LOCAL ISOLATOR GRIT CLASSIFIER WASHER NO 2 GCW102	1.5	7	PVC / SWA / PVC		100	
HOW/M1/013/C/001	HOW MODULE 1 MCC	LOCAL ISOLATOR AIR BLOWER NO 1	1.5	7	PVC / SWA / PVC		72	
HOW/M1/014/C/001	HOW MODULE 1 MCC	LOCAL ISOLATOR AIR BLOWER NO 2	1.5	7	PVC / SWA / PVC		72	

BUSHKOPPIE WWTW IRP: 230V CONTROL CABLE SCHEDULES

DRG NO: 18056-73-12-155

SHT 19 OF 26

(HOW Module 1 MCC)

REV: T00

MARCH 2024

CABLE NO	CABLE FED FROM	CABLE FEEDING TO	SIZE IN mm ²	NO OF CORES	TYPE	SEPARATE EARTH	EST LENGTH	LOAD Kw
HOW/M1/015/C/001	HOW MODULE 1 MCC	LOCAL ISOLATOR AIR BLOWER NO 3	1.5	7	PVC / SWA / PVC		72	
HOW/M1/016/C/001	HOW MODULE 1 MCC	LOCAL ISOLATOR AIR BLOWER NO 4	1.5	7	PVC / SWA / PVC		72	
HOW/M1/017/C/001	HOW MODULE 1 MCC	LOCAL ISOLATOR AIR BLOWER NO 5	1.5	7	PVC / SWA / PVC		72	
HOW/M1/018/C/001	HOW MODULE 1 MCC	LOCAL ISOLATOR AIR BLOWER NO 6	1.5	7	PVC / SWA / PVC		72	
HOW/M1/019/C/001	HOW MODULE 1 MCC	LOCAL ISOLATOR AIR BLOWER NO 7	1.5	7	PVC / SWA / PVC		72	
HOW/M1/020/C/001	HOW MODULE 1 MCC	LOCAL ISOLATOR AIR BLOWER NO 8	1.5	7	PVC / SWA / PVC		72	
HOW/M1/021/C/001	HOW MODULE 1 MCC (FWD / REV)	LOCAL ISOLATOR FINE SCREEN NO 1 FSN101	1.5	7	PVC / SWA / PVC		120	
HOW/M1/022/C/001	HOW MODULE 1 MCC (FWD / REV)	LOCAL ISOLATOR FINE SCREEN NO 2 FSN102	1.5	7	PVC / SWA / PVC		120	
HOW/M1/023/C/001	HOW MODULE 1 MCC (FWD / REV)	LOCAL ISOLATOR FINE SCREEN NO 3 FSN103	1.5	7	PVC / SWA / PVC		120	
HOW/M1/024/C/001	HOW MODULE 1 MCC (FWD / REV)	LOCAL ISOLATOR FINE SCREEN NO 4 FSN104	1.5	7	PVC / SWA / PVC		120	
HOW/M1/025/C/001	HOW MODULE 1 MCC	LOCAL ISOLATOR FINE SCREEN WASHER NO 1 FSW101	1.5	7	PVC / SWA / PVC		120	
HOW/M1/026/C/001	HOW MODULE 1 MCC	LOCAL ISOLATOR FINE SCREEN WASHER NO 2 FSW102	1.5	7	PVC / SWA / PVC		120	

BUSHKOPPIE WWTW IRP: 230V CONTROL CABLE SCHEDULES

DRG NO: 18056-73-12-155

SHT 20 OF 26

(HOW Module 1 MCC)

REV: T00

MARCH 2024

[illegible]

BUSHKOPPIE WWTW IRP: 230V CONTROL CABLE SCHEDULES

DRG NO: 18056-73-12-155

SHT 21 OF 26

(HOW Module 2 MCC)

REV: T00

MARCH 2024

CABLE NO	CABLE FED FROM	CABLE FEEDING TO	SIZE IN mm ²	NO OF CORES	TYPE	SEPARATE EARTH	EST LENGTH	LOAD Kw
HOW/M2/006/C/001	HOW MODULE 2 MCC	LOCAL ISOLATOR GRIT CLASSIFIER NO 1 GCM201	1.5	7	PVC / SWA / PVC		100	
HOW/M2/007/C/001	HOW MODULE 2 MCC	LOCAL ISOLATOR GRIT CLASSIFIER WASHER NO 1 GCW201	1.5	7	PVC / SWA / PVC		100	
HOW/M2/008/C/001	HOW MODULE 2 MCC	LOCAL ISOLATOR GRIT CLASSIFIER NO 2 GCM202	1.5	7	PVC / SWA / PVC		100	
HOW/M2/009/C/001	HOW MODULE 2 MCC	LOCAL ISOLATOR GRIT CLASSIFIER WASHER NO 2 GCW202	1.5	7	PVC / SWA / PVC		100	
HOW/M2/010/C/001	HOW MODULE 2 MCC	LOCAL ISOLATOR GRIT CONVEYOR GCY201	1.5	7	PVC / SWA / PVC		100	
HOW/M2/011/C/001	HOW MODULE 2 MCC	LOCAL ISOLATOR GRIT BIN SELECTOR GBS201	1.5	7	PVC / SWA / PVC		100	
HOW/M2/012/C/001	HOW MODULE 2 MCC	LOCAL ISOLATOR GRIT BIN TROLLEY NO 1 GBD201	1.5	7	PVC / SWA / PVC		100	
HOW/M2/013/C/001	HOW MODULE 2 MCC	LOCAL ISOLATOR GRIT BIN TROLLEY NO 2 GBD202	1.5	7	PVC / SWA / PVC		100	
HOW/M2/014/C/001	HOW MODULE 2 MCC	LOCAL ISOLATOR GRIT BIN TROLLEY NO 3 GBD203	1.5	7	PVC / SWA / PVC		100	

BUSHKOPPIE WWTW IRP: 230V CONTROL CABLE SCHEDULES

DRG NO: 18056-73-12-155

SHT 22 OF 26

(HOW Module 1 Compressor MCC)

REV: T00

MARCH 2024

[illegible]

BUSHKOPPIE WWTW IRP: 230V CONTROL CABLE SCHEDULES

DRG NO: 18056-73-12-155

SHT 23 OF 26

(M2 New Blower Room MCC)

REV: T00

MARCH 2024

CABLE NO	CABLE FED FROM	CABLE FEEDING TO	SIZE IN mm ²	NO OF CORES	TYPE	SEPARATE EARTH	EST LENGTH	LOAD Kw
BLW/M2/001/C/001	NEW BLOWER ROOM MCC	LOCAL ISOLATOR AIR BLOWER NO 1 BLW201	1.5	7	PVC / SWA / PVC		13	
BLW/M2/002/C/001	NEW BLOWER ROOM MCC	LOCAL ISOLATOR AIR BLOWER NO 2 BLW202	1.5	7	PVC / SWA / PVC		13	
BLW/M2/003/C/001	NEW BLOWER ROOM MCC	LOCAL ISOLATOR AIR BLOWER NO 3 BLW203	1.5	7	PVC / SWA / PVC		15	
BLW/M2/004/C/001	NEW BLOWER ROOM MCC	LOCAL ISOLATOR AIR BLOWER NO 4 BLW204	1.5	7	PVC / SWA / PVC		15	
BLW/M2/005/C/001	NEW BLOWER ROOM MCC	LOCAL ISOLATOR AIR BLOWER NO 5 BLW205	1.5	7	PVC / SWA / PVC		18	
BLW/M2/006/C/001	NEW BLOWER ROOM MCC	LOCAL ISOLATOR AIR BLOWER NO 6 BLW206	1.5	7	PVC / SWA / PVC		18	
BLW/M2/007/C/001	NEW BLOWER ROOM MCC	LOCAL ISOLATOR AIR BLOWER NO 7 BLW207	1.5	7	PVC / SWA / PVC		20	
BLW/M2/008/C/001	NEW BLOWER ROOM MCC	LOCAL ISOLATOR AIR BLOWER NO 8 BLW208	1.5	7	PVC / SWA / PVC		20	
BLW/M2/009/C/001	NEW BLOWER ROOM MCC	LOCAL ISOLATOR AIR COMPRESSOR NO 1 CMP201	1.5	7	PVC / SWA / PVC		10	
BLW/M2/010/C/001	NEW BLOWER ROOM MCC	LOCAL ISOLATOR AIR COMPRESSOR NO 2 CMP202	1.5	7	PVC / SWA / PVC		10	
BLW/M2/011/C/001	NEW BLOWER ROOM MCC	LOCAL ISOLATOR INLET WORKS TRASH SCREEN ITS001	1.5	7	PVC / SWA / PVC		195	
BLW/M2/012/C/001	NEW BLOWER ROOM MCC	LOCAL ISOLATOR MCC ROOM FAN BBF201	1.5	7	PVC / SWA / PVC		7	

BUSHKOPPIE WWTW IRP: 230V CONTROL CABLE SCHEDULES

DRG NO: 18056-73-12-155

SHT 24 OF 26

(M2 New Blower Room MCC)

REV: T00

MARCH 2024

[illegible]

BUSHKOPPIE WWTW IRP: 230V CONTROL CABLE SCHEDULES

DRG NO: 18056-73-12-155

SHT 25 OF 26

(Existing Wash Water PS MCC)

REV: T00

MARCH 2024

CABLE NO	CABLE FED FROM	CABLE FEEDING TO	SIZE IN mm ²	NO OF CORES	TYPE	SEPARATE EARTH	EST LENGTH	LOAD Kw
WWPS/001/C/001	WASH WATER PS MCC	LOCAL ISOLATOR WASH WATER TRANSFER PUMP NO 1	1.5	7	PVC / SWA / PVC		16	
WWPS/002/C/001	WASH WATER PS MCC	LOCAL ISOLATOR WASH WATER TRANSFER PUMP NO 2	1.5	7	PVC / SWA / PVC		16	
WWPS/003/C/001	WASH WATER PS MCC	LOCAL ISOLATOR WASH WATER TRANSFER PUMP NO 3	1.5	7	PVC / SWA / PVC		16	
WWPS/004/C/001	WASH WATER PS MCC	LOCAL ISOLATOR FILTER FEED PUMP NO 1	1.5	7	PVC / SWA / PVC		15	
WWPS/005/C/001	WASH WATER PS MCC	LOCAL ISOLATOR FILTER FEED PUMP NO 2	1.5	7	PVC / SWA / PVC		15	
WWPS/006/C/001	WASH WATER PS MCC	LOCAL ISOLATOR BLOWER NO 1	1.5	7	PVC / SWA / PVC		17	
WWPS/007/C/001	WASH WATER PS MCC	LOCAL ISOLATOR BLOWER NO 2	1.5	7	PVC / SWA / PVC		17	
WWPS/008/C/001	WASH WATER PS MCC	LOCAL ISOLATOR PUMP STATION EXTRACTION FAN	1.5	7	PVC / SWA / PVC		8	
WWPS/009/C/001	WASH WATER PS MCC	LOCAL ISOLATOR MCC ROOM PRESSURISING FAN	1.5	7	PVC / SWA / PVC		8	
WWPS/010/C/001	WASH WATER PS MCC	LOCAL ISOLATOR SUMP PUMP	1.5	7	PVC / SWA / PVC		17	

BUSHKOPPIE WWTW IRP: 230V CONTROL CABLE SCHEDULES

DRG NO: 18056-73-12-155



SHT 26 OF 26

(New Wash Water Filter MCC)

REV: T00


MARCH 2024

[illegible]

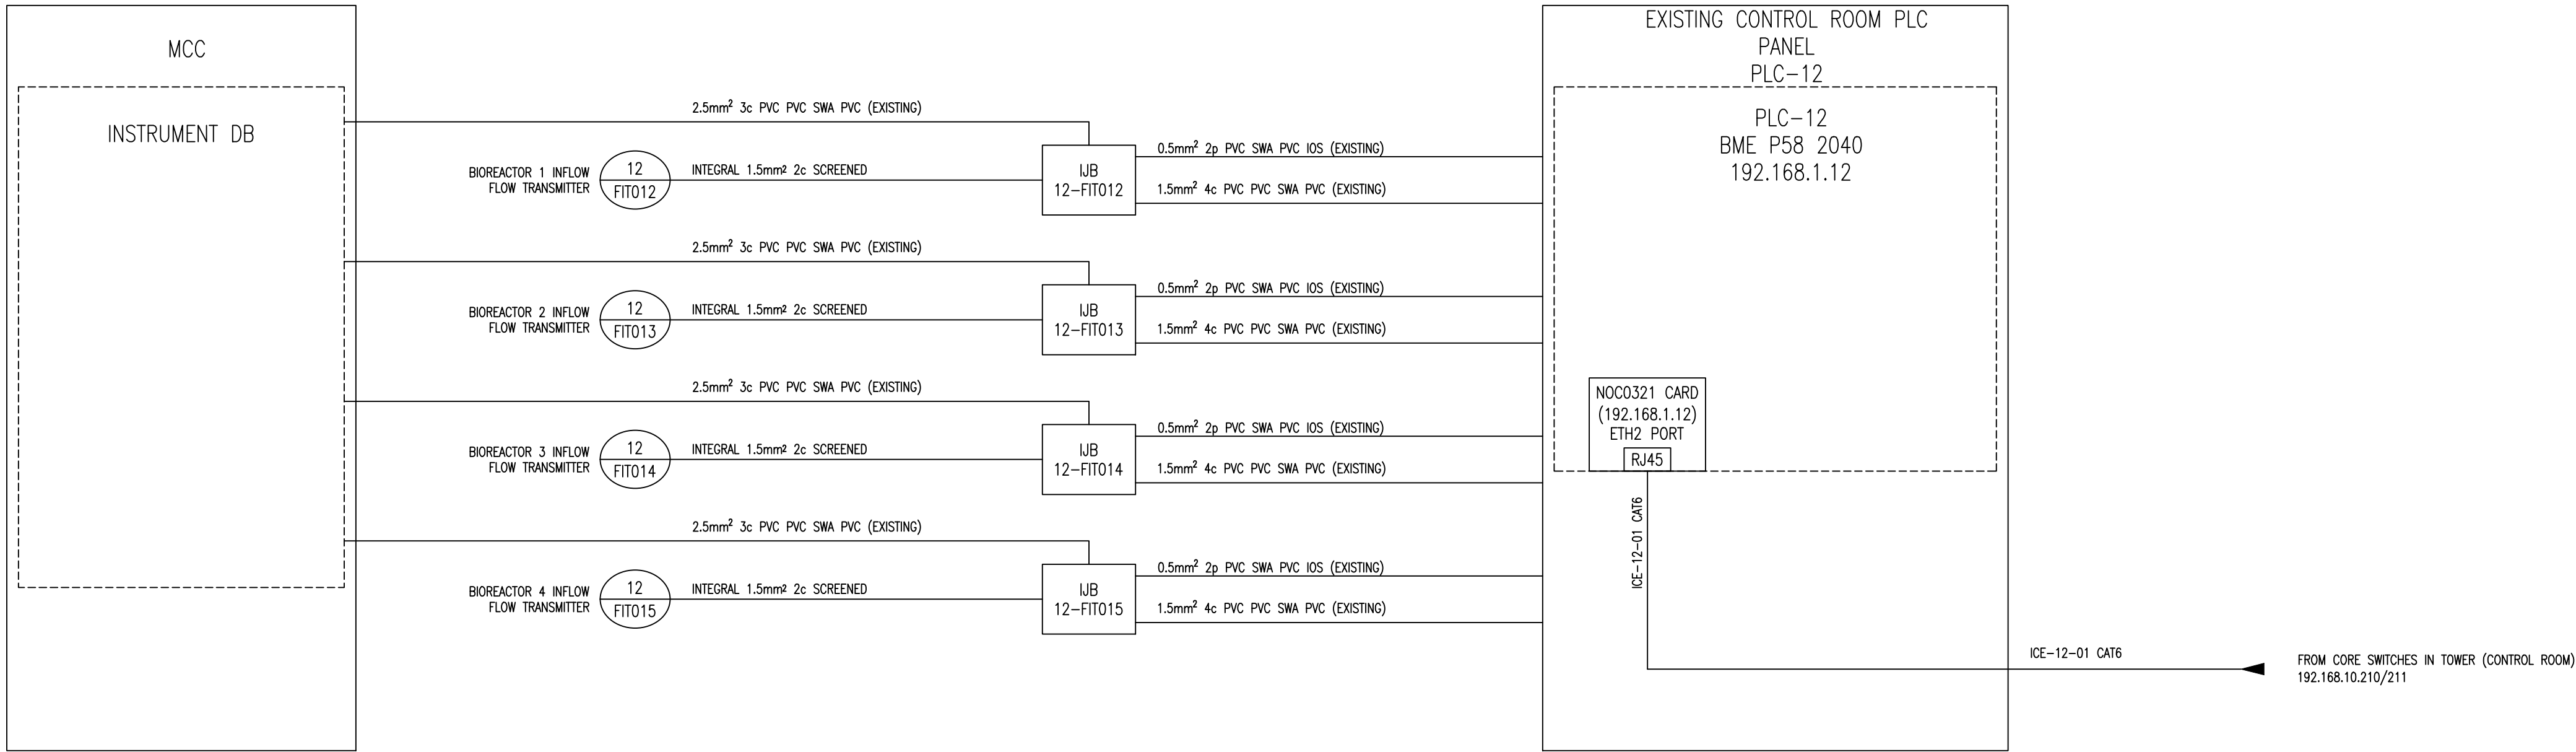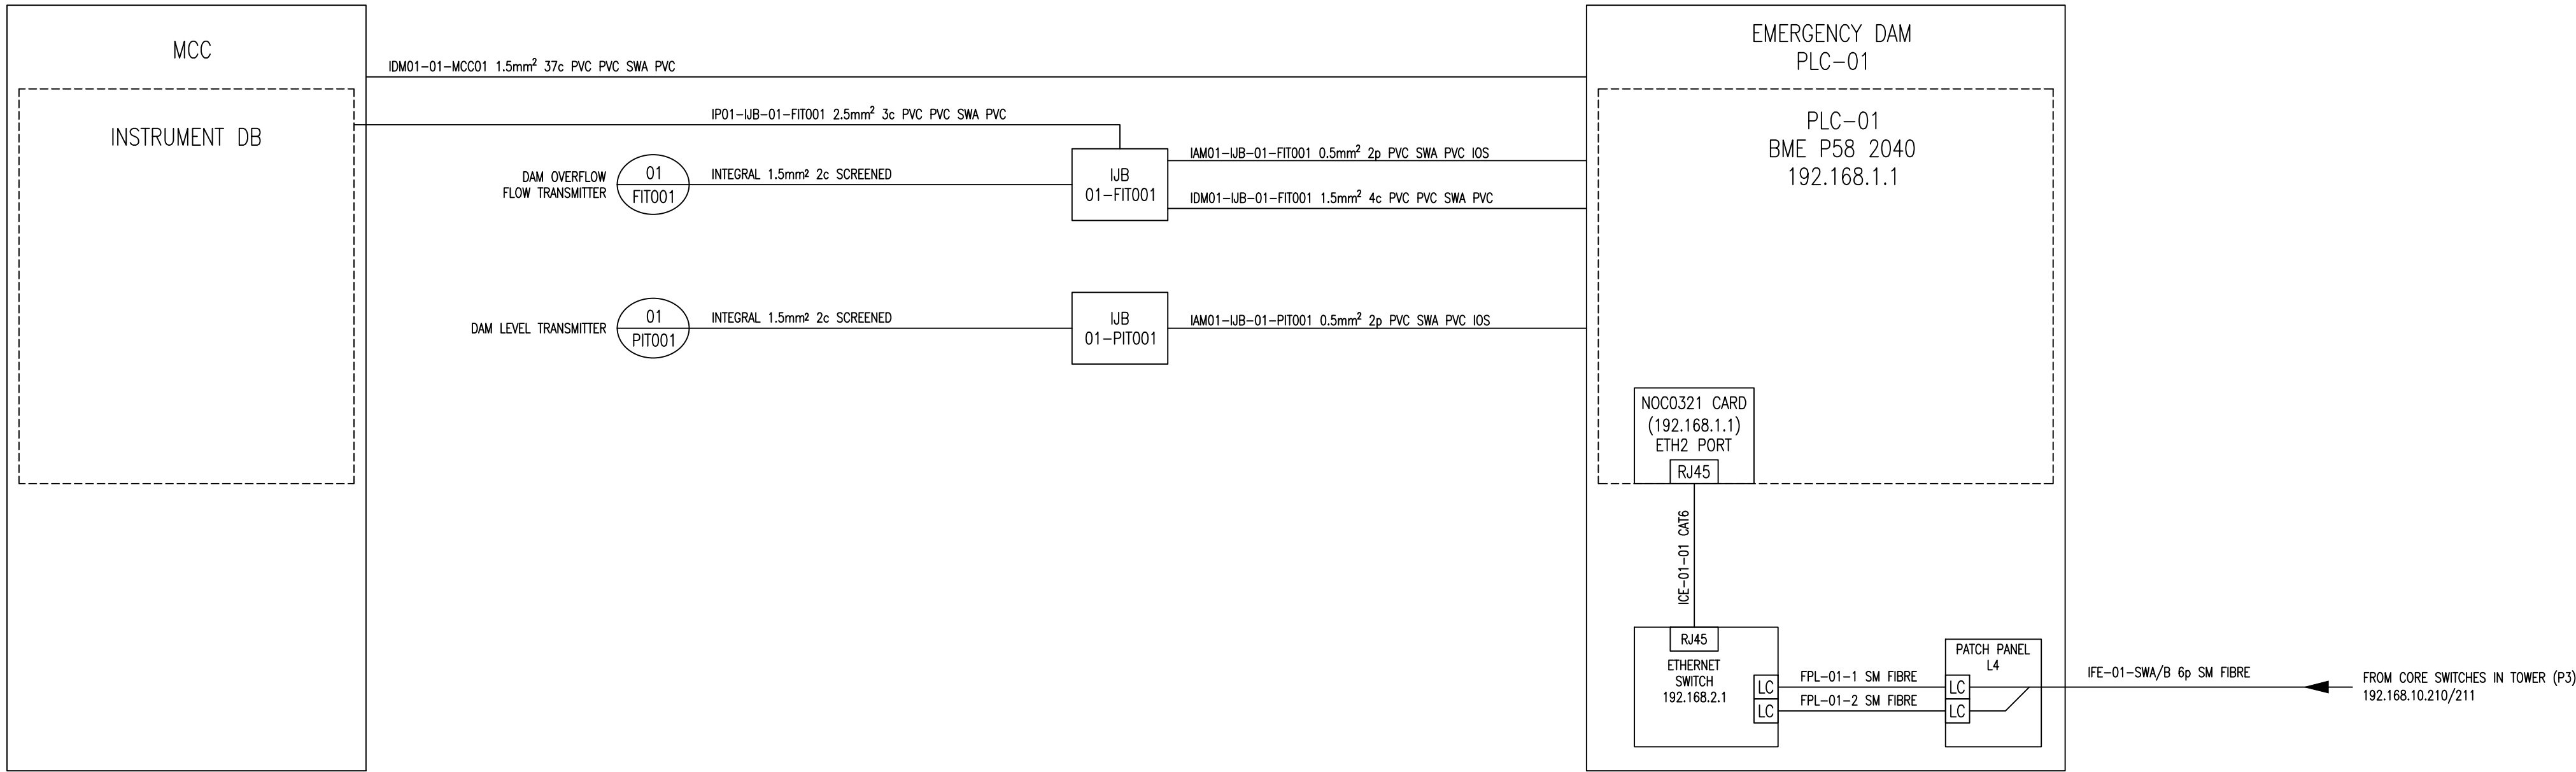

DEPARTMENT	APPROVED	DESIGNATION	DATE

CONSULTING ENGINEERS		SURVEYED		JOHANNESBURG WATER (SOC) LTD		CITY OF JOHANNESBURG		DESIGN MANAGER	SCALE	AMENDMENTS		APPROVED	DATE	DRAWING No.							
ZITHOLELE CONSULTING ZITHOLELE P.O. BOX 6002 HALFWAY HOUSE: 1685 TEL: (011) 207 2060 FAX: (086) 674 6121 EMAIL: mail@zitholele.co.za	wsp WSP Group Africa (Pty) Ltd Building Services Building C, Knightsbridge, 33 Sloane Street, Bryanston, 2191 Tel: +27 11 361 1300 Fax: +27 11 361 1431 www.wsp.com	DESIGNED	W BRITZ		Johannesburg Water 17 HARRISON STREET MARSHALLTOWN 2107 TEL: (011) 688-1400 FAX: (011) 688-1529	BUSHKOPPIE WASTEWATER TREATMENT WORKS INFRASTRUCTURE RENEWAL PLAN EMERGENCY DAM PLC-01 CONTROL ROOM PLC-12 CABLE BLOCK DIAGRAM				TO FOR TENDER		W BRITZ	16.08.21	JW NUMBER							
		DRAWN	M DYKE							T1 RE-ISSUED FOR TENDER		CdT	07.01.25	CONSULTANT'S NUMBER CI-01-CBD001							
		CHECKED												FILE No							
		SERVICES CHECKED												TO	T1						
		GEO TECHNICAL INVESTIGATION																			
		SERVITUDES																			
		APPROVED					DATE	NTS													
		Pr. Eng. No.																			
		DATE																			

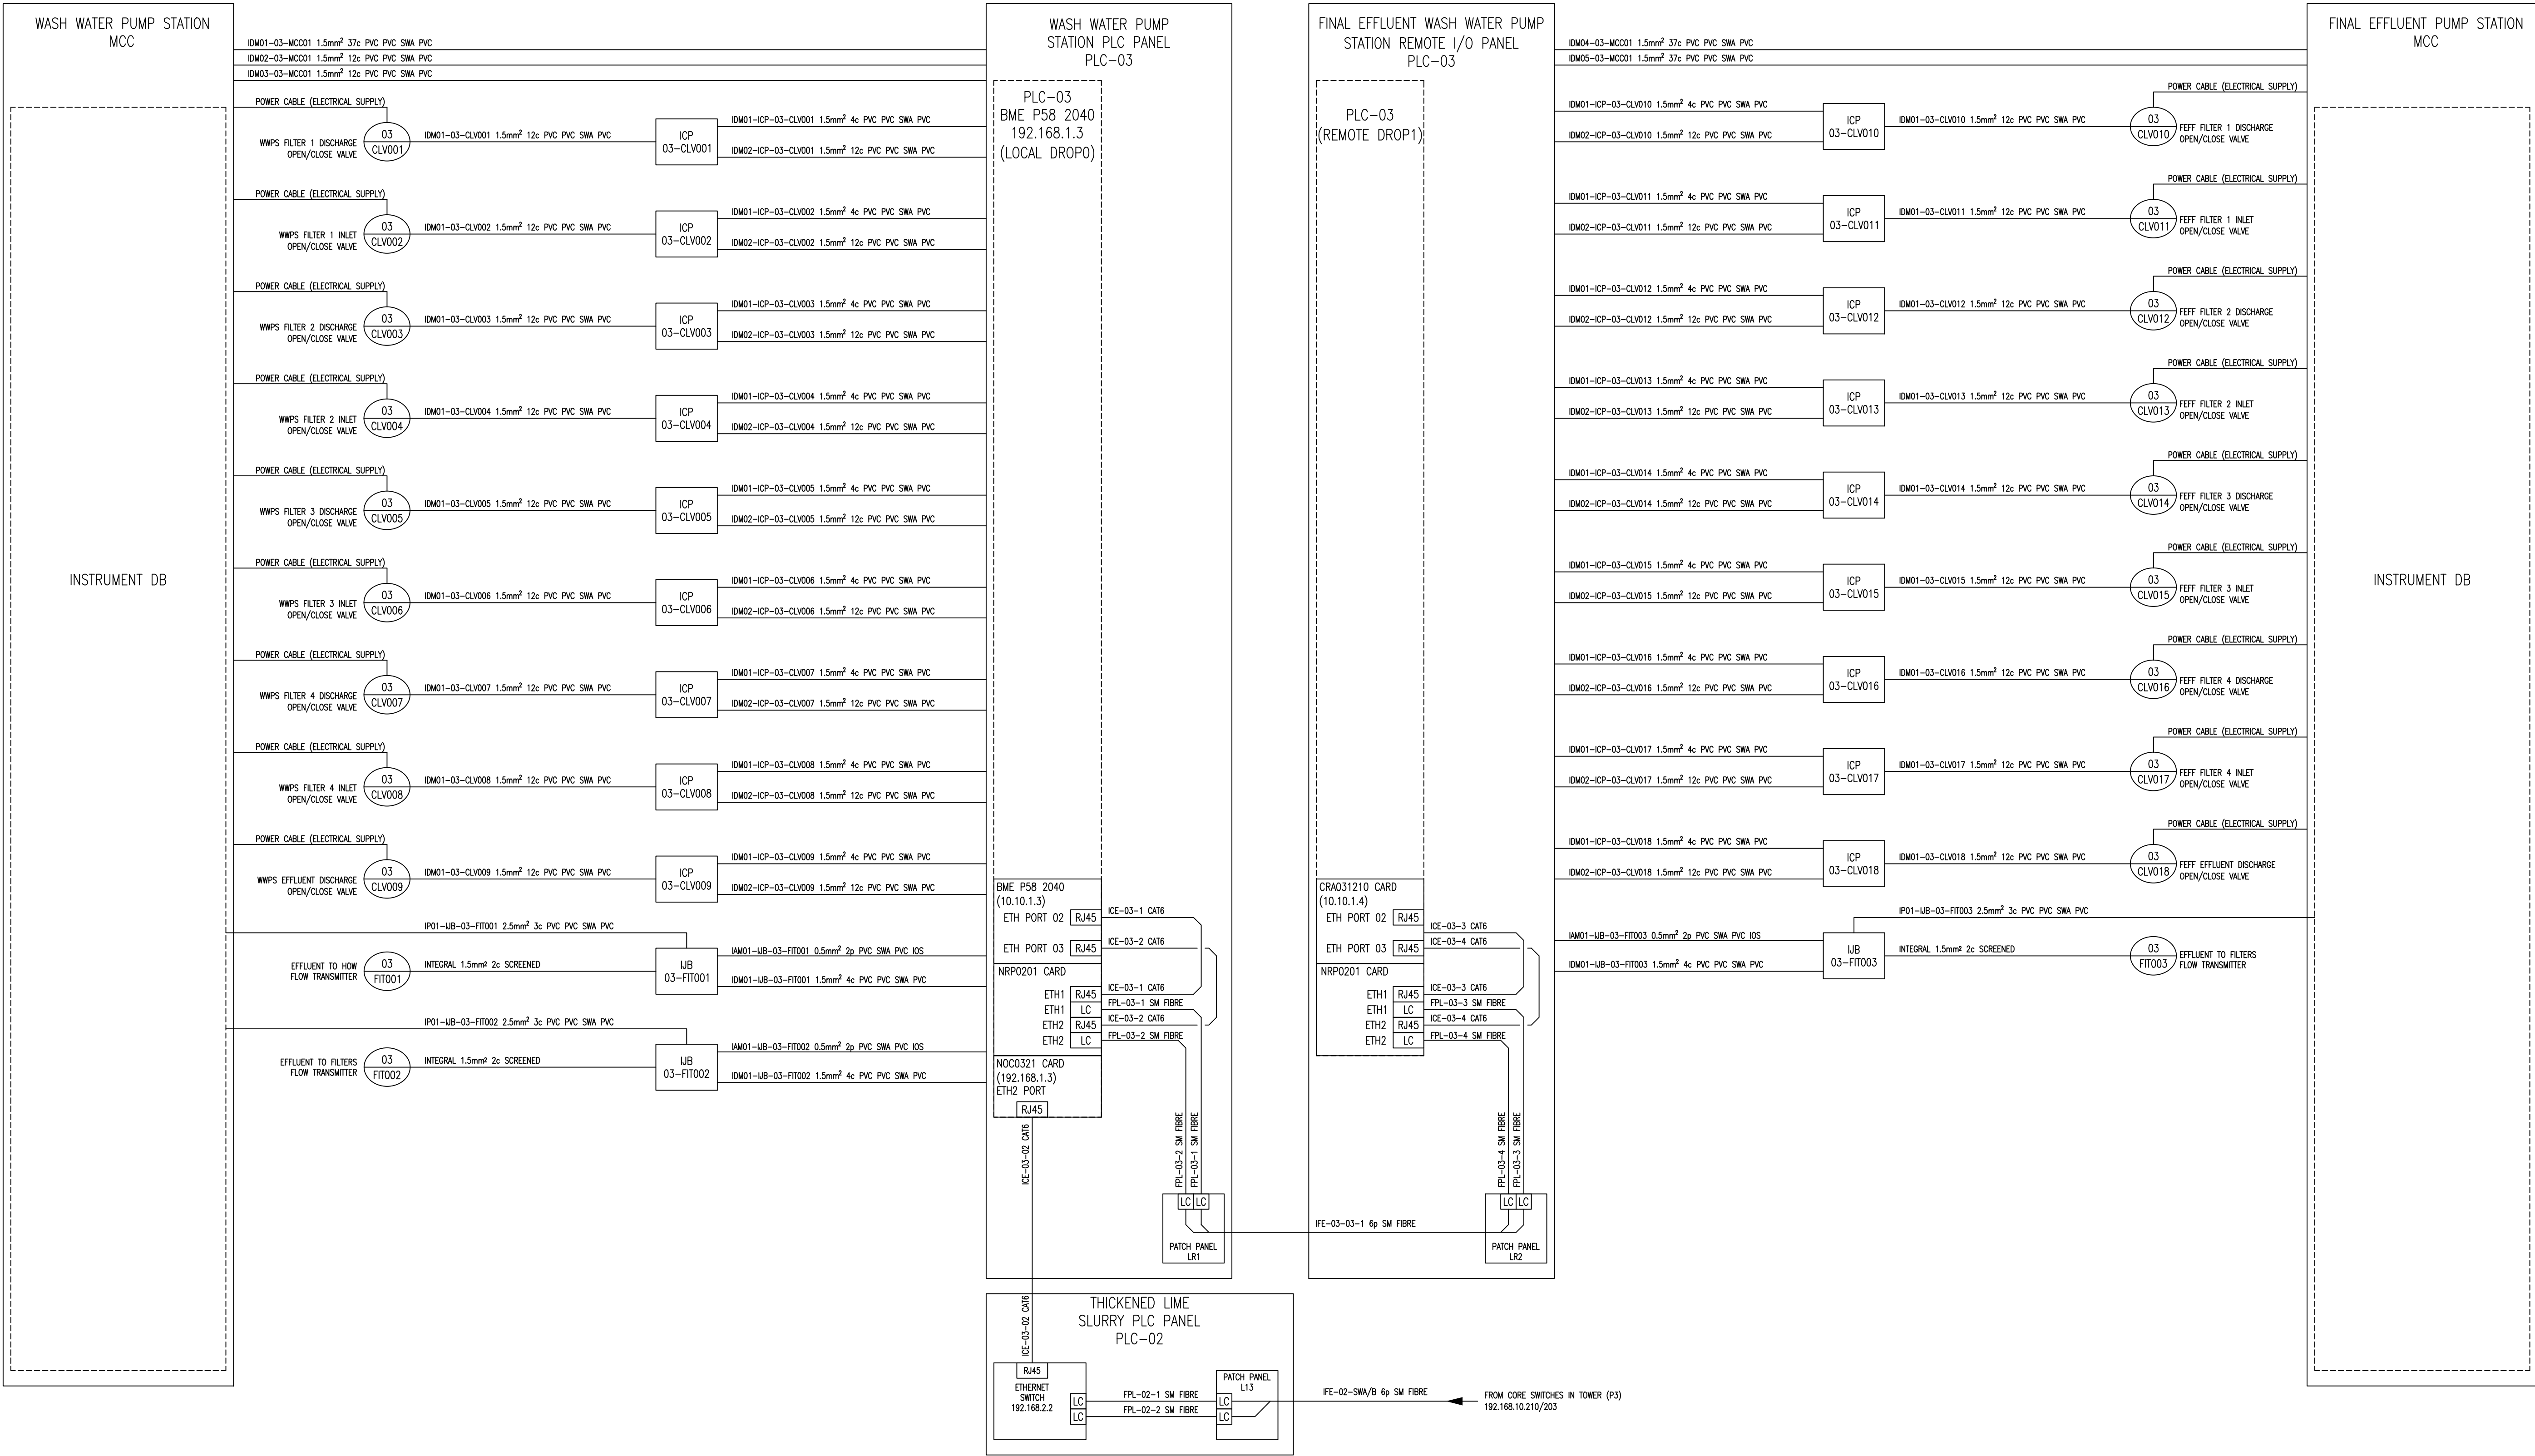






DEPARTMENT	APPROVED	DESIGNATION	DATE

CONSULTING ENGINEERS		SURVEYED		JOHANNESBURG WATER (SOC) LTD		CITY OF JOHANNESBURG		DESIGN MANAGER	SCALE	AMENDMENTS		APPROVED	DATE	DRAWING No.									
 ZITHOLELE P.O. BOX 6002 HALFWAY HOUSE, 1685 TEL: (011) 207 2060 FAX: (086) 674 6121 EMAIL: mail@zitholele.co.za	 WSP Group Africa (Pty) Ltd Building Services Building C, Knightsbridge, 33 Sloane Street, Bryanston, 2191 Tel: +27 03 361 1300 Fax: +27 03 361 1431 www.wsp.com	DESIGNED	W BRITZ	 Johannesburg Water	17 HARRISON STREET MARSHALLTOWN 2107 TEL: (011) 688-1400 FAX: (011) 688-1529	BUSHKOPPIE WASTEWATER TREATMENT WORKS INFRASTRUCTURE RENEWAL PLAN WASH WATER PUMP STATION PLC-03 CABLE BLOCK DIAGRAM	DATE			NTS	T0			FOR TENDER	W BRITZ	16.08.21	JW NUMBER						
		DRAWN	M DYKE					T1	RE-ISSUED FOR TENDER		CdT	07.01.25	CONSULTANT'S NUMBER CI-03-CBD001										
		CHECKED											FILE No										
		SERVICES CHECKED																					
		GEOTECHNICAL INVESTIGATION																					
		SERVITUDES																					
		APPROVED	Pr. Eng. No.											T0	T1								
		DATE																					




DEPARTMENT	APPROVED	DESIGNATION	DATE

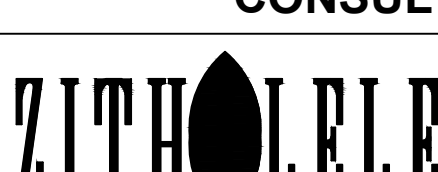CONSULTING ENGINEERS		SURVEYED		JOHANNESBURG WATER (SOC) LTD		CITY OF JOHANNESBURG		DESIGN MANAGER	SCALE	AMENDMENTS		APPROVED	DATE	DRAWING No.								
 ZITHOLELE P.O. BOX 6002 HALFWAY HOUSE, 1685 TEL: (011) 207 2060 FAX: (086) 674 6121 EMAIL: mail@zitholele.co.za	 WSP Group Africa (Pty) Ltd Building Services 33 Sloane Street, Bryanston, 2191 Tel: +27 11 361 1300 Fax: +27 11 361 1431 www.wsp.com	DESIGNED	W BRITZ	 Johannesburg Water	17 HARRISON STREET MARSHALLTOWN 2107 TEL: (011) 688-1400 FAX: (011) 688-1529	BUSHKOPPIE WASTEWATER TREATMENT WORKS INFRASTRUCTURE RENEWAL PLAN UNIT 1 HOW PLC-10 CABLE BLOCK DIAGRAM 1	DATE			NTS	T0	FOR TENDER	W BRITZ	16.08.21	JW NUMBER							
		T1	RE-ISSUED FOR TENDER					CdT	07.01.25		CONSULTANT'S NUMBER CI-10-CBD001											
											FILE No											
		APPROVED						DATE					T0	T1								
		DATE																				

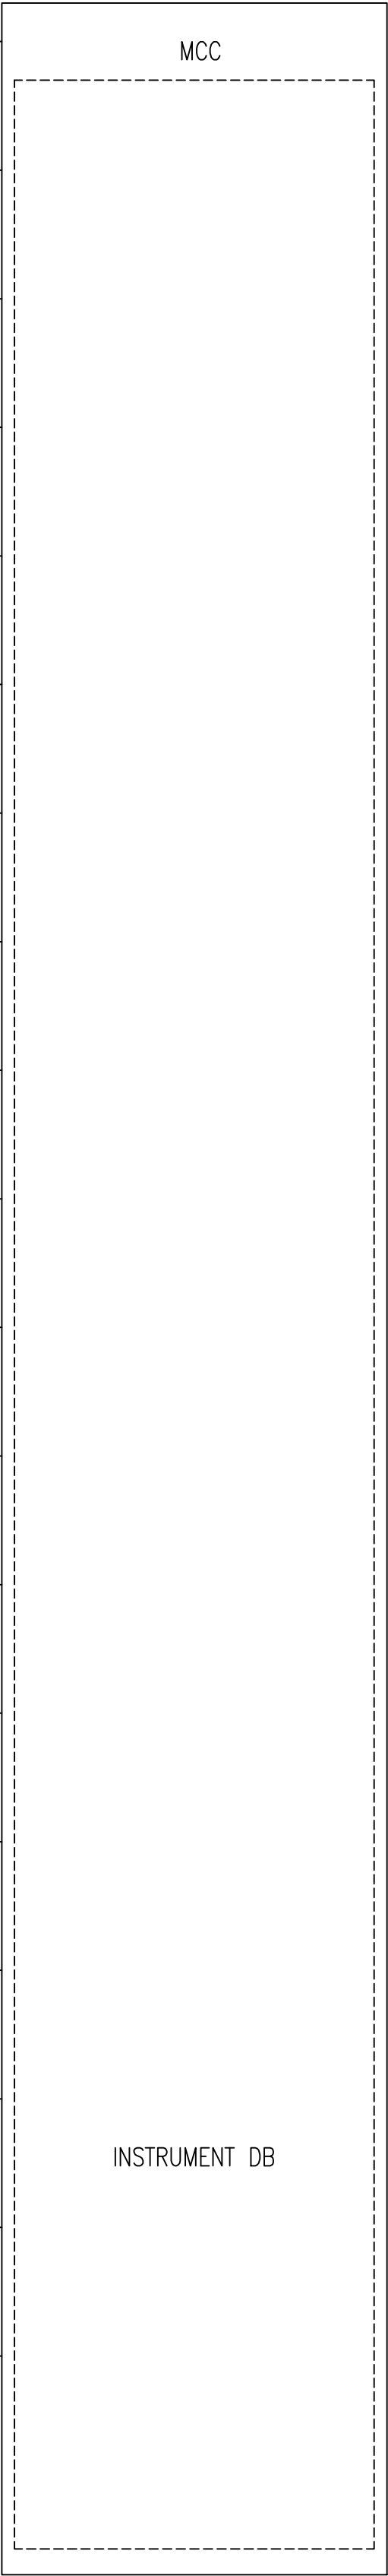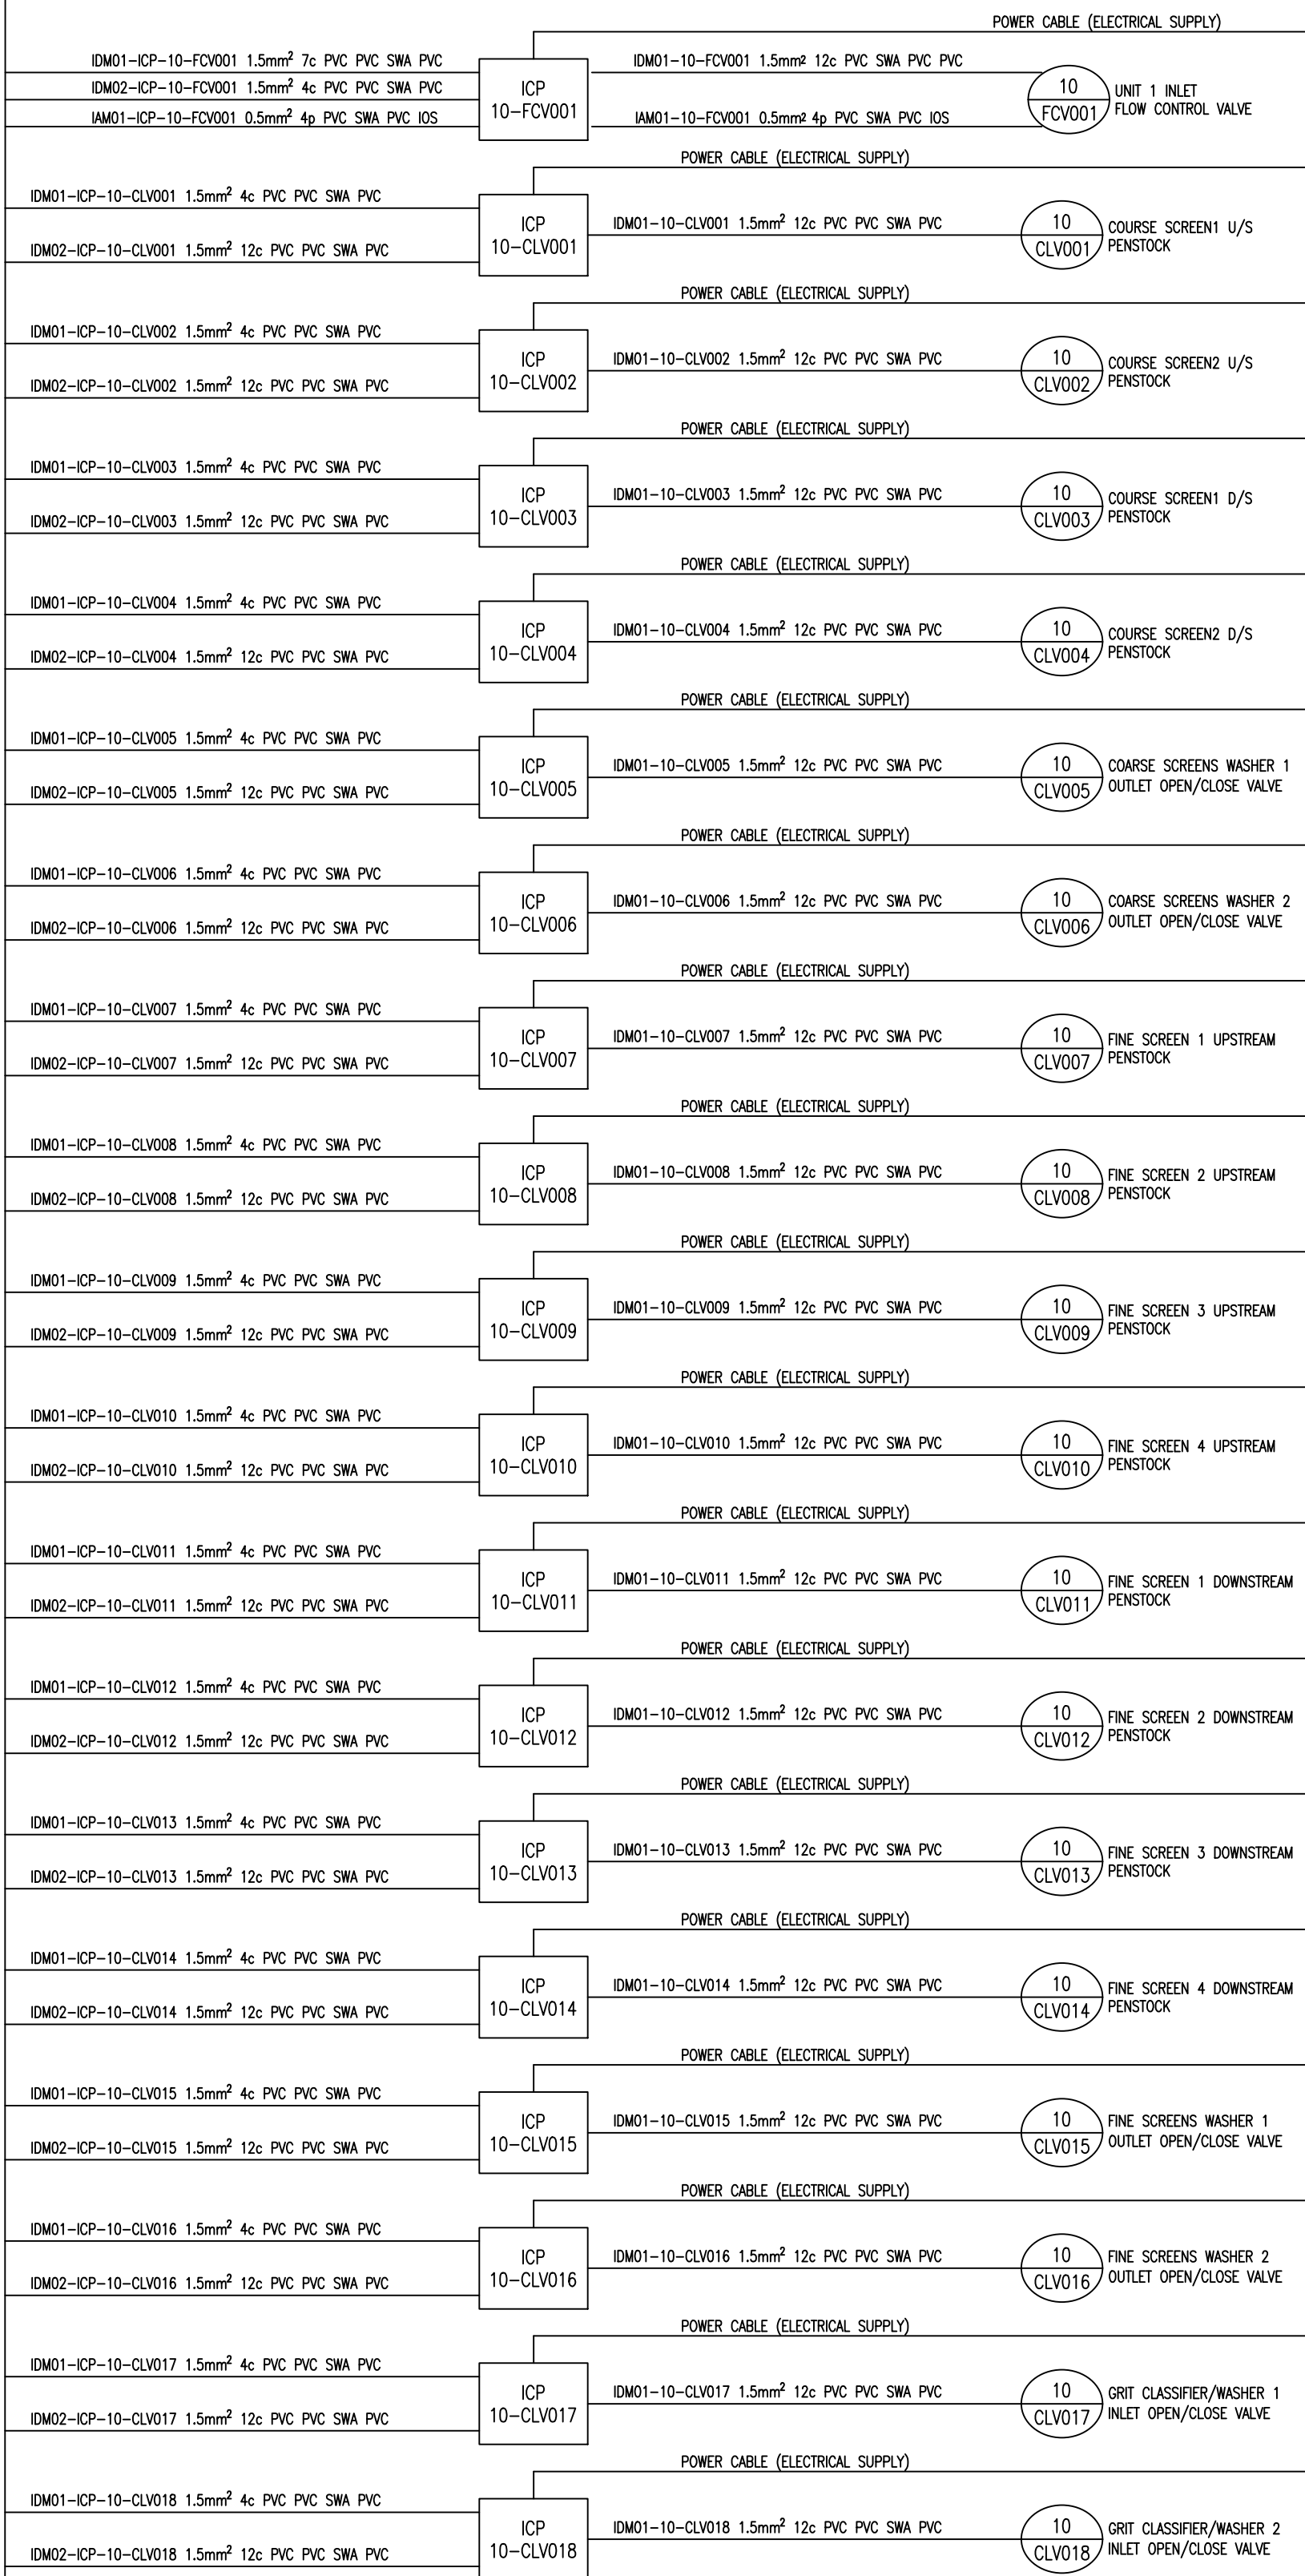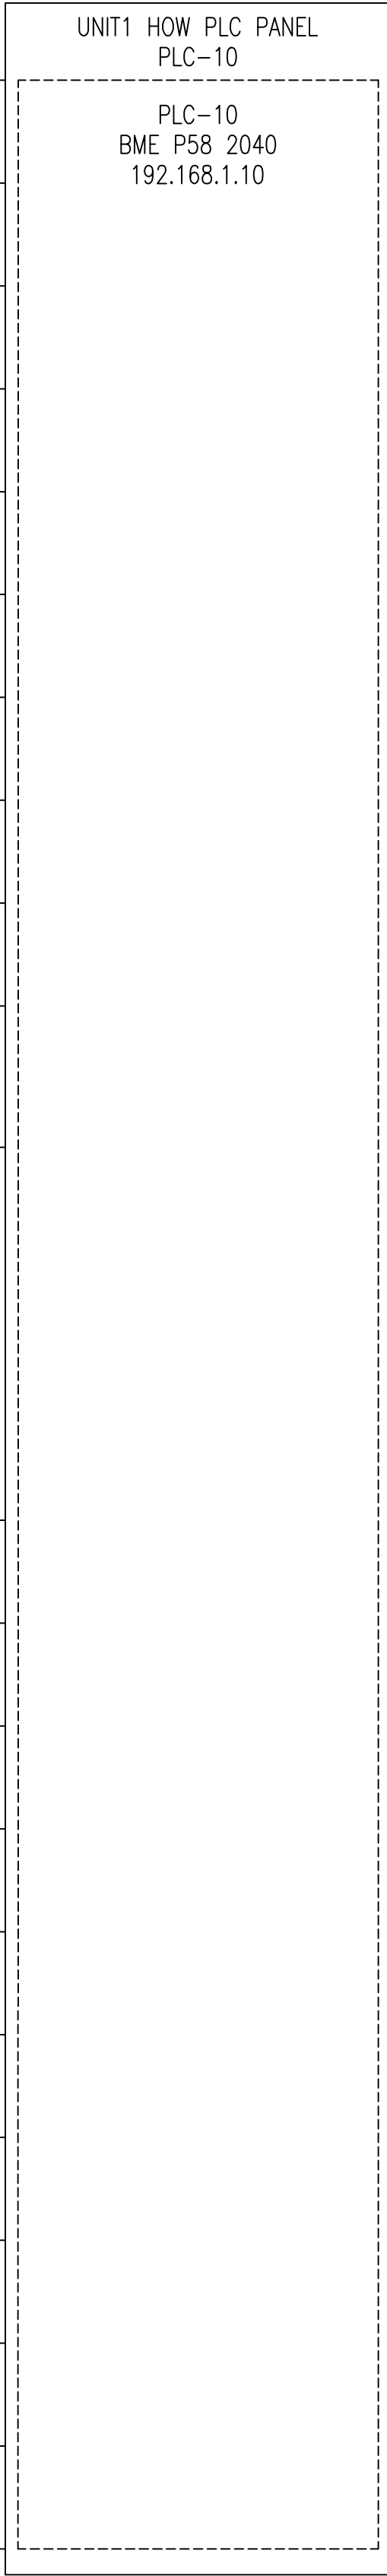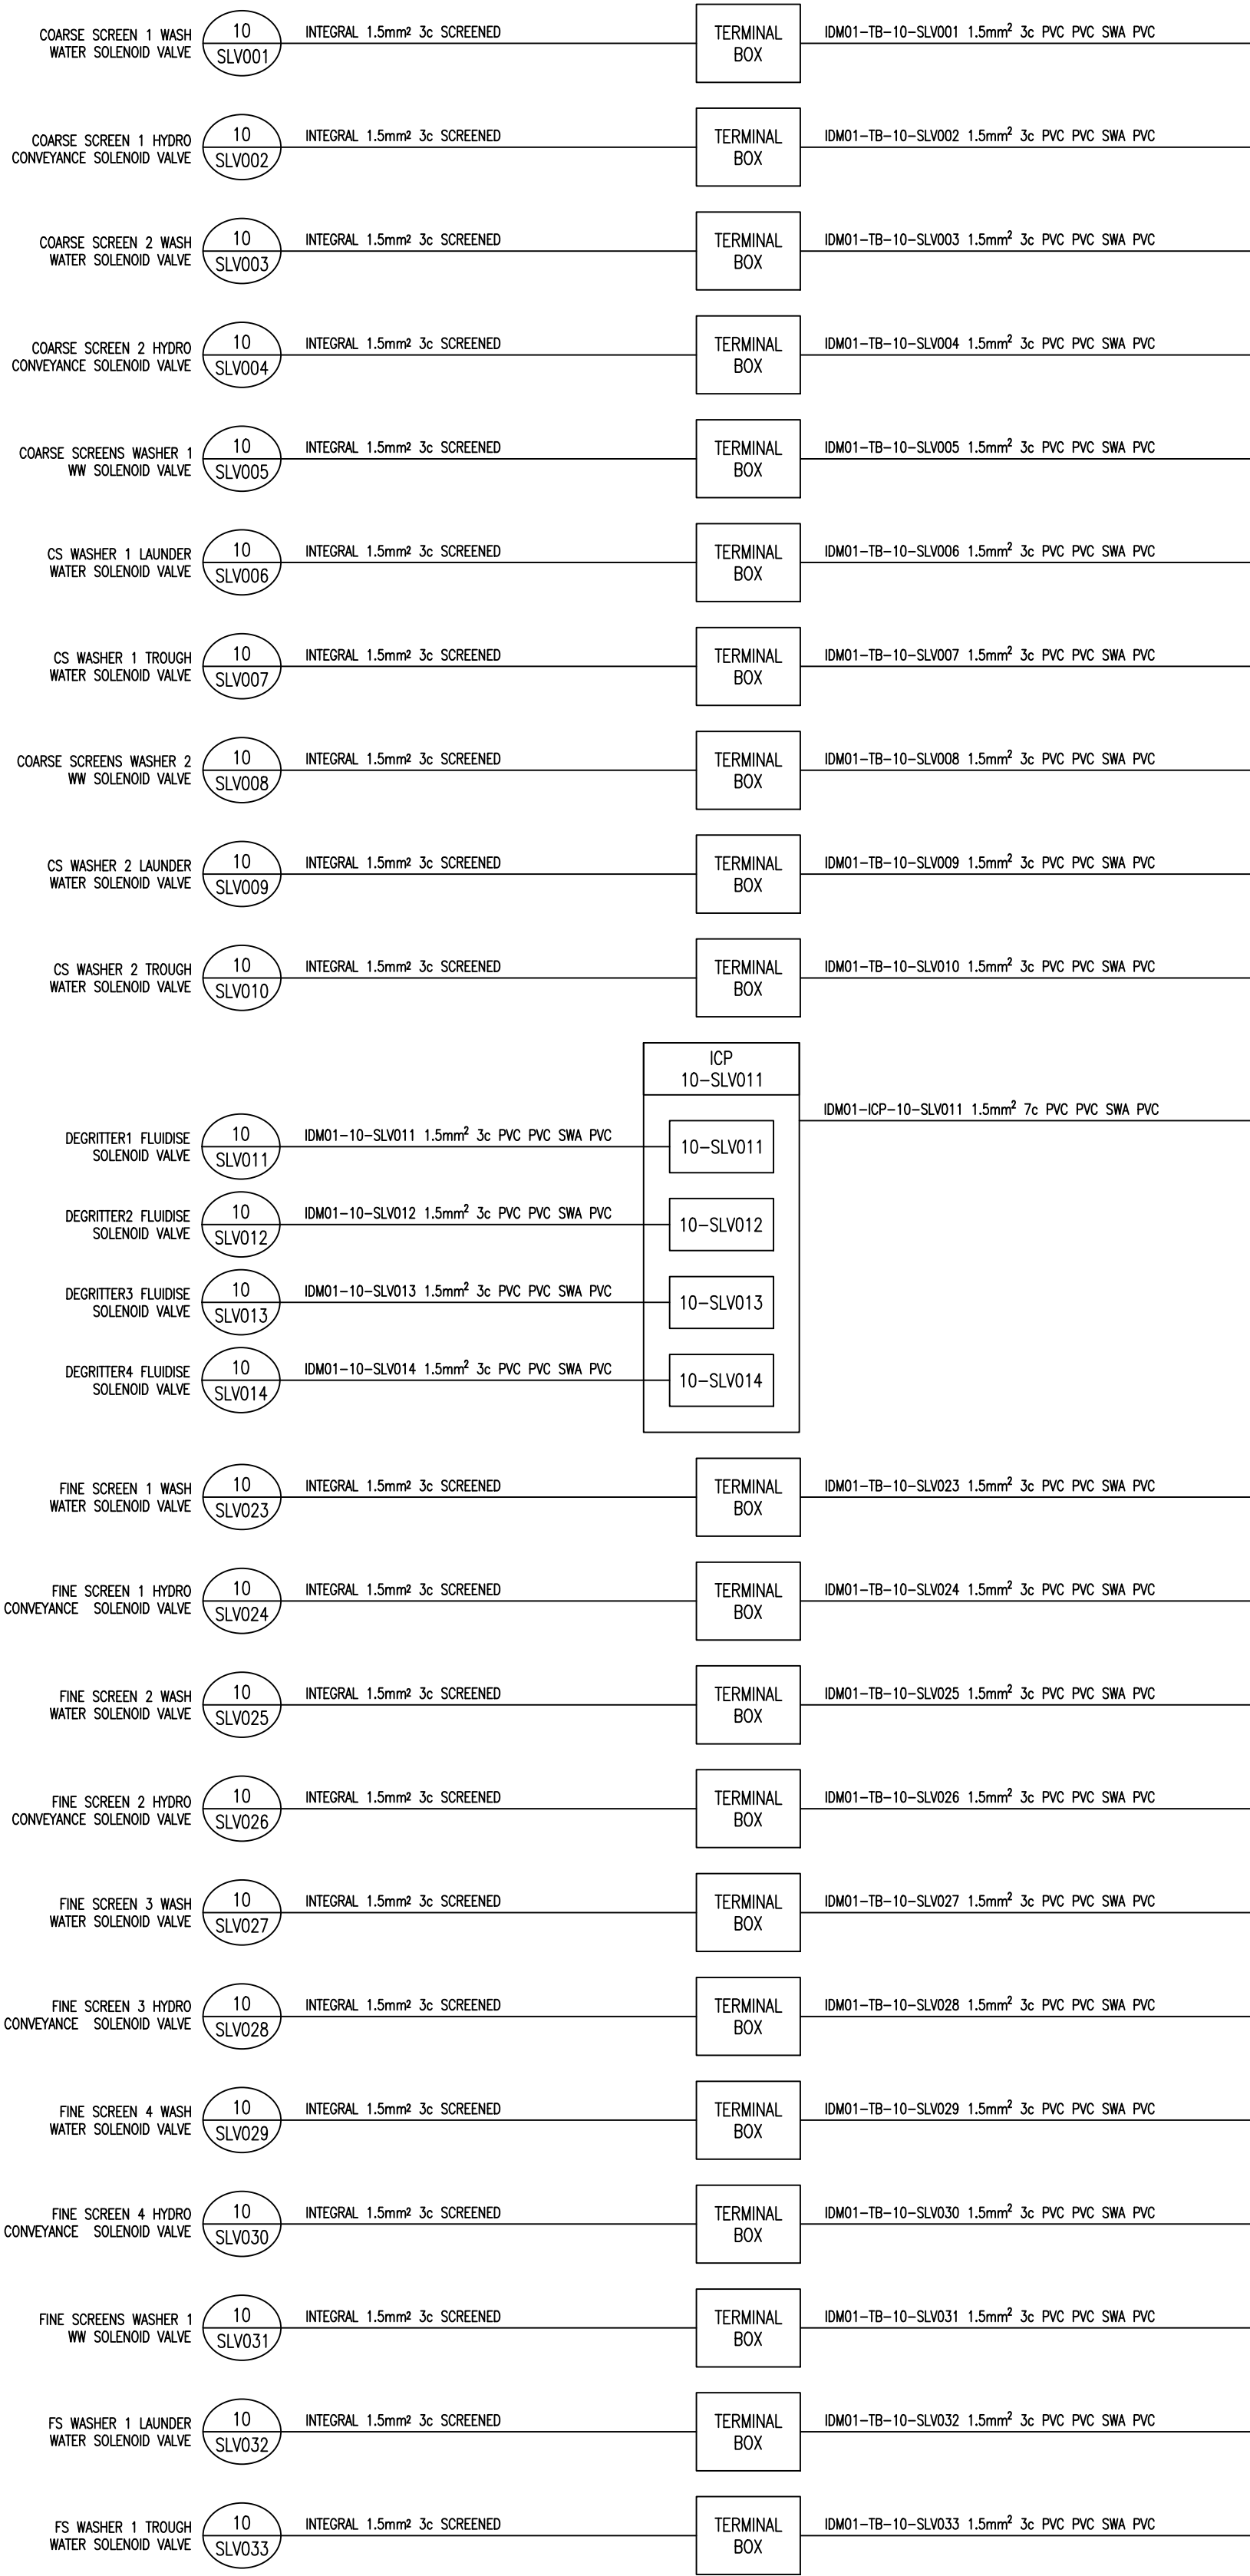



DEPARTMENT	APPROVED	DESIGNATION	DATE

CONSULTING ENGINEERS		SURVEYED		JOHANNESBURG WATER (SOC) LTD		CITY OF JOHANNESBURG		DESIGN MANAGER	SCALE	AMENDMENTS		APPROVED	DATE	DRAWING No.									
 ZITHOLELE CONSULTING P.O. BOX 6002 HALFWAY HOUSE, 1685 TEL: (011) 207 2060 FAX: (086) 674 6121 EMAIL: mail@zitholele.co.za	 WSP Group Africa (Pty) Ltd Building Services Building C, Knightsbridge, 33 Sloane Street, Bryanston, 2191 Tel: +27 11 361 1300 Fax: +27 11 361 1431 www.wsp.com	DESIGNED	W BRITZ	 Johannesburg Water	17 HARRISON STREET MARSHALLTOWN 2107 TEL: (011) 688-1400 FAX: (011) 688-1529	BUSHKOPPIE WASTEWATER TREATMENT WORKS INFRASTRUCTURE RENEWAL PLAN UNIT 1 HOW PLC-10 CABLE BLOCK DIAGRAM 2	DATE			NTS	T0			FOR TENDER	W BRITZ	16.08.21	JW NUMBER						
		DRAWN	M DYKE					T1	RE-ISSUED FOR TENDER		CdT	07.01.25	CONSULTANT'S NUMBER CI-10-CBD002										
		CHECKED											FILE No										
		SERVICES CHECKED																					
		GEOTECHNICAL INVESTIGATION																					
		SERVITUDES																					
		APPROVED	Pr. Eng. No.																				
		DATE												T0		T1							

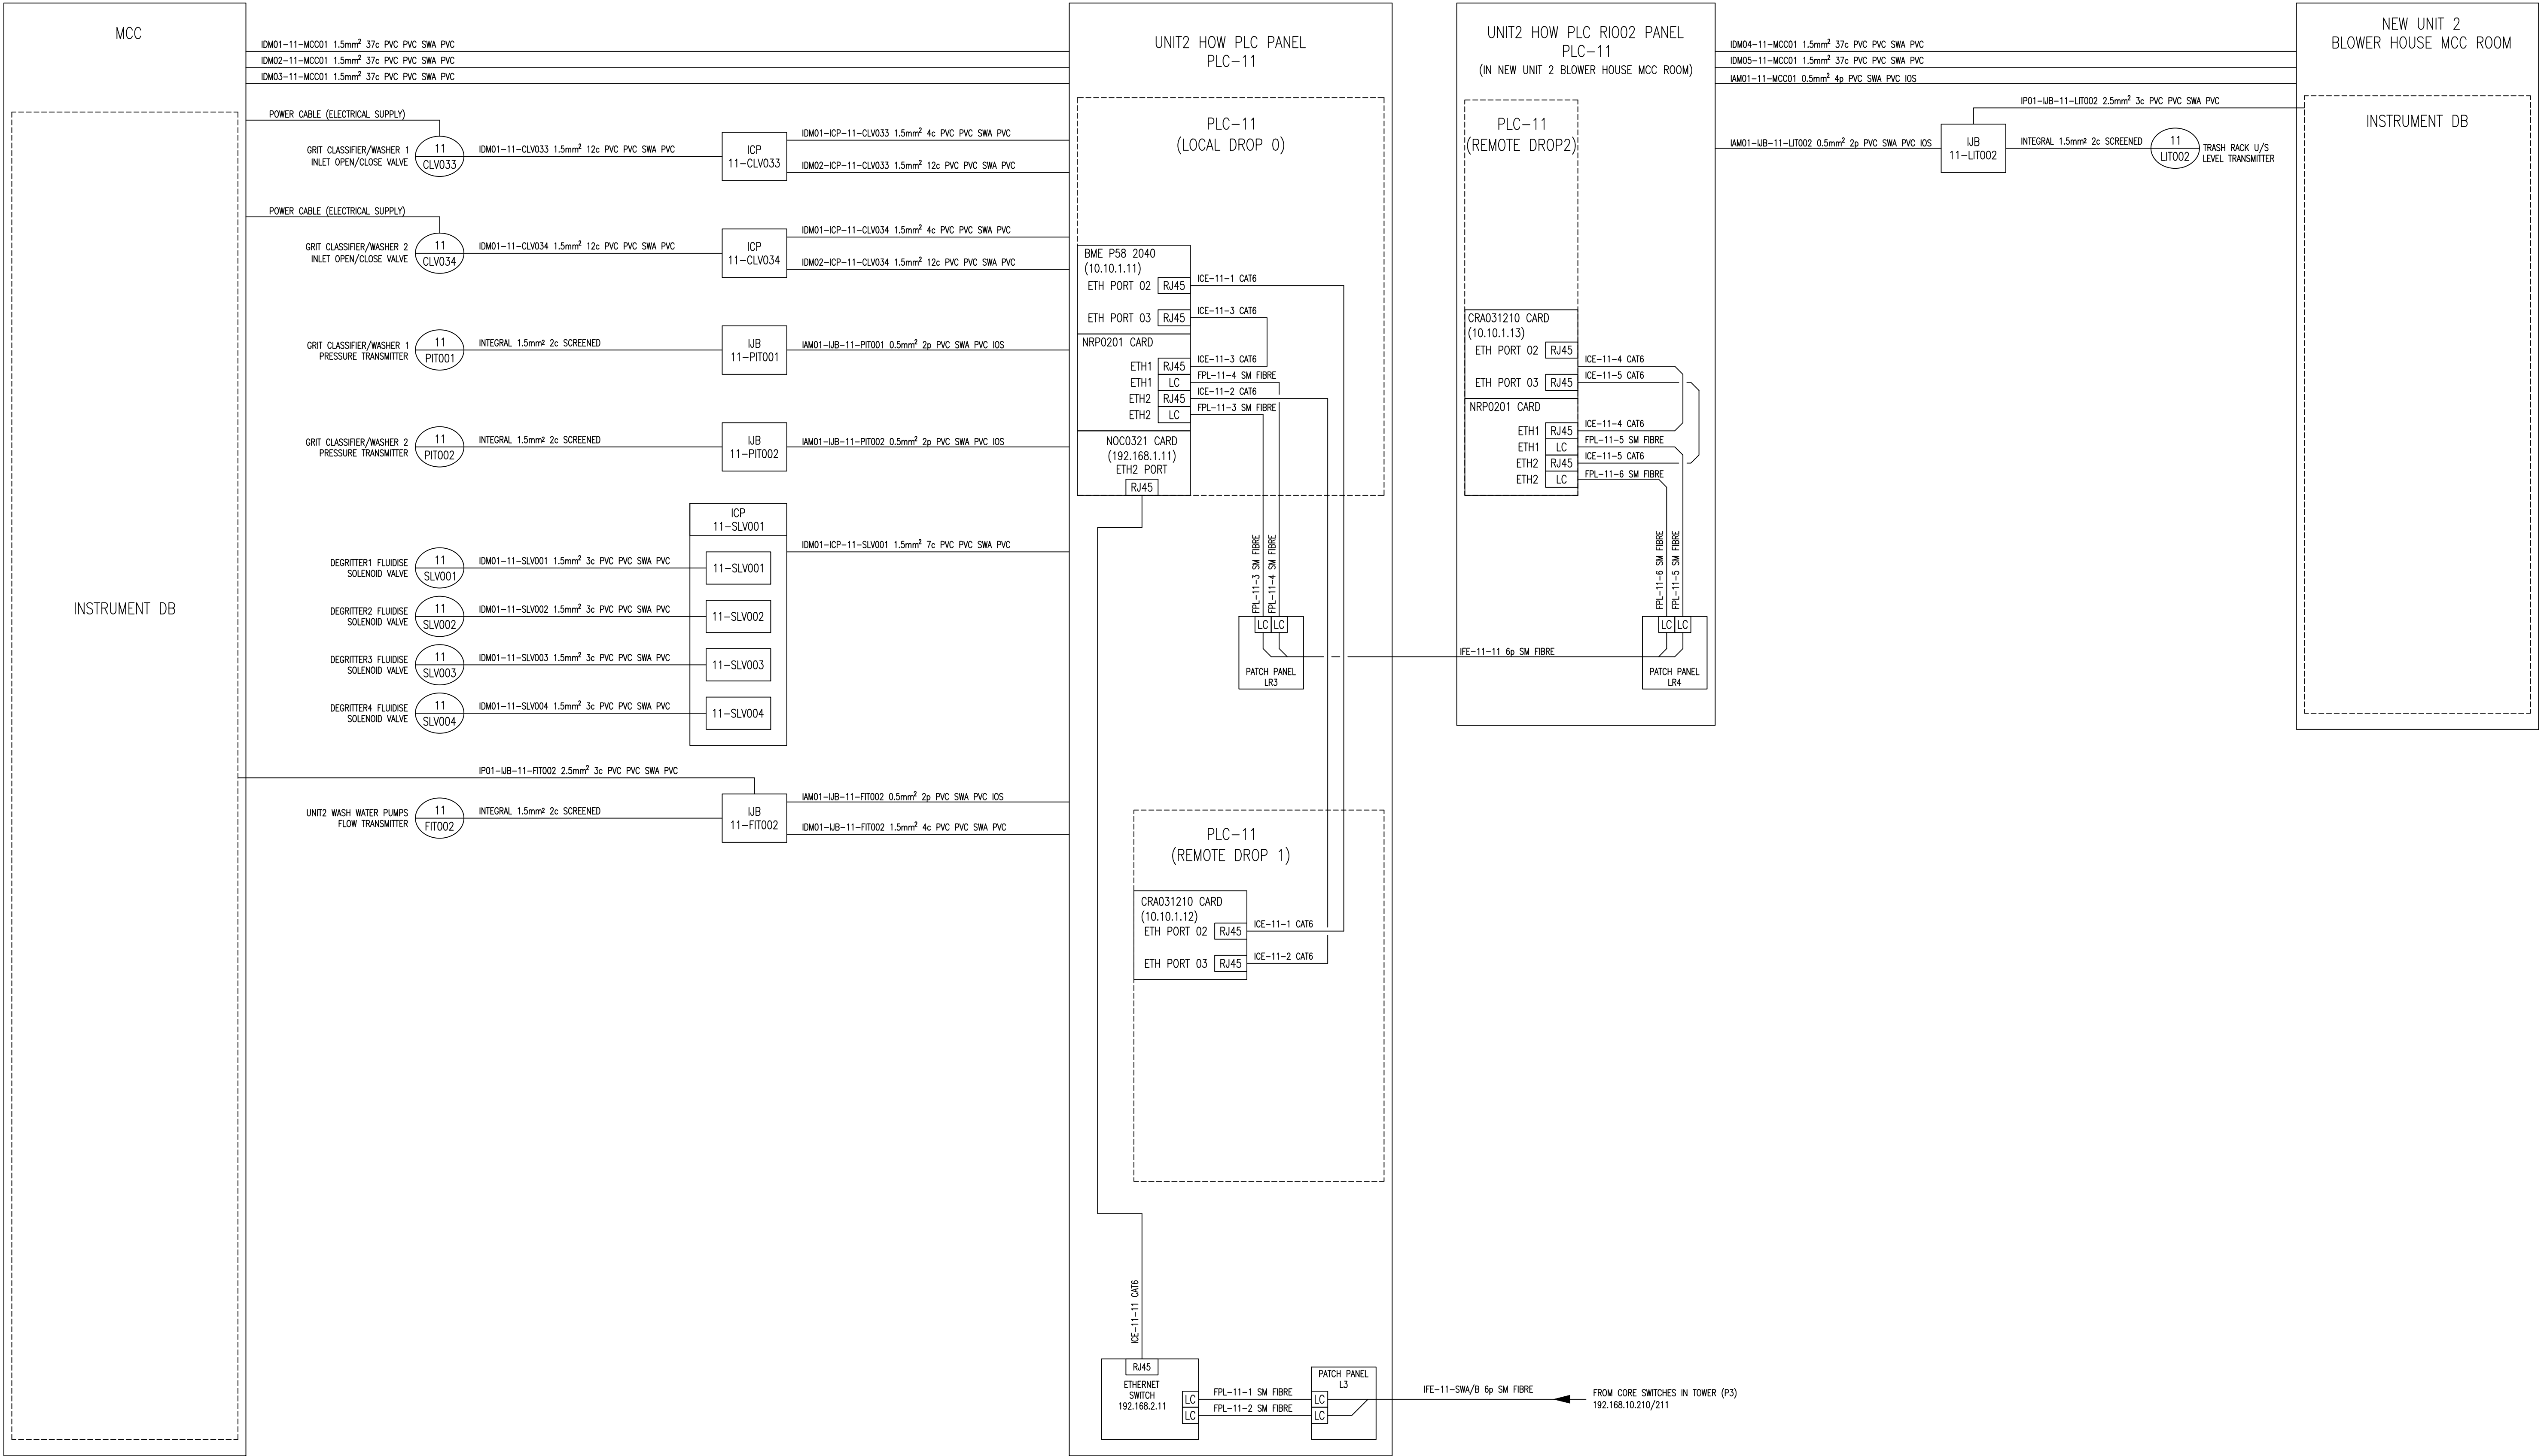

DEPARTMENT	APPROVED	DESIGNATION	DATE

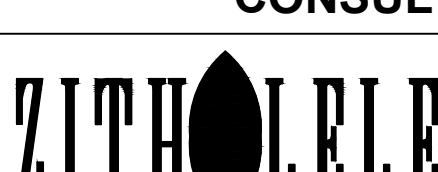CONSULTING ENGINEERS		SURVEYED		JOHANNESBURG WATER (SOC) LTD		CITY OF JOHANNESBURG		DESIGN MANAGER	SCALE	AMENDMENTS		APPROVED	DATE	DRAWING No.							
 ZITHOLELE P.O. BOX 6002 HALFWAY HOUSE, 1685 TEL: (011) 207 2060 FAX: (086) 674 6121 EMAIL: mail@zitholele.co.za	 WSP Group Africa (Pty) Ltd Building Services Building C, Knightsbridge, 33 Sloane Street, Bryanston, 2191 Tel: +27 11 361 1300 Fax: +27 11 361 1431 www.wsp.com	DESIGNED	W BRITZ	 Johannesburg Water	17 HARRISON STREET MARSHALLTOWN 2107	BUSHKOPPIE WASTEWATER TREATMENT WORKS INFRASTRUCTURE RENEWAL PLAN UNIT 2 HOW PLC-11 CABLE BLOCK DIAGRAM				DATE	NTS			T0	FOR TENDER	W BRITZ	16.08.21	JW NUMBER			
		DRAWN	M DYKE					T1	RE-ISSUED FOR TENDER			CdT	07.01.25	CONSULTANT'S NUMBER CI-11-CBD001							
		CHECKED												FILE No							
		SERVICES CHECKED																			
		GEO TECHNICAL INVESTIGATION																			
		SERVITUDES																			
		APPROVED																			
		Pr. Eng. No.				TEL: (011) 688-1400															
		DATE				FAX: (011) 688-1529															

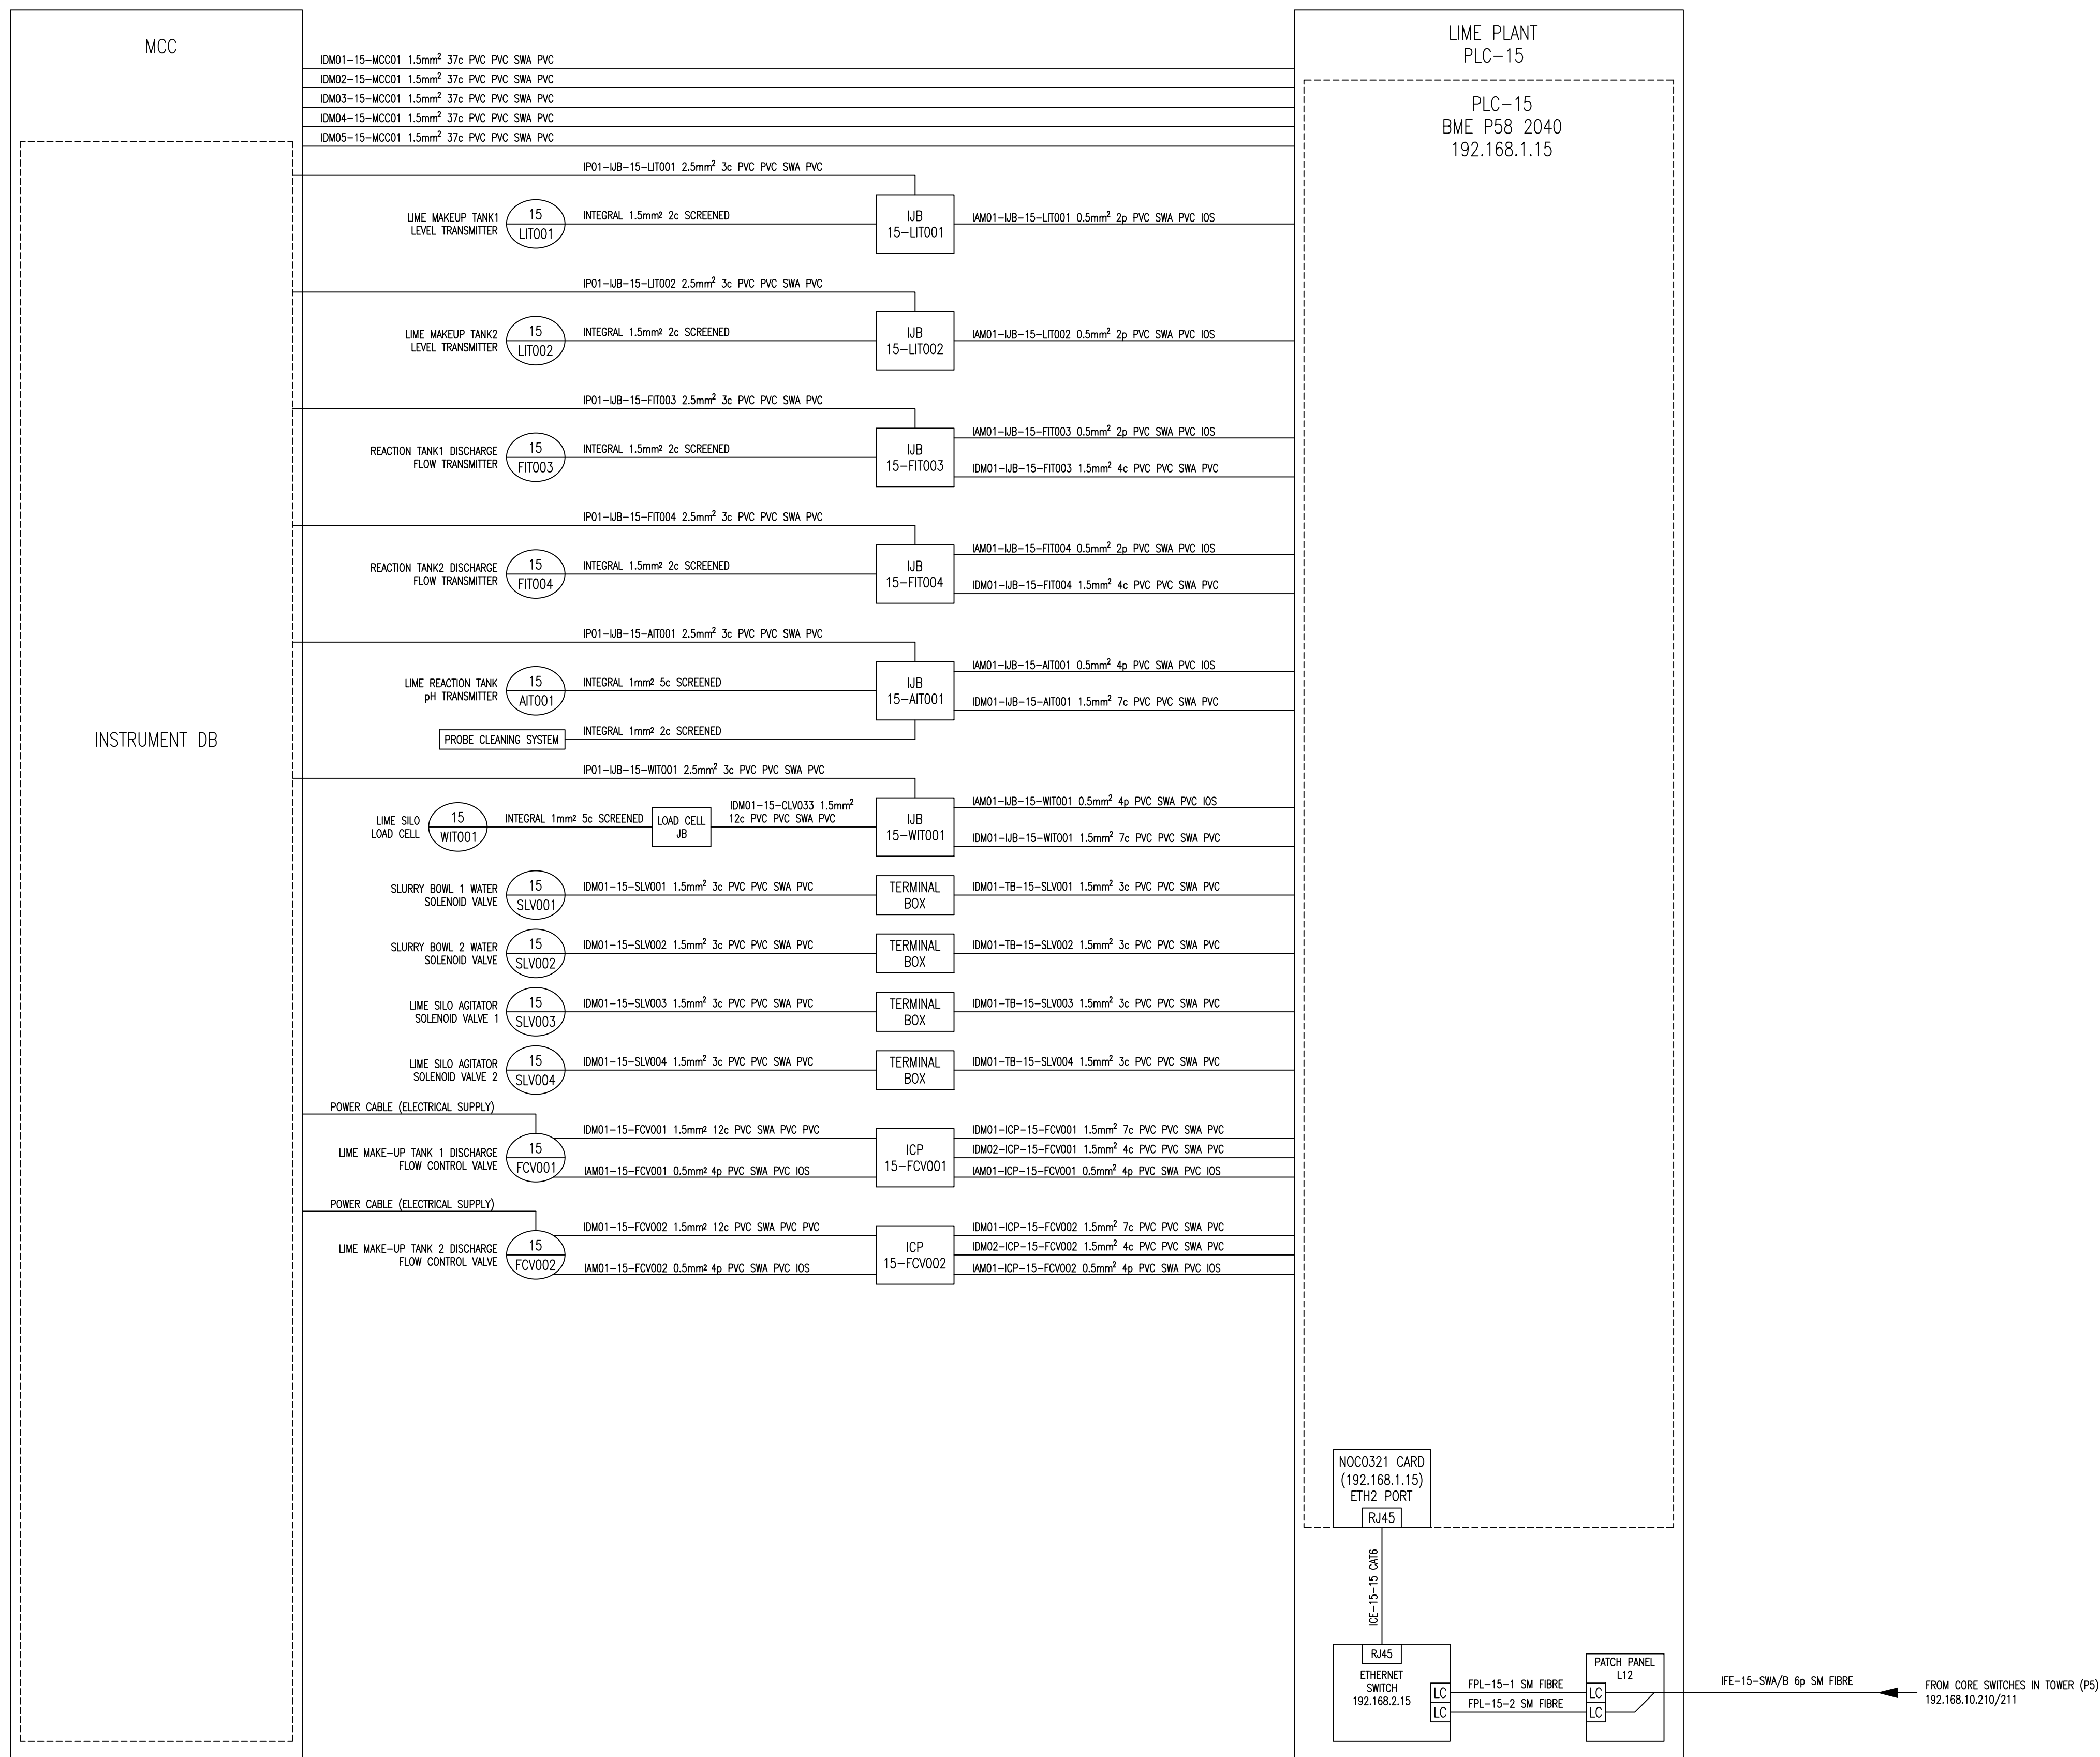

DEPARTMENT	APPROVED	DESIGNATION	DATE

[illegible]



LEGEND:

TRENCH

EXISTING TRENCH


CABLE RACK

DEPARTMENT	APPROVED	DESIGNATION	DATE

CONSULTING ENGINEERS		SURVEYED		JOHANNESBURG WATER (SOC) LTD		DESIGN MANAGER	CITY OF JOHANNESBURG		AMENDMENTS		BY	DATE	DRAWING No.	
 ZITHOLELE CONSULTING P.O. BOX 6002 HALFWAY HOUSE, 1685 TEL: (011) 207 2060 FAX: (011) 674 6121 EMAIL: mail@zitholele.co.za	 WSP Group Africa (Pty) Ltd Building Services 33 Sloane Street, Bryanston, 2191 Tel: +27 11 361 1300 Fax: +27 11 361 1431 www.wsp.com	DESIGNED	W BRITZ	 Johannesburg Water 17 HARRISON STREET MARSHALLTOWN 2107 TEL: (011) 688-1400 FAX: (011) 688-1529		DATE	BUSHKOPPIE WWTW INFRASTRUCTURE RENEWAL PLAN HOW EQUIPMENT AND CABLE ROUTE LAYOUT		T0	FOR TENDER	W BRITZ	16.08.21	JW NUMBER	
		DRAWN	M DYKE						T1	RE-ISSUED FOR TENDER	CdT	07.01.25	CONSULTANT'S NUMBER	
		CHECKED											CI-00-CT0001	
		SERVICES CHECKED											FILE No	
		GEOTECHNICAL INVESTIGATION											TO T1	
		SERVITUDES												
		APPROVED Pr. Eng. No.	DATE											



LIME PLANT
CABLE ROUTE

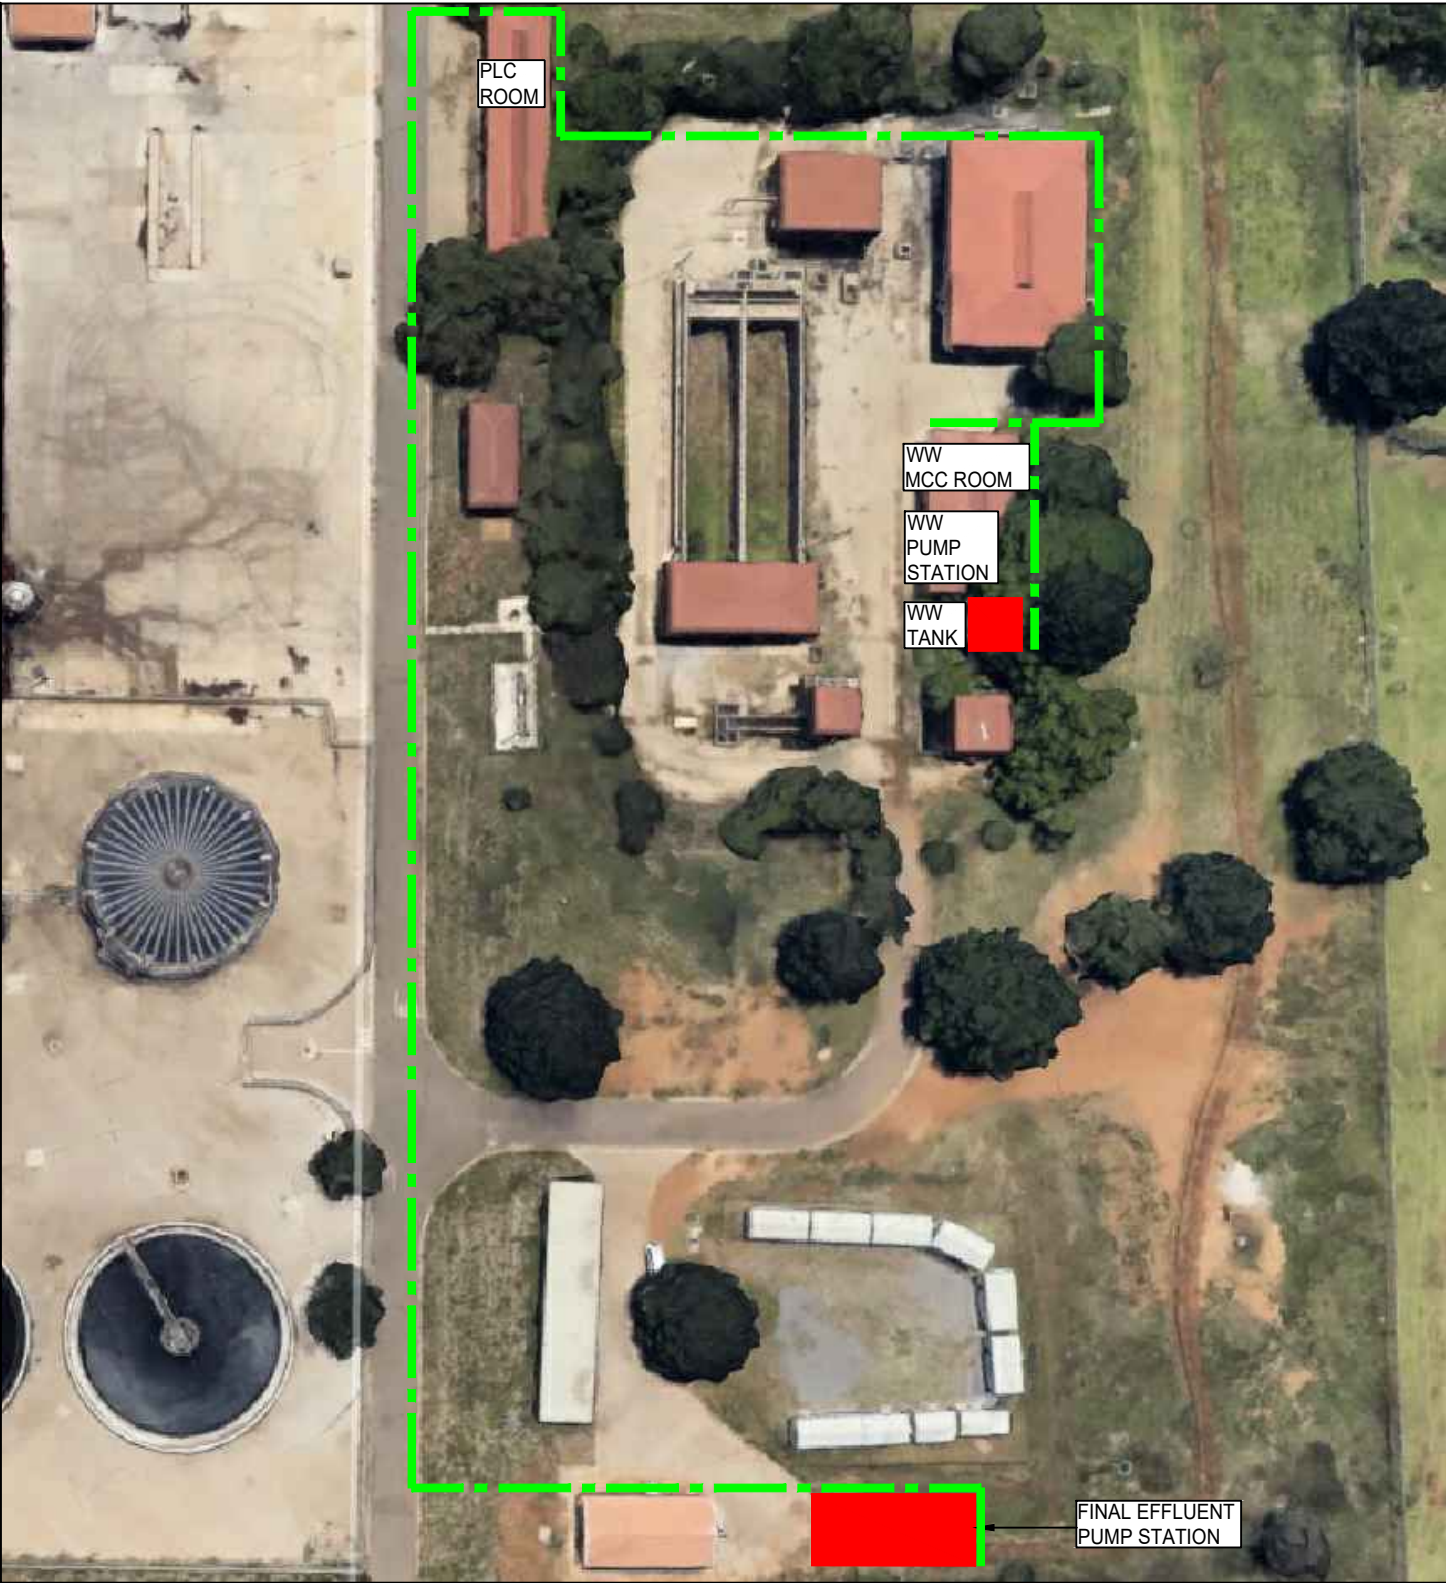

WASH WATER AND FINAL EFFLUENT
CABLE ROUTE




EMERGENCY DAM
CABLE ROUTE

LEGEND:

- TRENCH
- EXISTING TRENCH

DEPARTMENT	CABLE ROUTE	DESIGNATION	DATE


CONSULTING ENGINEERS		SURVEYED		JOHANNESBURG WATER (SOC) LTD		DESIGN MANAGER		CITY OF JOHANNESBURG		AMENDMENTS		BY	DATE	DRAWING No.	
ZITHOLELE CONSULTING ZITHOLELE P.O. BOX 6002 HALFWAY HOUSE, 1685 TEL: (011) 207 2060 FAX: (011) 674 6121 EMAIL: mail@zitholele.co.za	wsp WSP Group Africa (Pty) Ltd Building Services 33 Sloane Street, Bryanston, 2191 Tel: +27 11 361 1300 Fax: +27 11 361 1431 www.wsp.com	DESIGNED	W BRITZ	 Johannesburg Water 17 HARRISON STREET MARSHALLTOWN 2107 TEL: (011) 688-1400 FAX: (011) 688-1529	DATE	SCALE	BUSHKOPPIE WWTW INFRASTRUCTURE RENEWAL PLAN LIME PLANT, WASH WATER, FINAL EFFLUENT AND EMERGENCY DAM EQUIPMENT LAYOUT AND CABLE ROUTE		T0	FOR TENDER	W BRITZ	16.08.21	JW NUMBER		
		DRAWN	M DYKE						T1	REISSUED FOR TENDER	CdT	07.01.25	CONSULTANT'S NUMBER		
		CHECKED											CI-00-CT0002		
		SERVICES CHECKED											FILE No		
		GEOTECHNICAL INVESTIGATION											TO T1		
		SERVITUDES													
APPROVED	DATE														
Pr. Eng. No.															

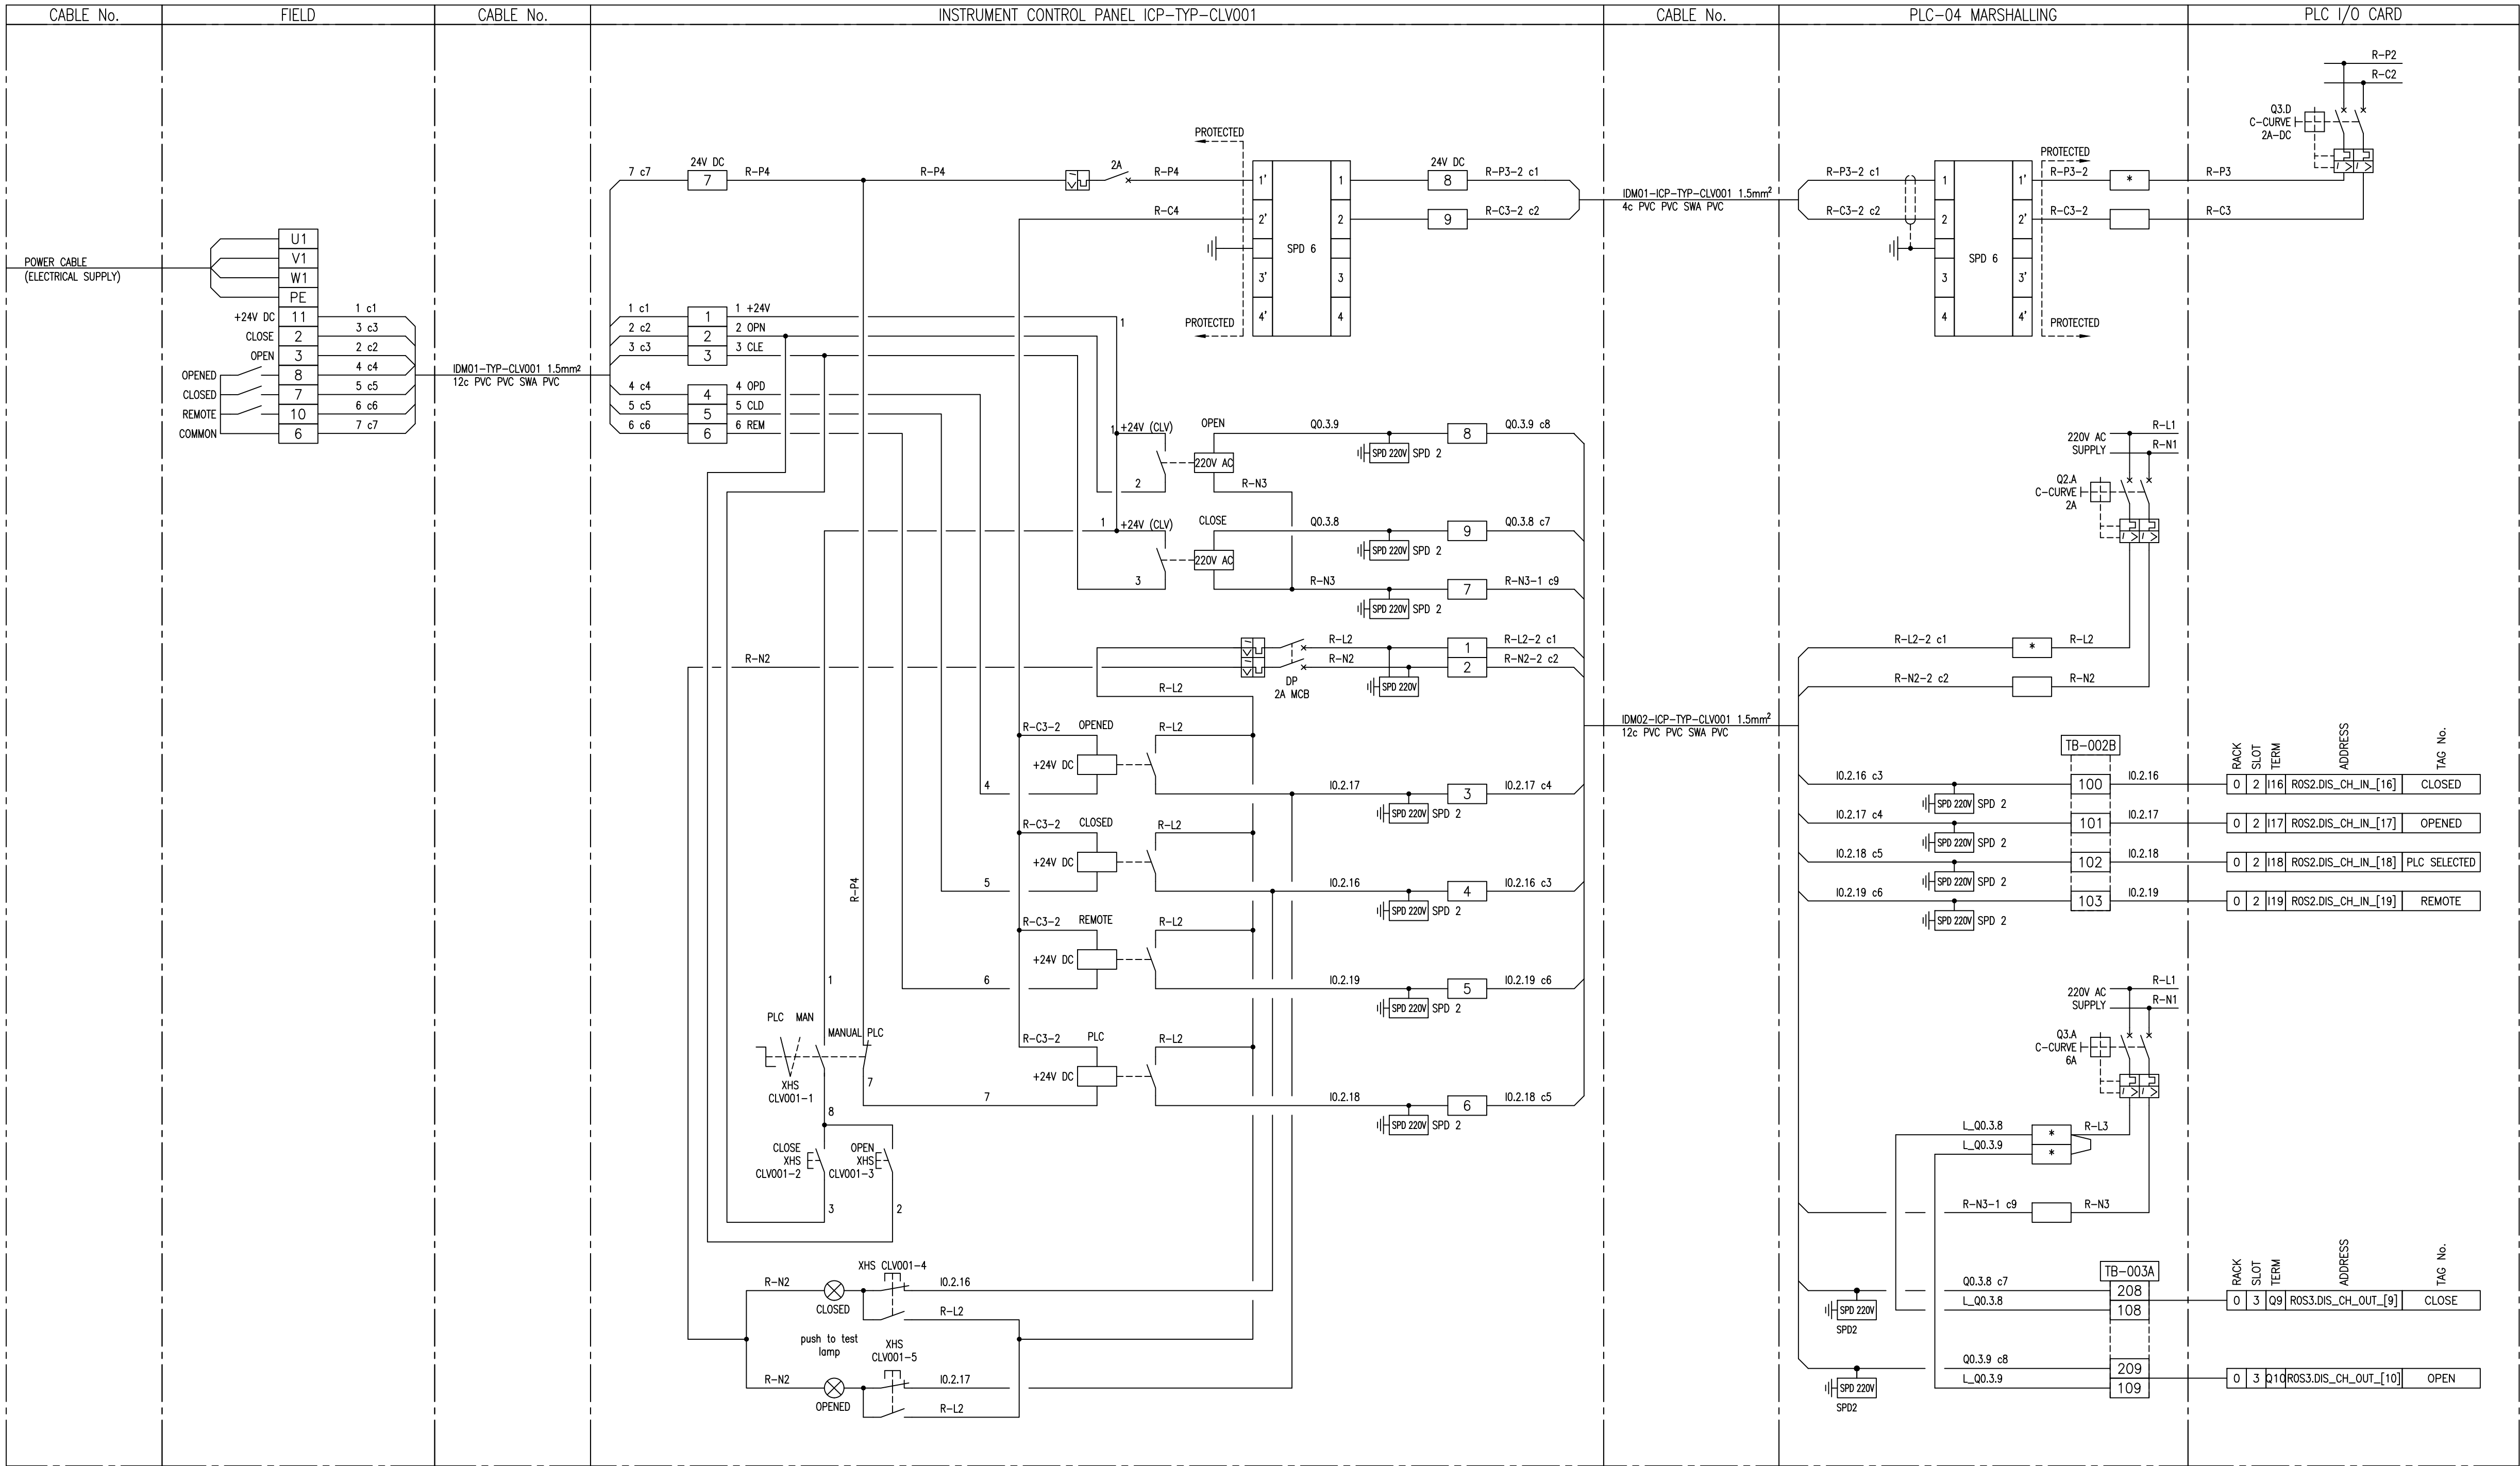

- NOTES:
1. EARTH CORE MUST BE YELLOW/GREEN OR IT MUST BE FITTED WITH A YELLOW/GREEN SLEEVE.
- SUB-BASE 1: ABE-7516ZM0: 230V AC DIGITAL INPUT
SUB-BASE 2: ABE-7CPA02: 8ch ANALOG INPUT
SUB-BASE 3: ABE-7R16S210: RELAY OUTPUT
SUB-BASE 4: ABE-7CPA21: 4ch ANALOG OUTPUT
- SPD 1: DEHNgard DG M TN 275
SPD 2: DEHNgard DG S 275 VA
SPD 3: BLITZDUCTOR BXT ML4 BD 24 + BASE BXT BAS
SPD 4: BLITZDUCTOR BXT ML2 BD S 24 + BASE BXT BAS
SPD 5: BLITZDUCTOR BXT ML4 BE 24 + BASE BXT BAS
SPD 6: BLITZDUCTOR BXT ML2 BE S 24 + BASE BXT BAS
- * FUSED TERMINAL (500mA)
□ LINK TERMINAL


DEPARTMENT	APPROVED	DESIGNATION	DATE


CONSULTING ENGINEERS		SURVEYED		JOHANNESBURG WATER SOC LTD		CITY OF JOHANNESBURG		DESIGN MANAGER	SCALE	AMENDMENTS	APPROVED	DATE	DRAWING No.																																																																																																																																																																																																																																																																																																																																																																																																																																																																																																																																																							
 P.O. BOX 221 RIVONIA 2128 TEL: 011-806 7111 FAX: 011-806 7100 EMAIL: enquiries@kprsa.co.za	 WSP Group Africa (Pty) Ltd Industrial Division Building C, Knightsbridge, 33 Sloane Street, Bryanston, 2191 Tel: +27 11 361 1300 Fax: +27 11 361 1431 www.wsp.com	DESIGNED	W BRITZ	 Johannesburg Water	17 HARRISON STREET MARSHALLTOWN 2107	BUSHKOPPIE WASTEWATER TREATMENT WORKS INFRASTRUCTURE RENEWAL PLAN							OPEN/CLOSE VALVE – CLV001 TYPICAL LOOP DIAGRAM	DATE	TO	T1																																																																																																																																																																																																																																																																																																																																																																																																																																																																																																																																																				

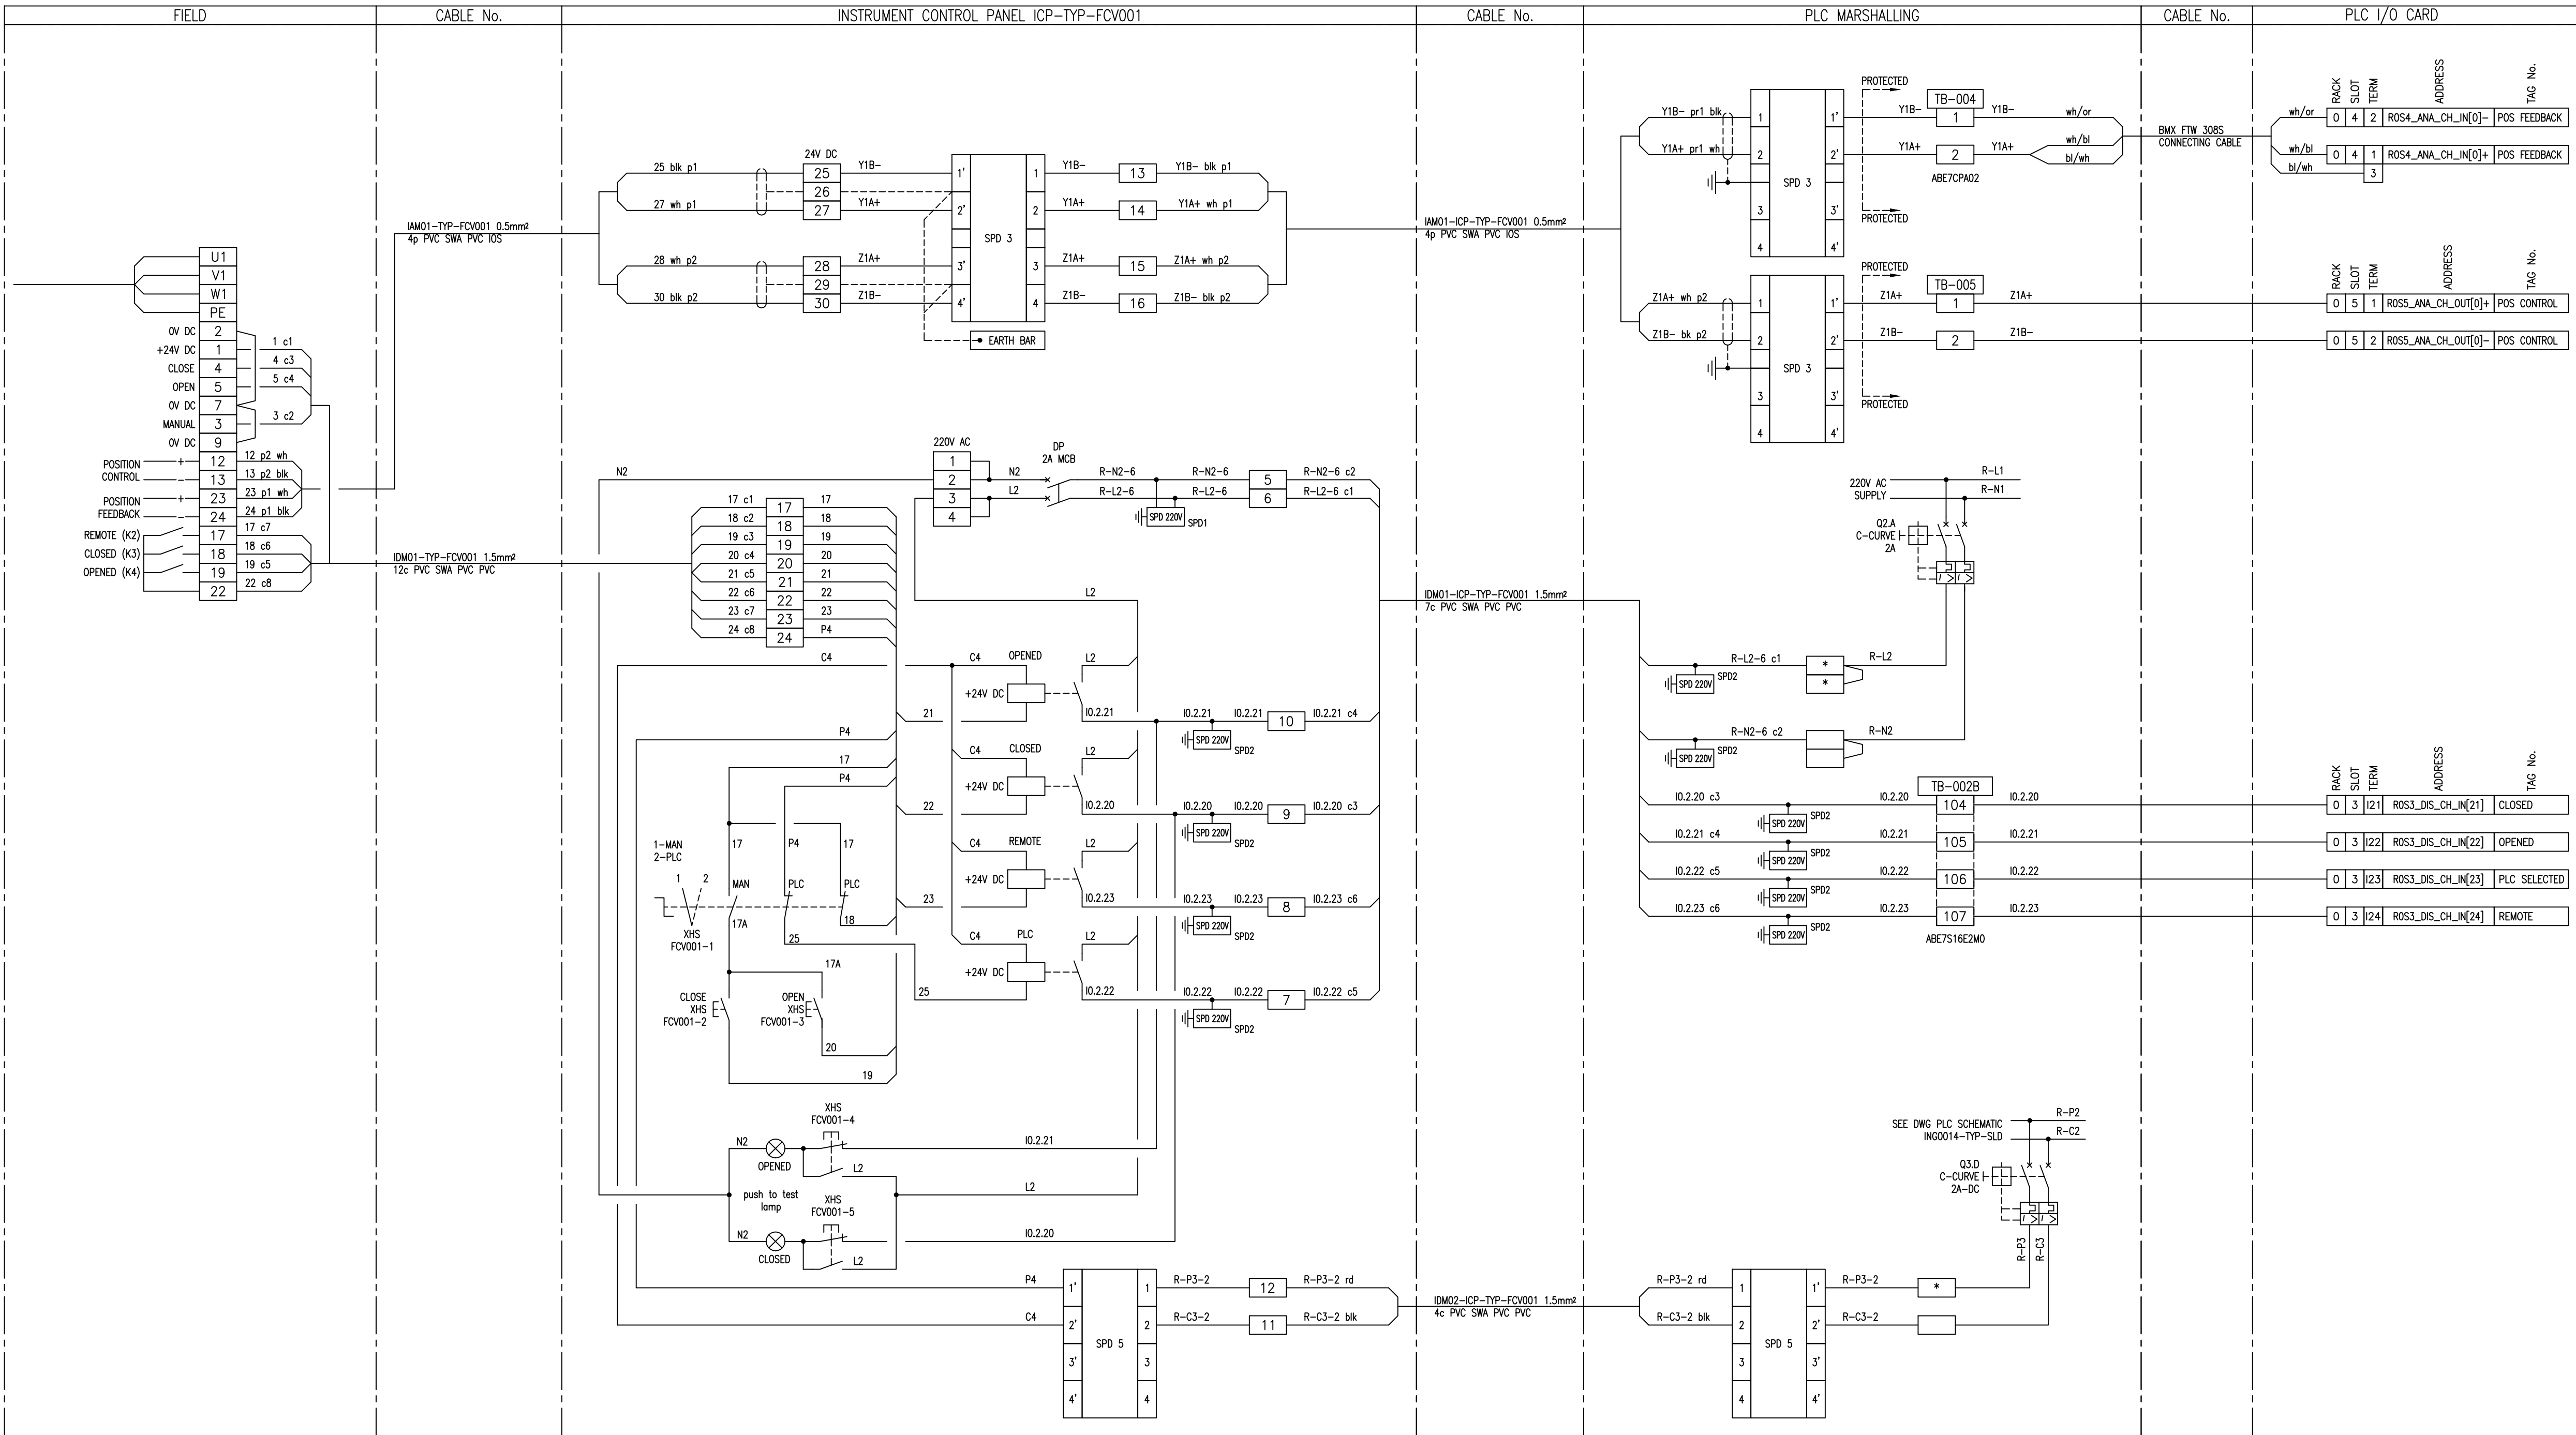

- NOTES:
1. EARTH CORE MUST BE YELLOW/GREEN OR IT MUST BE FITTED WITH A YELLOW/GREEN SLEEVE.
- SUB-BASE 1: ABE-7S16ZM0: 230V AC DIGITAL INPUT
SUB-BASE 2: ABE-7CPA02: 8ch ANALOG INPUT
SUB-BASE 3: ABE-7R16S210: RELAY OUTPUT
SUB-BASE 4: ABE-7CPA21: 4ch ANALOG OUTPUT
- SPD 1: DEHNgard DG M TN 275
SPD 2: DEHNgard DG S 275 VA
SPD 3: BLITZDUCTOR BXT ML4 BD 24 + BASE BXT BAS
SPD 4: BLITZDUCTOR BXT ML2 BD S 24 + BASE BXT BAS
SPD 5: BLITZDUCTOR BXT ML4 BE 24 + BASE BXT BAS
SPD 6: BLITZDUCTOR BXT ML2 BE S 24 + BASE BXT BAS
- * FUSED TERMINAL (500mA)
□ LINK TERMINAL

DEPARTMENT	APPROVED	DESIGNATION	DATE

 
CONSULTING ENGINEERS		SURVEYED		JOHANNESBURG WATER SOC LTD		CITY OF JOHANNESBURG		DESIGN MANAGER	SCALE	AMENDMENTS		APPROVED	DATE	DRAWING No.						
 P.O. BOX 221 RIVONIA 2128 TEL. 011-806 7111 FAX. 011-806 7100 EMAIL: enquiries@kprsa.co.za	 WSP Group Africa (Pty) Ltd Industrial Division Building C, Knightsbridge, 33 Sloane Street, Bryanston, 2191 Tel: +27 11 361 1300 Fax: +27 11 361 1431 www.wsp.com	DESIGNED	W BRITZ	 17 HARRISON STREET MARSHALLTOWN 2107 TEL: (011) 688-1400 FAX: (011) 688-1529	BUSHKOPPIE WASTEWATER TREATMENT WORKS INFRASTRUTURE RENEWAL PLAN FLOW CONTROL VALVE – FCV001 TYPICAL LOOP DIAGRAM		DATE			NTS	T0			ISSUED FOR TENDER	W BRITZ	08.08.19	JW NUMBER			
		T1	RE-ISSUED FOR TENDER					CdT	07.01.25		CONSULTANT'S NUMBER TYP – FCV001									
		FILE No																		
		TO T1																		

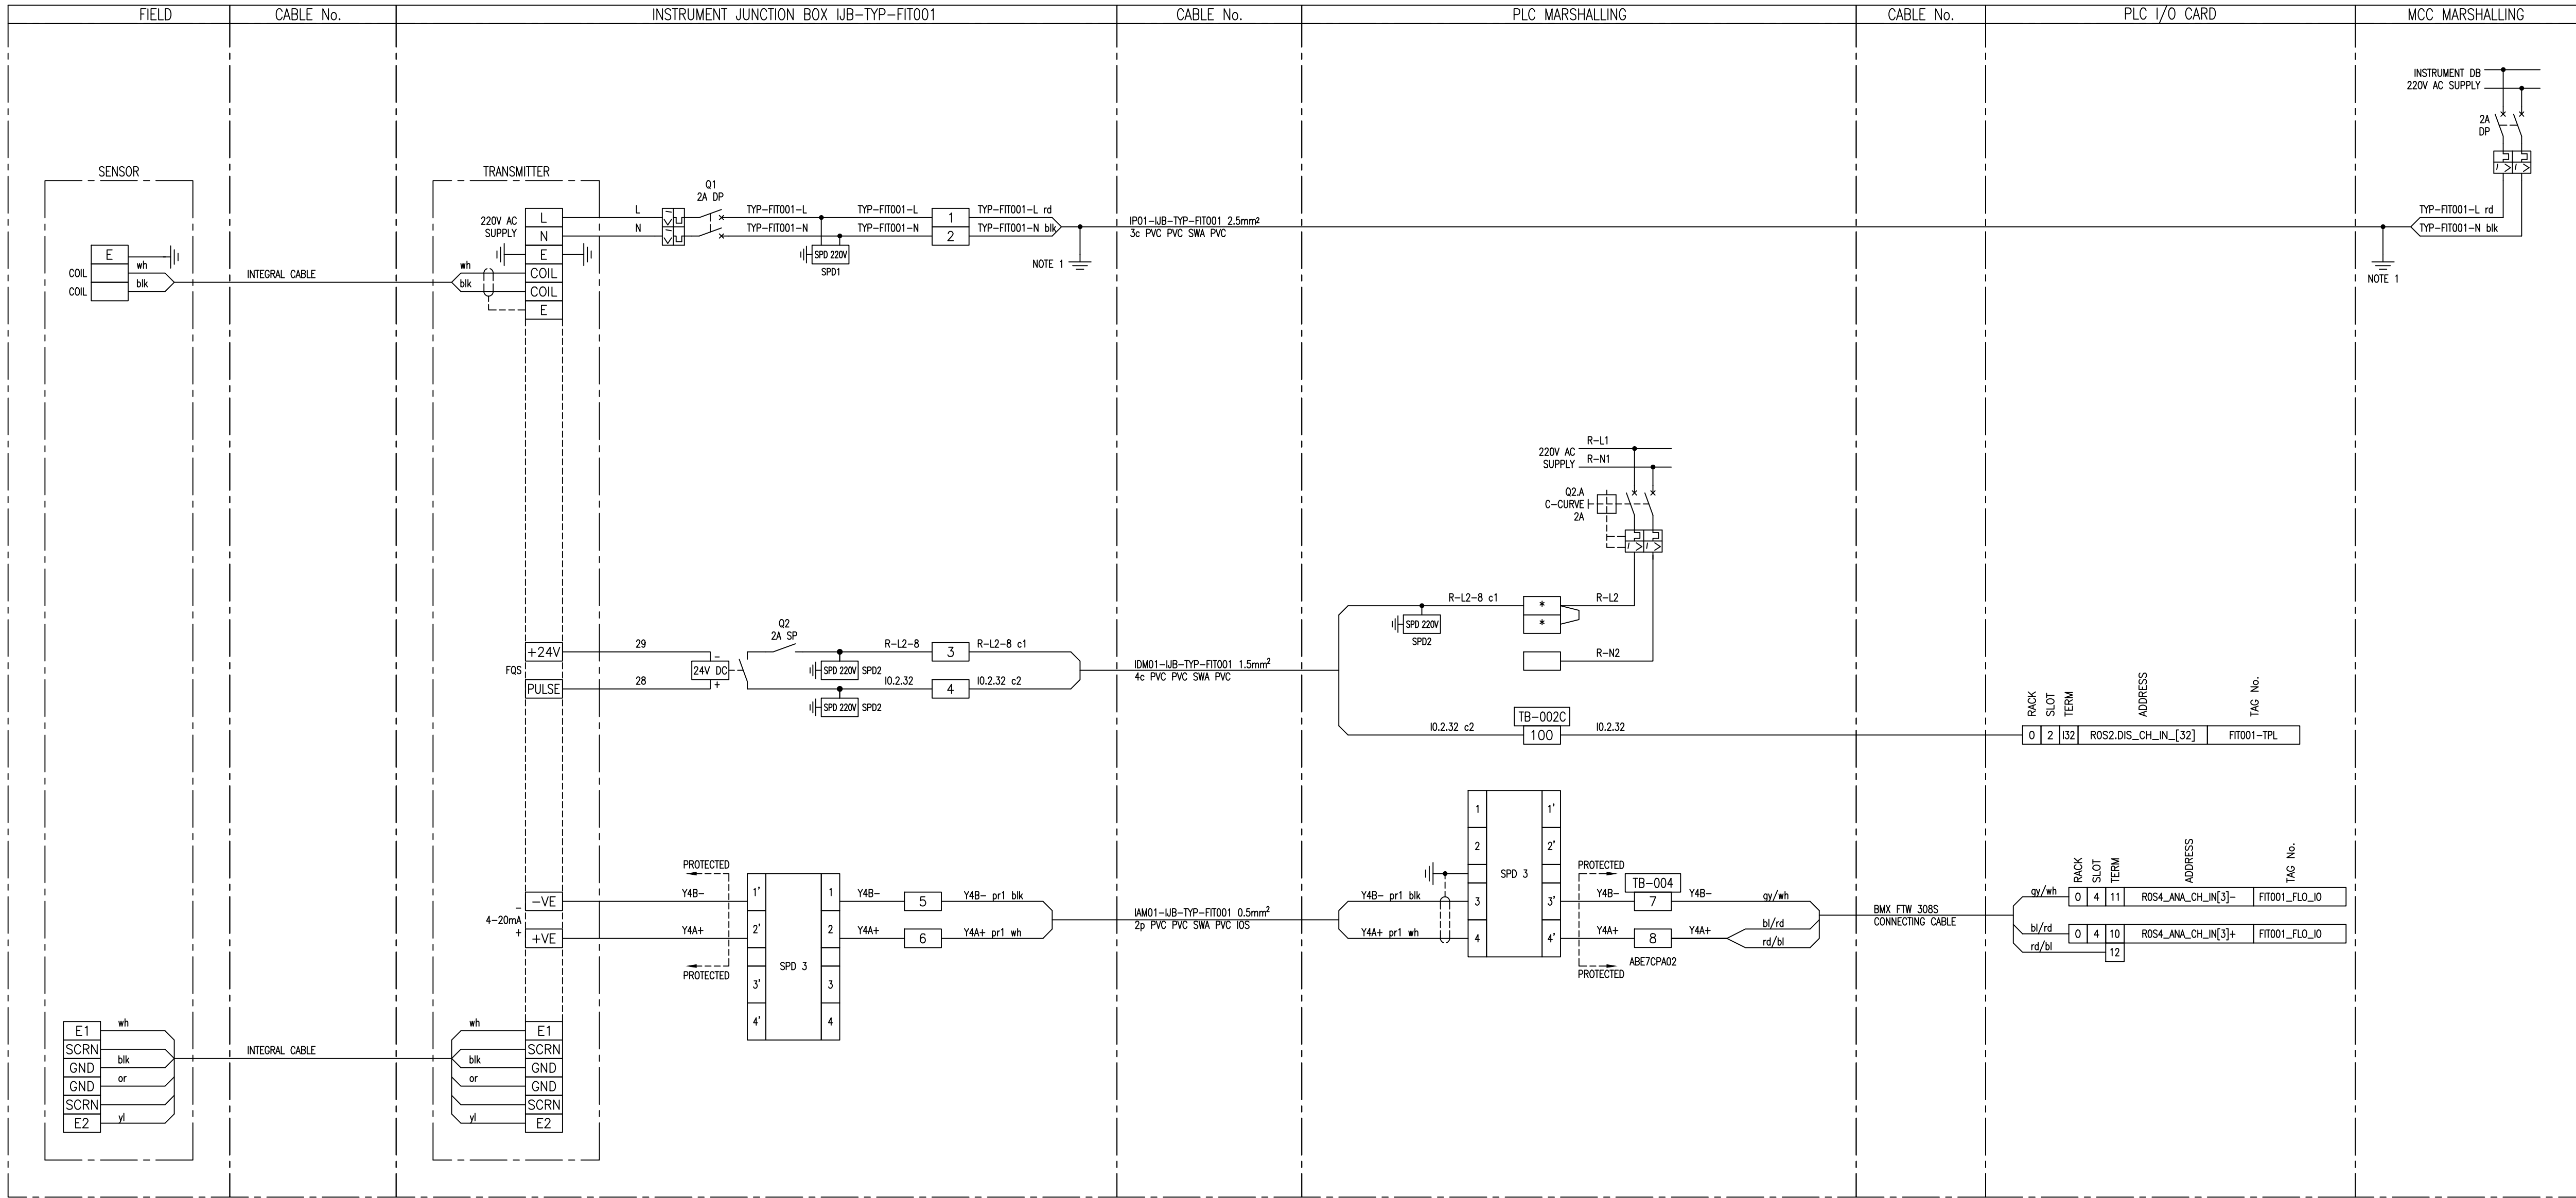


- NOTES:
1. EARTH CORE MUST BE YELLOW/GREEN OR IT MUST BE FITTED WITH A YELLOW/GREEN SLEEVE.
 - SUB-BASE 1: ABE-7S16ZM0: 230V AC DIGITAL INPUT
 - SUB-BASE 2: ABE-7CPA02: 8ch ANALOG INPUT
 - SUB-BASE 3: ABE-7R16S210: RELAY OUTPUT
 - SUB-BASE 4: ABE-7CPA21: 4ch ANALOG OUTPUT
 - SPD 1: DEHNgard DG M TN 275
 - SPD 2: DEHNgard DG S 275 VA
 - SPD 3: BLITZDUCTOR BXT ML4 BD 24 + BASE BXT BAS
 - SPD 4: BLITZDUCTOR BXT ML2 BD S 24 + BASE BXT BAS
 - SPD 5: BLITZDUCTOR BXT ML4 BE 24 + BASE BXT BAS
 - SPD 6: BLITZDUCTOR BXT ML2 BE S 24 + BASE BXT BAS

- * FUSED TERMINAL (500mA)
□ LINK TERMINAL

DEPARTMENT	APPROVED	DESIGNATION	DATE

 
CONSULTING ENGINEERS			SURVEYED		JOHANNESBURG WATER SOC LTD		CITY OF JOHANNESBURG		DESIGN MANAGER	SCALE	AMENDMENTS		APPROVED	DATE	DRAWING No.								
 Knight Piésold CONSULTING P.O. BOX 221 RIVONIA 2128 TEL. 011-806 7111 FAX. 011-806 7100 EMAIL: enquiries@kprsa.co.za	 WSP Group Africa (Pty) Ltd Industrial Division Building C, Knightsbridge, 33 Sloane Street, Bryanston, 2191 Tel: +27 11 361 1300 Fax: +27 11 361 1431 www.wsp.com	DESIGNED	W BRITZ	 Johannesburg Water	17 HARRISON STREET MARSHALLTOWN 2107 TEL: (011) 688-1400 FAX: (011) 688-1529	BUSHKOPPIE WASTEWATER TREATMENT WORKS INFRASTRCTURE RENEWAL PLAN MAGFLOW METER – FIT001 TYPICAL LOOP DIAGRAM	DATE	NTS			T0	ISSUED FOR TENDER			W BRITZ	08.08.19	JW NUMBER						
		DRAWN	M DYKE								T1	RE-ISSUED FOR TENDER			CdT	07.01.25	CONSULTANT'S NUMBER						
		CHECKED	W BRITZ								TYP – FIT001												
		SERVICES CHECKED									FILE No												
		GEOTECHNICAL INVESTIGATION									TO T1												
SERVITUDES																							
APPROVED	Pr. Eng. No.																						
DATE																							

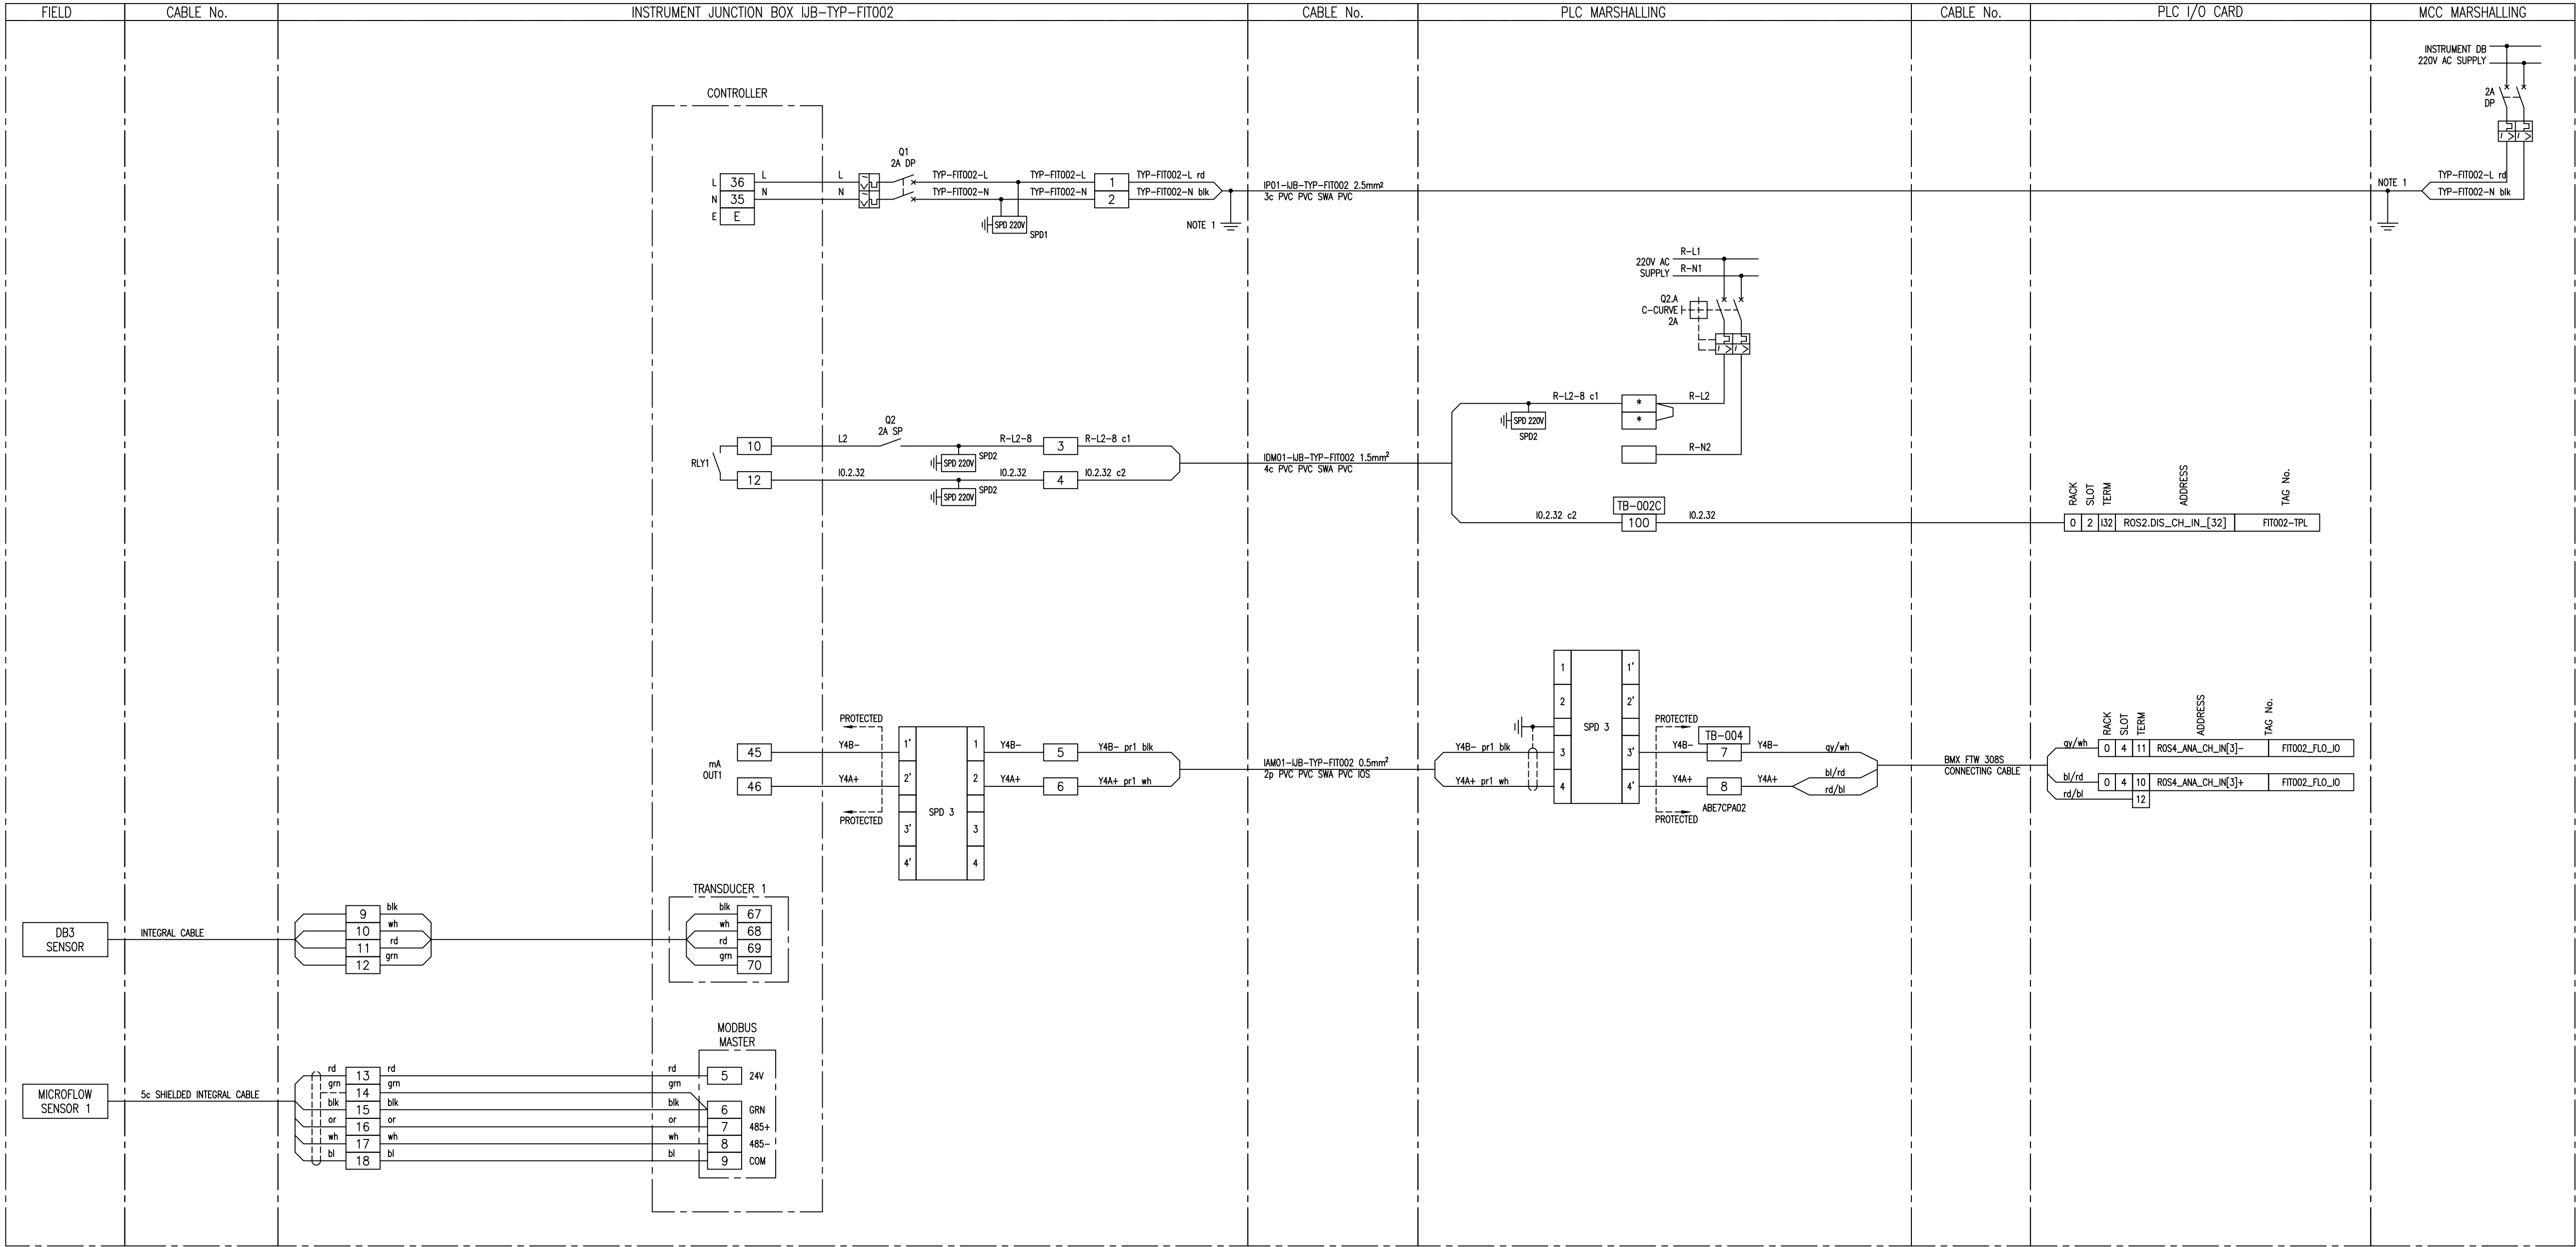

- NOTES:
1. EARTH CORE MUST BE YELLOW/GREEN OR IT MUST BE FITTED WITH A YELLOW/GREEN SLEEVE.
- SUB-BASE 1: ABE-7S16E2M0: 230V AC DIGITAL INPUT
- SUB-BASE 2: ABE-7CPA02: 8ch ANALOG INPUT
- SUB-BASE 3: ABE-7R16S210: RELAY OUTPUT
- SUB-BASE 4: ABE-7CPA21: 4ch ANALOG OUTPUT
- SPD 1: DEHNguard DG M TN 275
- SPD 2: DEHNguard DG S 275 VA
- SPD 3: BLITZDUCTOR BXT ML4 BD 24 + BASE BXT BAS
- SPD 4: BLITZDUCTOR BXT ML2 BD S 24 + BASE BXT BAS
- SPD 5: BLITZDUCTOR BXT ML4 BE 24 + BASE BXT BAS
- SPD 6: BLITZDUCTOR BXT ML2 BE S 24 + BASE BXT BAS
- * FUSED TERMINAL (500mA)
- LINK TERMINAL

DEPARTMENT	APPROVED	DESIGNATION	DATE




CONSULTING ENGINEERS		SURVEYED		JOHANNESBURG WATER SOC LTD		CITY OF JOHANNESBURG		DESIGN MANAGER	SCALE	AMENDMENTS		APPROVED	DATE	DRAWING No.						
 P.O. BOX 221 RIVONIA 2128 TEL. 011-806 7111 FAX. 011-806 7100 EMAIL. enquiries@kprsa.co.za	 WSP Group Africa (Pty) Ltd Industrial Division Building C, Knightsbridge, 33 Sloane Street, Bryanston, 2191 Tel: +27 11 361 1300 Fax: +27 11 361 1431 www.wsp.com	DESIGNED	W BRITZ	 17 HARRISON STREET MARSHALLTOWN 2107 TEL: (011) 688-1400 FAX: (011) 688-1529	BUSHKOPPIE WASTEWATER TREATMENT WORKS INFRASTRUCTURE RENEWAL PLAN AREA VELOCITY FLOW METER – FIT002 TYPICAL LOOP DIAGRAM	DATE	NTS			T0	ISSUED FOR TENDER			W BRITZ	08.08.19	JW NUMBER				
		T1	RE-ISSUED FOR TENDER							CdT	07.01.25	CONSULTANT'S NUMBER TYP–FIT002								
														FILE No						
		APPROVED	Pr. Eng. No.										T0	T1						
		DATE																		

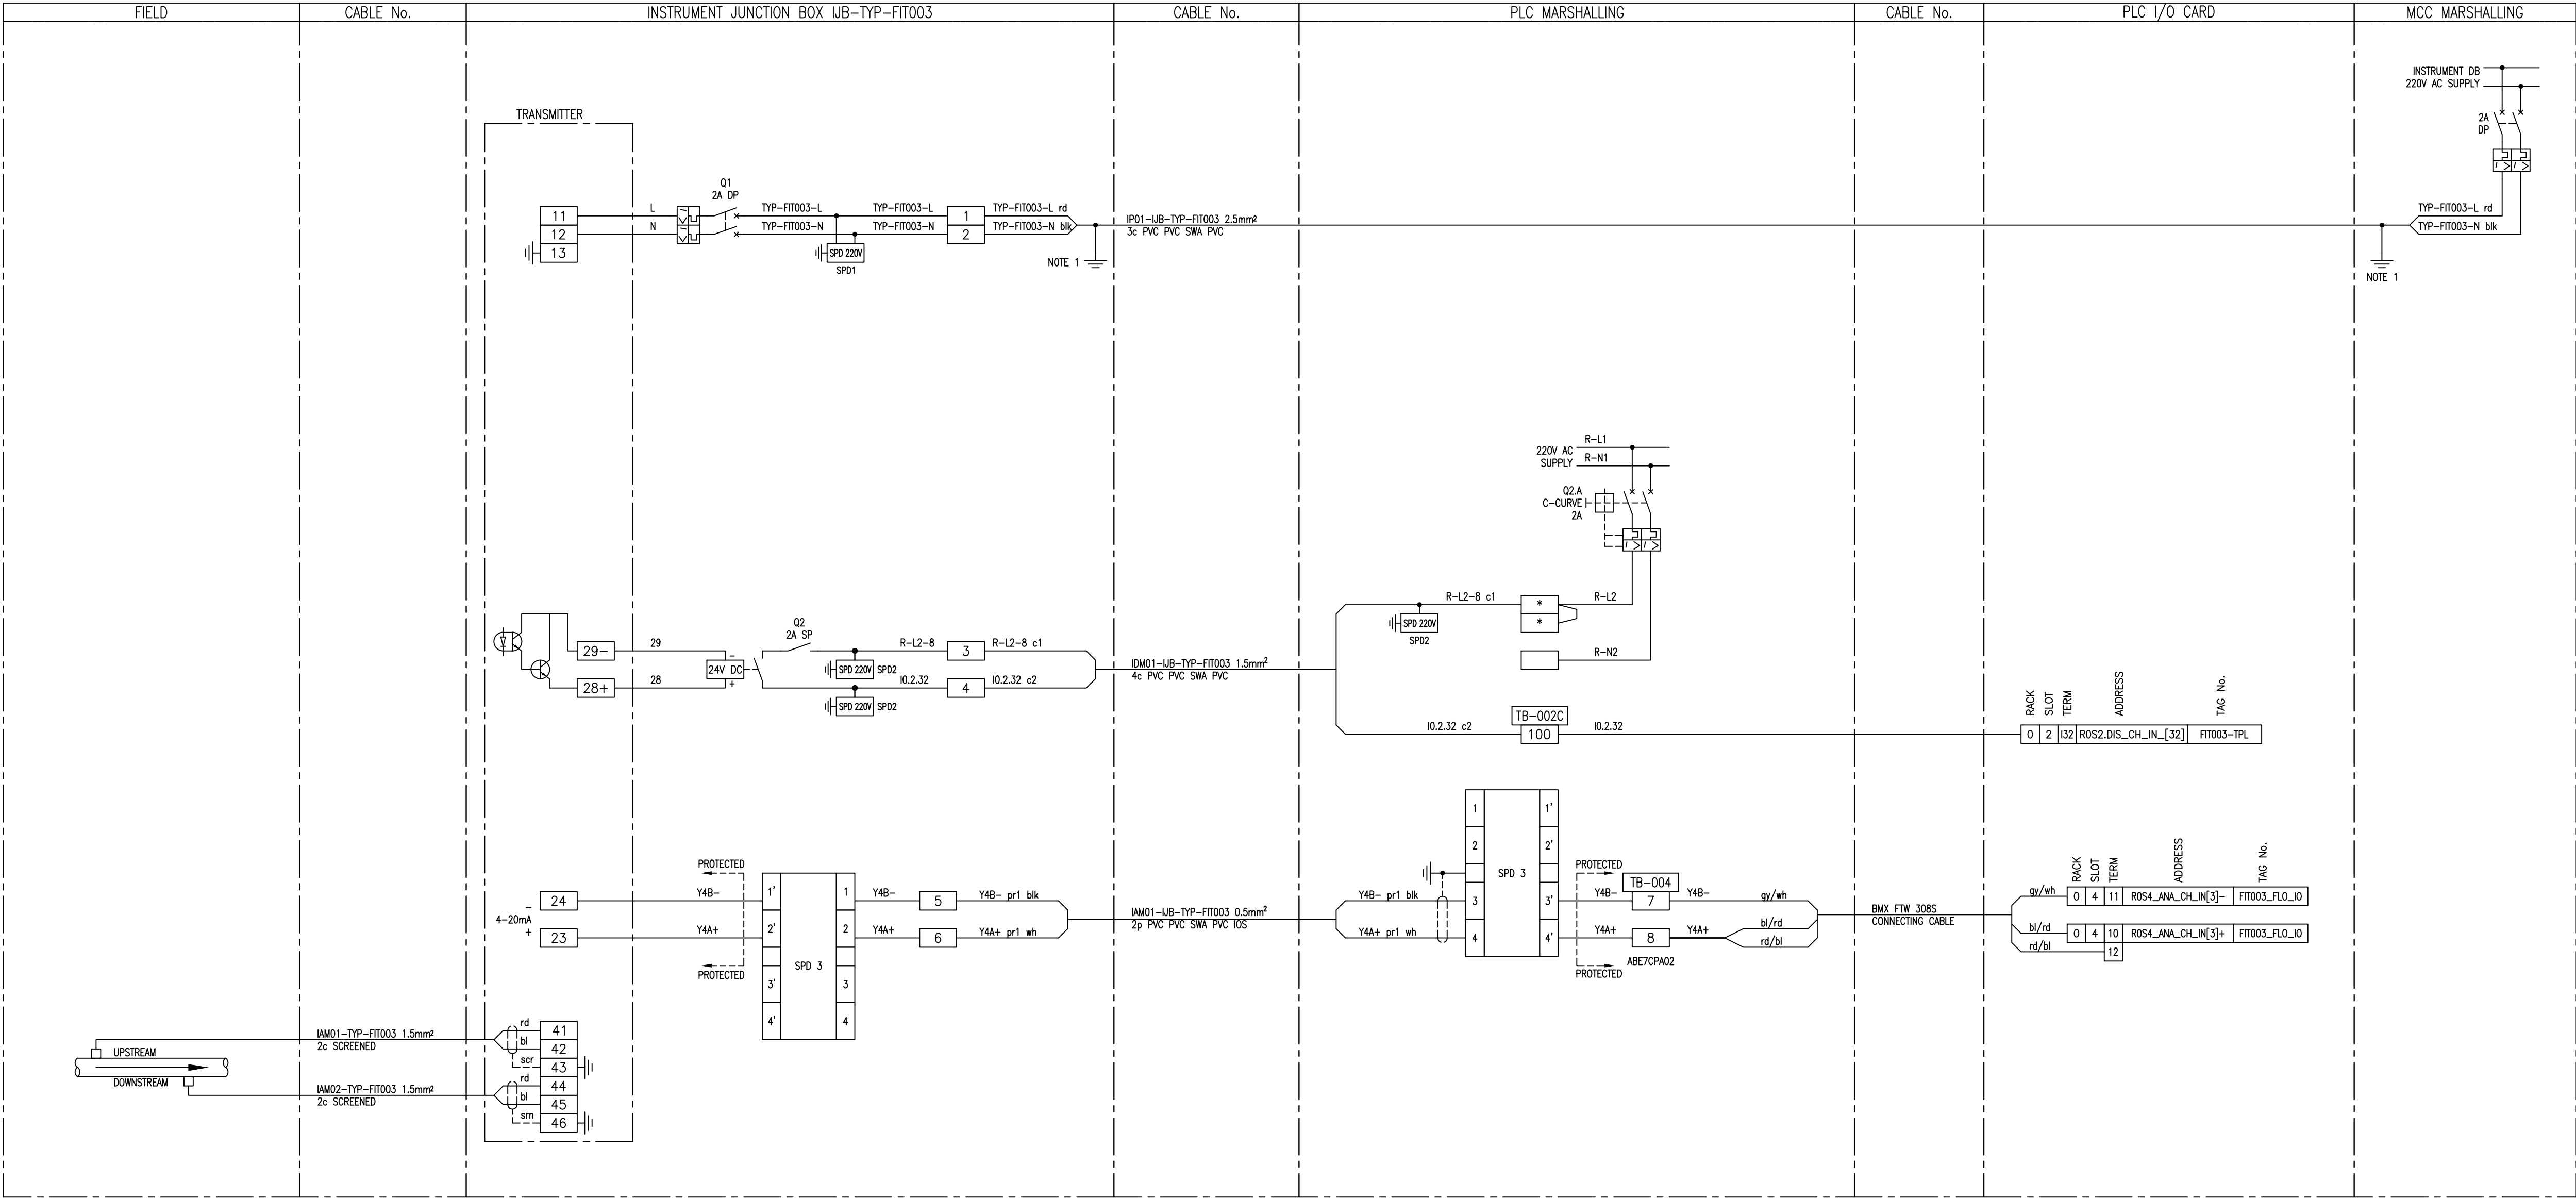


- NOTES:
1. EARTH CORE MUST BE YELLOW/GREEN OR IT MUST BE FITTED WITH A YELLOW/GREEN SLEEVE.
- SUB-BASE 1: ABE-7S16ZM0: 230V AC DIGITAL INPUT
SUB-BASE 2: ABE-7CPA02: 8ch ANALOG INPUT
SUB-BASE 3: ABE-7R16S210: RELAY OUTPUT
SUB-BASE 4: ABE-7CPA21: 4ch ANALOG OUTPUT
- SPD 1: DEHNgard DG M TN 275
SPD 2: DEHNgard DG S 275 VA
SPD 3: BLITZDUCTOR BXT ML4 BD 24 + BASE BXT BAS
SPD 4: BLITZDUCTOR BXT ML2 BD S 24 + BASE BXT BAS
SPD 5: BLITZDUCTOR BXT ML4 BE 24 + BASE BXT BAS
SPD 6: BLITZDUCTOR BXT ML2 BE S 24 + BASE BXT BAS

* FUSED TERMINAL (500mA)
□ LINK TERMINAL

DEPARTMENT	APPROVED	DESIGNATION	DATE

   
CONSULTING ENGINEERS		JOHANNESBURG WATER SOC LTD		CITY OF JOHANNESBURG		DESIGN MANAGER	SCALE	AMENDMENTS		APPROVED	DATE	DRAWING No.													
 P.O. BOX 221 RIVONIA 2128 TEL. 011-806 7111 FAX. 011-806 7100 EMAIL enquiries@kprsa.co.za  WSP Group Africa (Pty) Ltd Industrial Division Building C, Knightsbridge, 33 Sloane Street, Bryanston, 2191 Tel: +27 11 361 1300 Fax: +27 11 361 1431 www.wsp.com		SURVEYED		 17 HARRISON STREET MARSHALLTOWN 2107 TEL: (011) 688-1400 FAX: (011) 688-1529	BUSHKOPPIE WASTEWATER TREATMENT WORKS INFRASTRUCTURE RENEWAL PLAN CLAMP-ON FLOW METER – FIT003 TYPICAL LOOP DIAGRAM				NTS			T0	ISSUED FOR TENDER	W BRITZ	08.08.19	JW NUMBER									
		T1	RE-ISSUED FOR TENDER			CdT	07.01.25			CONSULTANT'S NUMBER															
												TYP – FIT003													
												FILE No													
DATE												T0	T1												

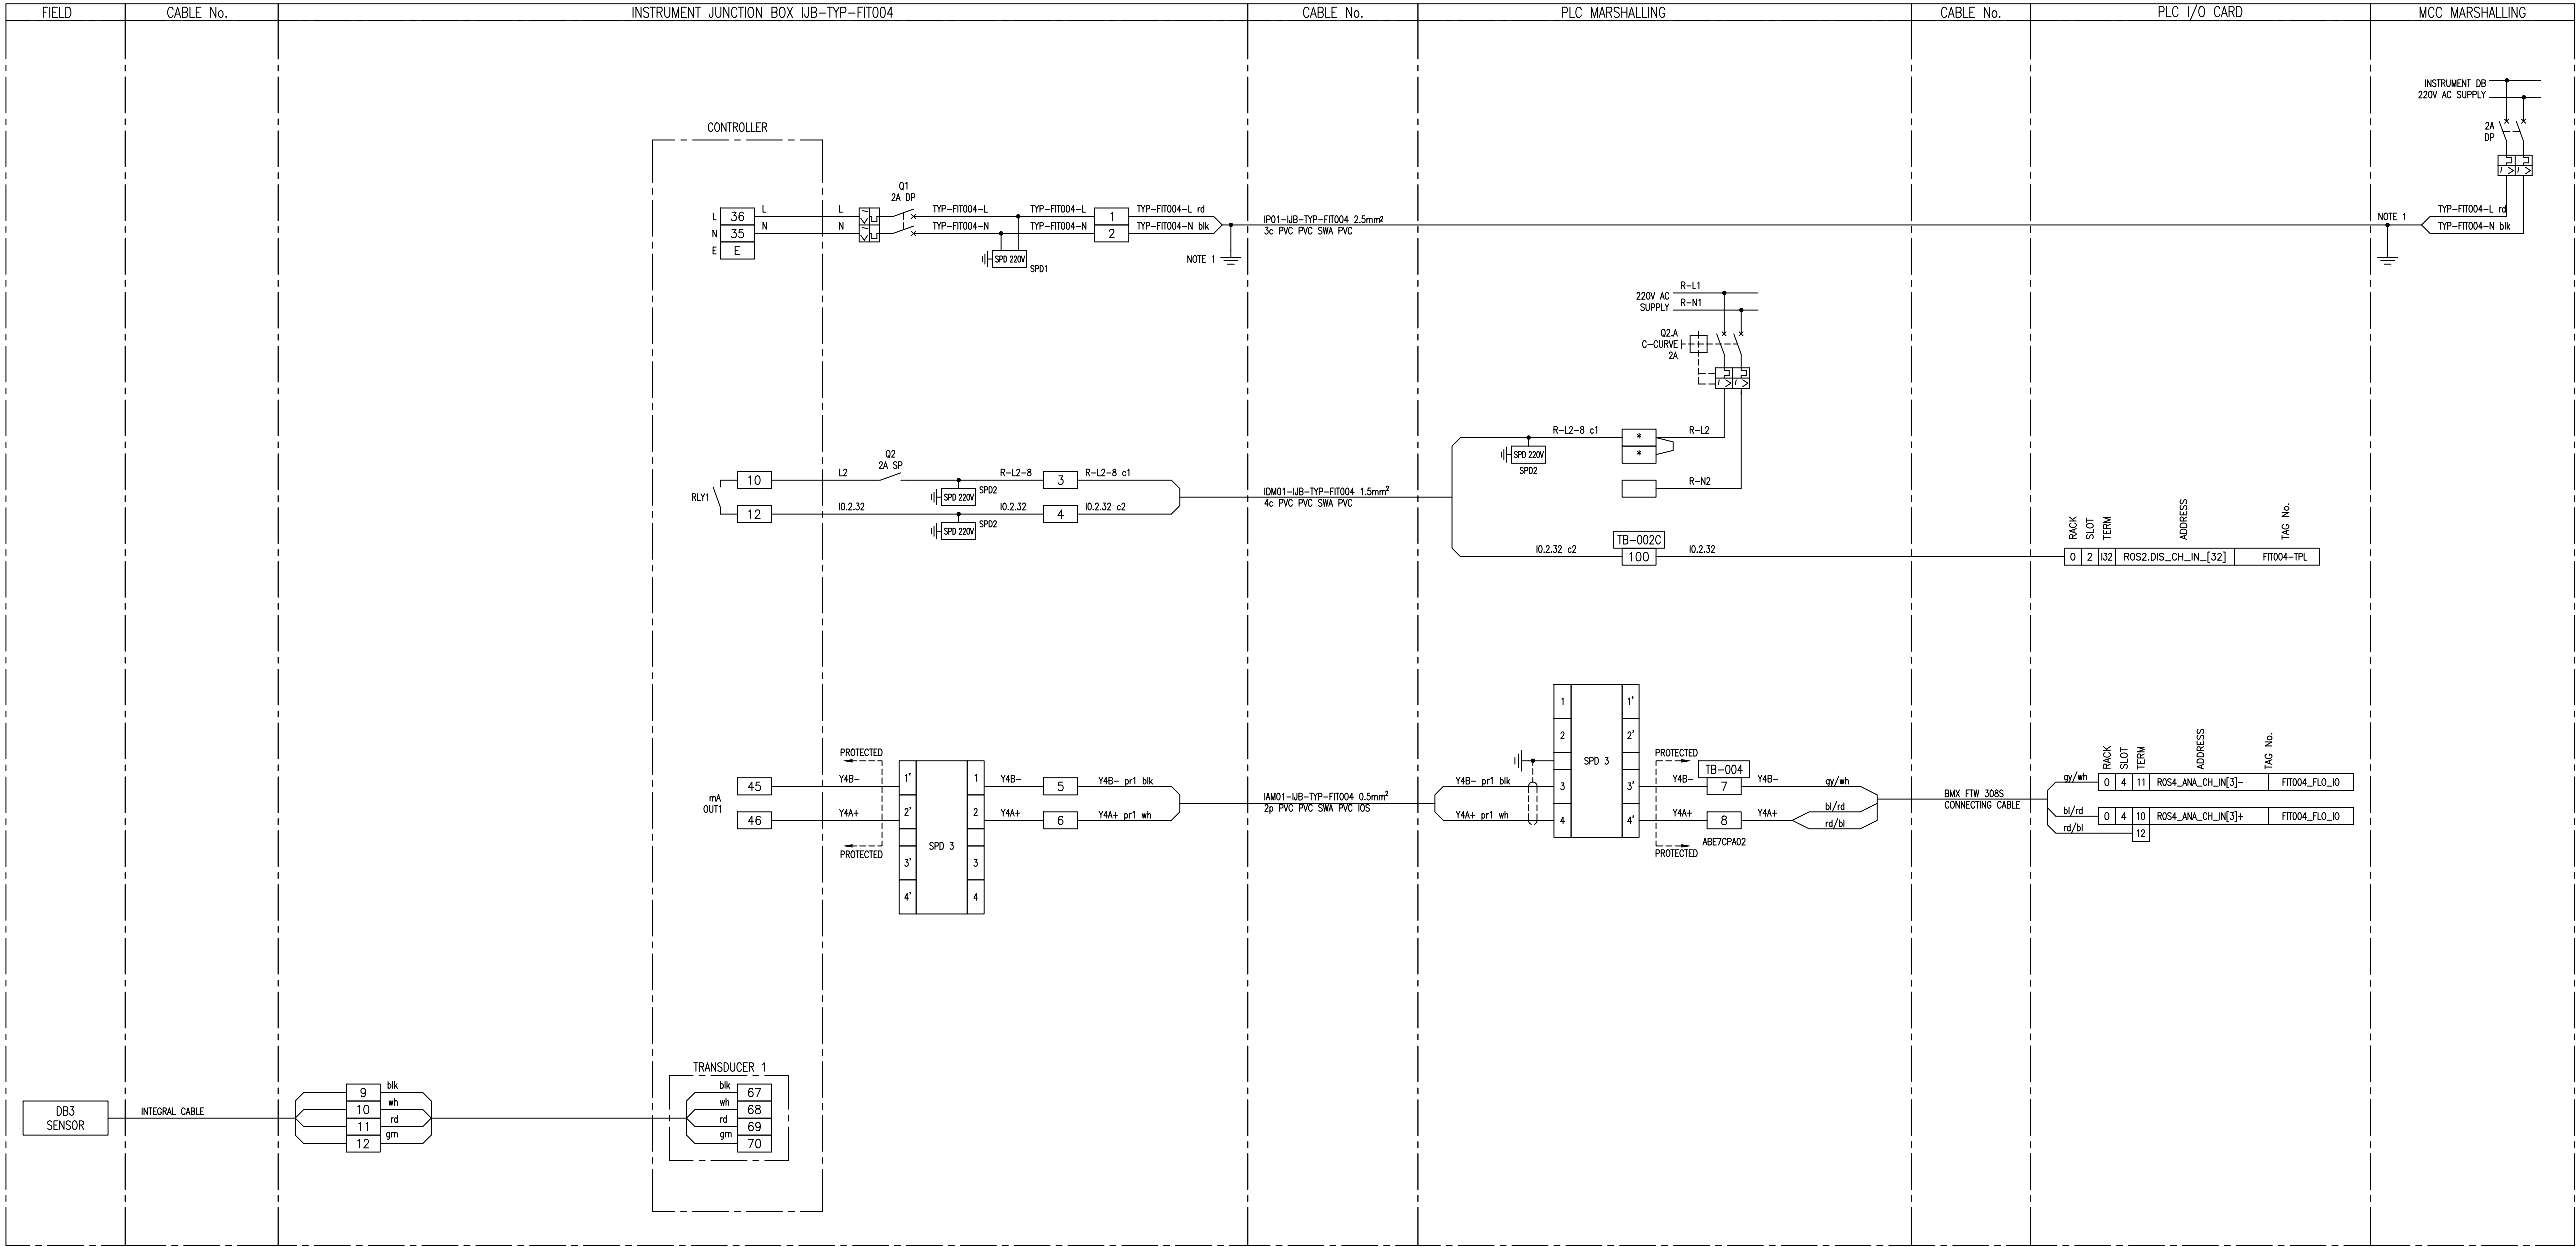


- NOTES:
1. EARTH CORE MUST BE YELLOW/GREEN OR IT MUST BE FITTED WITH A YELLOW/GREEN SLEEVE.
- SUB-BASE 1: ABE-7S16ZM0: 230V AC DIGITAL INPUT
SUB-BASE 2: ABE-7CPA02: 8ch ANALOG INPUT
SUB-BASE 3: ABE-7R16S210: RELAY OUTPUT
SUB-BASE 4: ABE-7CPA21: 4ch ANALOG OUTPUT
- SPD 1: DEHNgard DG M TN 275
SPD 2: DEHNgard DG S 275 VA
SPD 3: BLITZDUCTOR BXT ML4 BD 24 + BASE BXT BAS
SPD 4: BLITZDUCTOR BXT ML2 BD S 24 + BASE BXT BAS
SPD 5: BLITZDUCTOR BXT ML4 BE 24 + BASE BXT BAS
SPD 6: BLITZDUCTOR BXT ML2 BE S 24 + BASE BXT BAS
- * FUSED TERMINAL (500mA)
□ LINK TERMINAL

DEPARTMENT	APPROVED	DESIGNATION	DATE

CONSULTING ENGINEERS				JOHANNESBURG WATER SOC LTD		CITY OF JOHANNESBURG		DESIGN MANAGER	SCALE	AMENDMENTS		APPROVED	DATE	DRAWING No.											
 P.O. BOX 221 RIVONIA 2128 TEL. 011-806 7111 FAX. 011-806 7100 EMAIL enquiries@kprsa.co.za	 WSP Group Africa (Pty) Ltd Industrial Division Building C, Knightsbridge, 33 Sloane Street, Bryanston, 2191 Tel: +27 11 361 1300 Fax: +27 11 361 1431 www.wsp.com	SURVEYED		 Johannesburg Water	17 HARRISON STREET MARSHALLTOWN 2107 TEL: (011) 688-1400 FAX: (011) 688-1529	BUSHKOPPIE WASTEWATER TREATMENT WORKS INFRASTRUCTURE RENEWAL PLAN FLUME FLOW METER – FIT004 TYPICAL LOOP DIAGRAM				NTS	T0			ISSUED FOR TENDER	W BRITZ	08.08.19	JW NUMBER								
		DESIGNED	W BRITZ								DATE	T1	RE-ISSUED FOR TENDER	CdT	07.01.25	CONSULTANT'S NUMBER									
		DRAWN	M DYKE										TYP – FIT004												
		CHECKED	W BRITZ										FILE No												
		SERVICES CHECKED																							
		GEOTECHNICAL INVESTIGATION																							
		SERVITUDES																							
		APPROVED																							
		Pr. Eng. No.																							
		DATE																							



















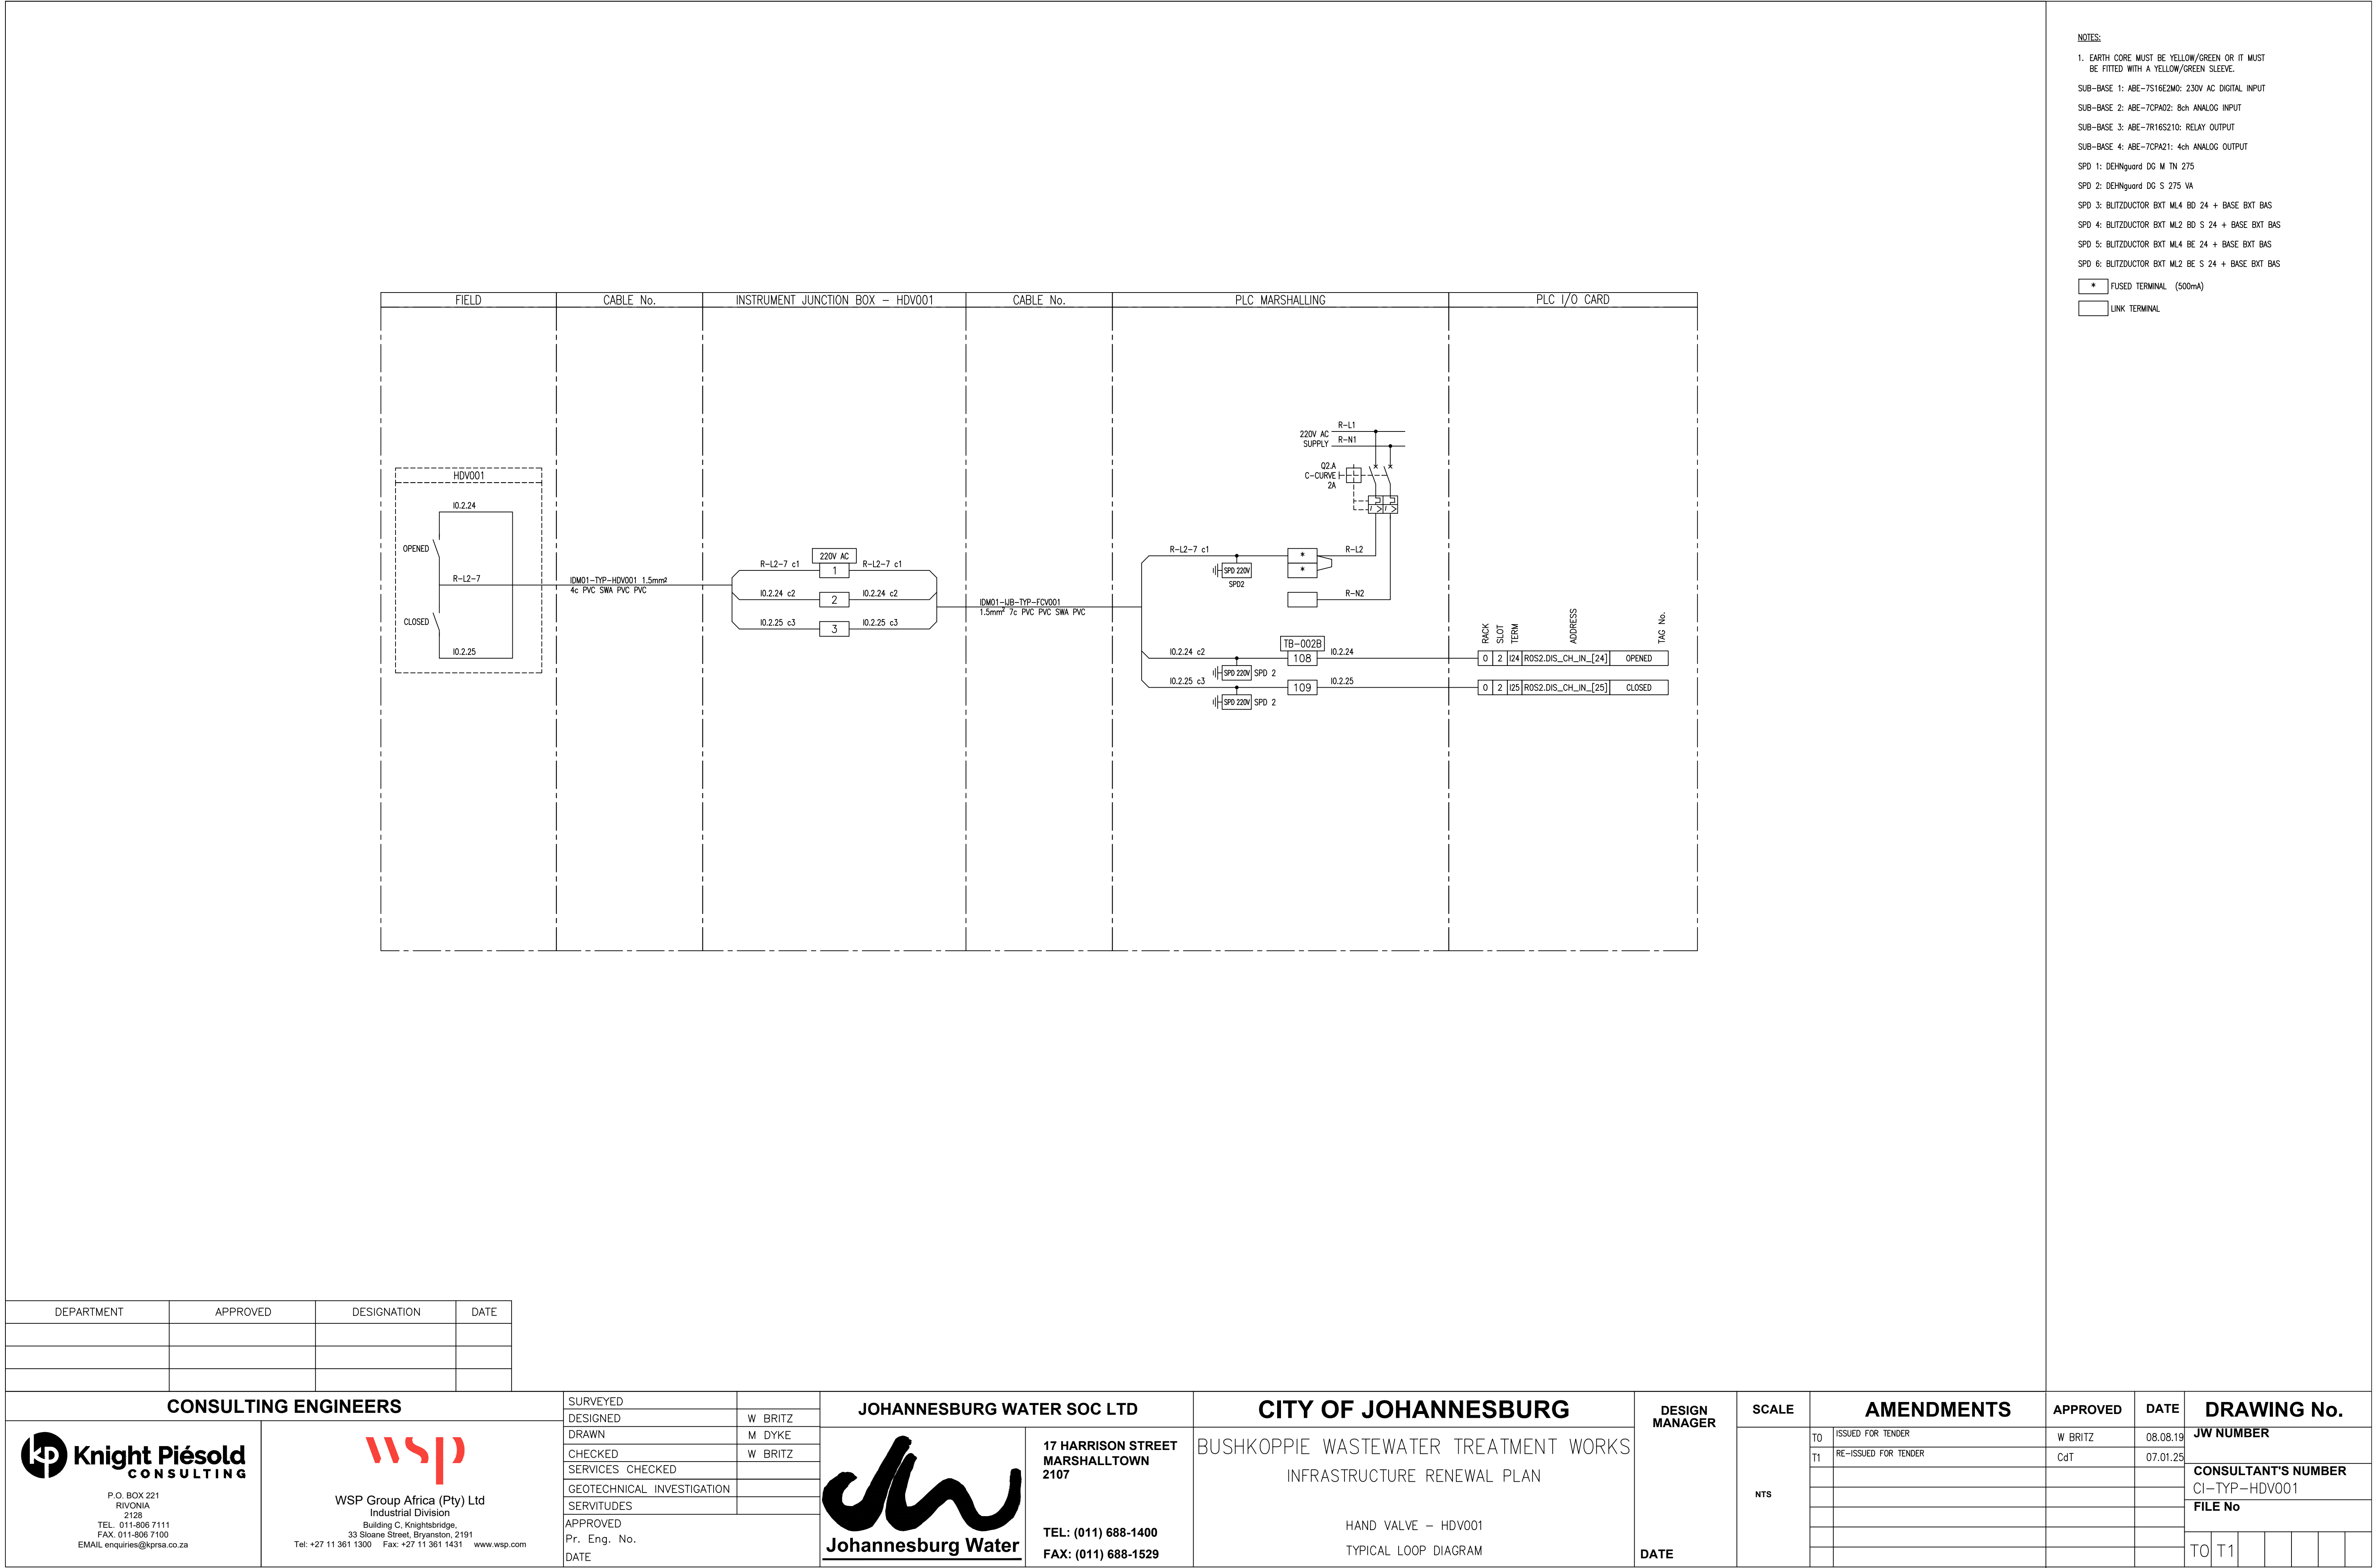


- NOTES:
1. EARTH CORE MUST BE YELLOW/GREEN OR IT MUST BE FITTED WITH A YELLOW/GREEN SLEEVE.
- SUB-BASE 1: ABE-7S16ZM0: 230V AC DIGITAL INPUT
- SUB-BASE 2: ABE-7CPA02: 8ch ANALOG INPUT
- SUB-BASE 3: ABE-7R16S210: RELAY OUTPUT
- SUB-BASE 4: ABE-7CPA21: 4ch ANALOG OUTPUT
- SPD 1: DEHNgard DG M TN 275
- SPD 2: DEHNgard DG S 275 VA
- SPD 3: BLITZDUCTOR BXT ML4 BD 24 + BASE BXT BAS
- SPD 4: BLITZDUCTOR BXT ML2 BD S 24 + BASE BXT BAS
- SPD 5: BLITZDUCTOR BXT ML4 BE 24 + BASE BXT BAS
- SPD 6: BLITZDUCTOR BXT ML2 BE S 24 + BASE BXT BAS
- * FUSED TERMINAL (500mA)
- LINK TERMINAL

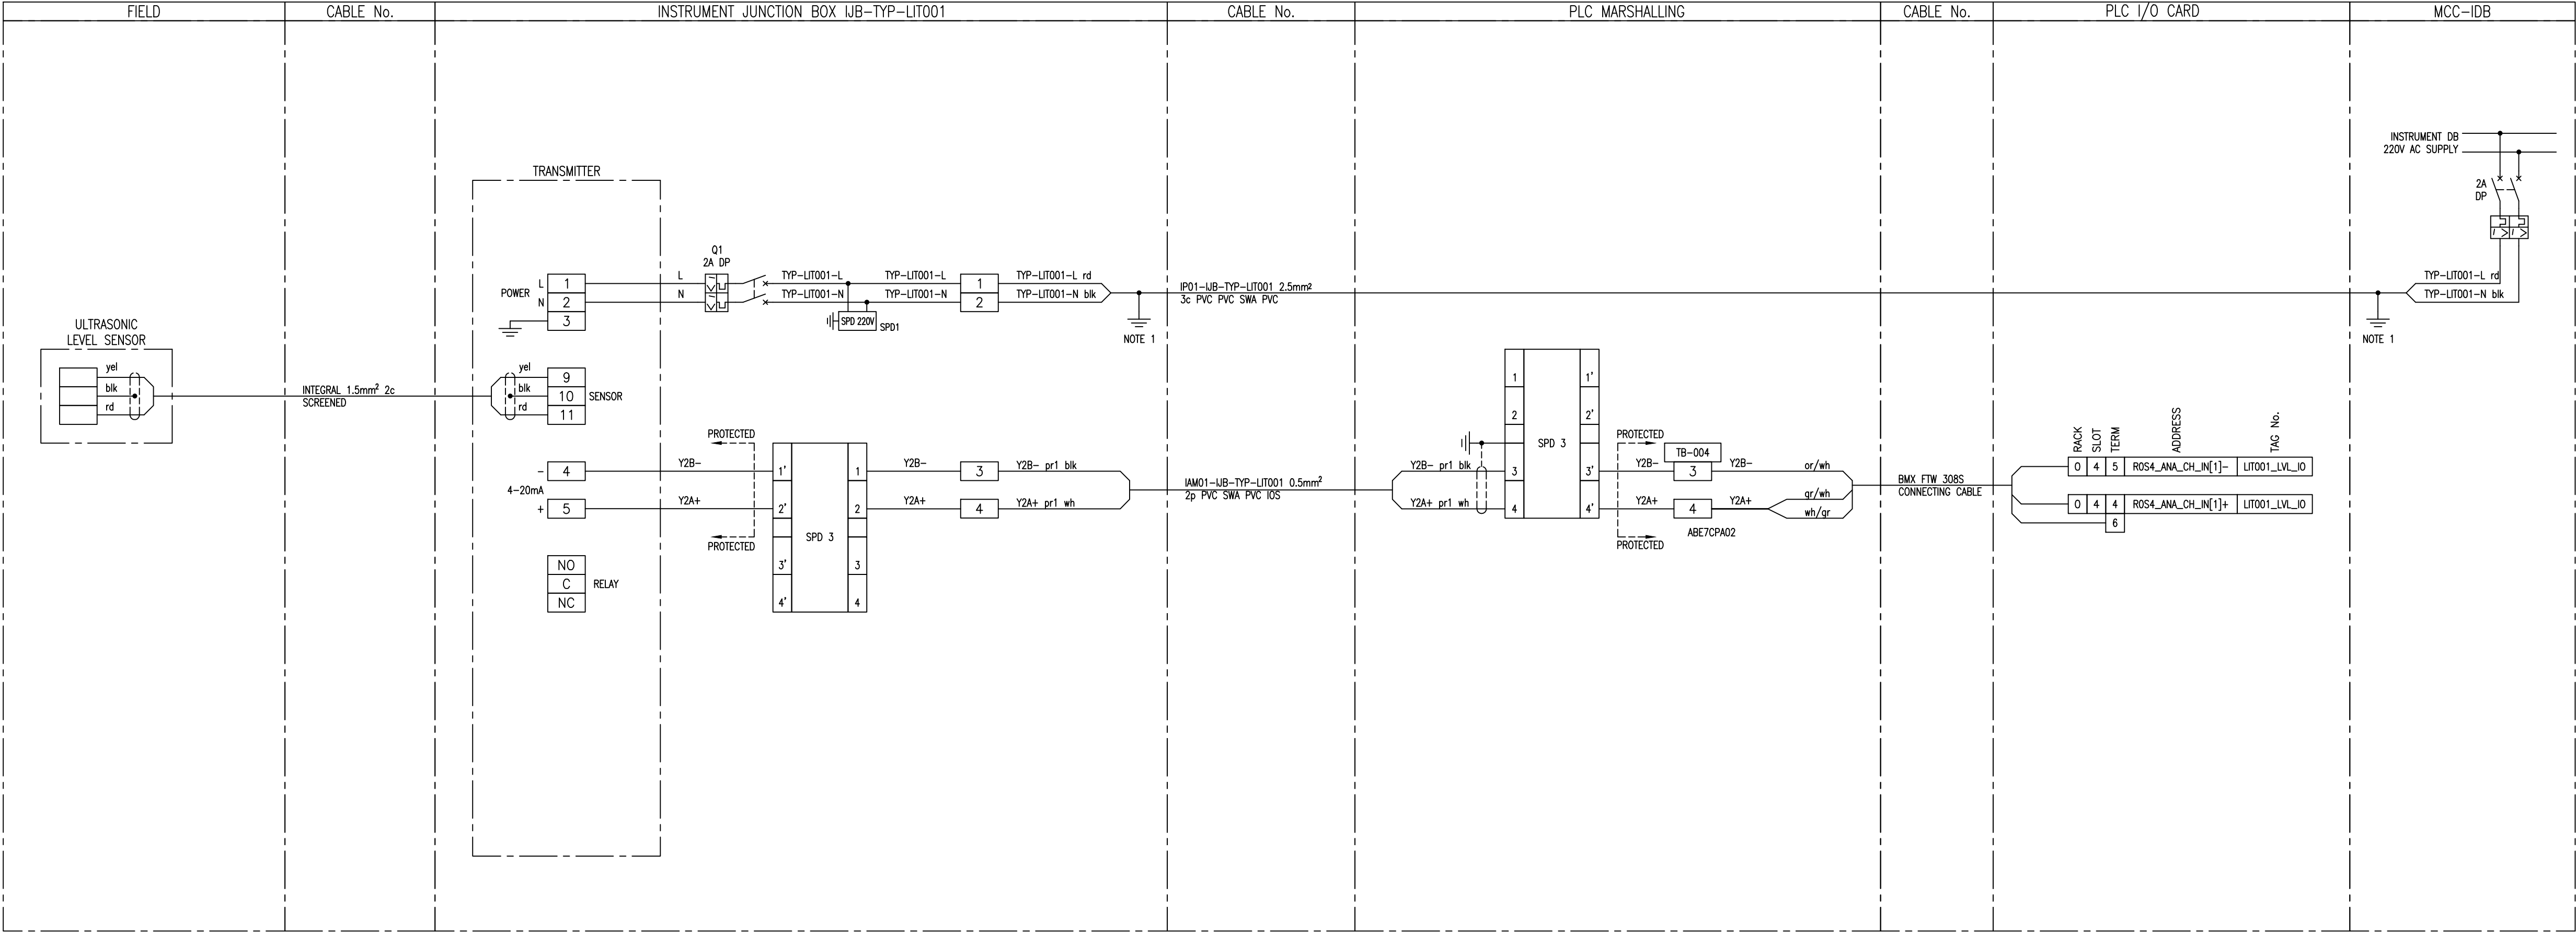


DEPARTMENT	APPROVED	DESIGNATION	DATE


CONSULTING ENGINEERS		SURVEYED		JOHANNESBURG WATER SOC LTD		CITY OF JOHANNESBURG		DESIGN MANAGER	SCALE	AMENDMENTS		APPROVED	DATE	DRAWING No.	
 P.O. BOX 221 RIVONIA 2128 TEL. 011-806 7111 FAX. 011-806 7100 EMAIL enquiries@kprsa.co.za	 WSP Group Africa (Pty) Ltd Industrial Division Building C, Knightsbridge, 33 Sloane Street, Bryanston, 2191 Tel: +27 11 361 1300 Fax: +27 11 361 1431 www.wsp.com	DESIGNED	W BRITZ	 17 HARRISON STREET MARSHALLTOWN 2107 TEL: (011) 688-1400 FAX: (011) 688-1529	BUSHKOPPIE WASTEWATER TREATMENT WORKS INFRASTRUCTURE RENEWAL PLAN ULTRA SONIC LEVEL TRANSMITTER – LIT001 TYPICAL LOOP DIAGRAM	DATE	NTS			T0	ISSUED FOR TENDER			W BRITZ	08.08.19
		T1	RE-ISSUED FOR TENDER					CdT	07.01.25	CONSULTANT'S NUMBER CI-TYP-LIT001					
										FILE No					
										TO T1					

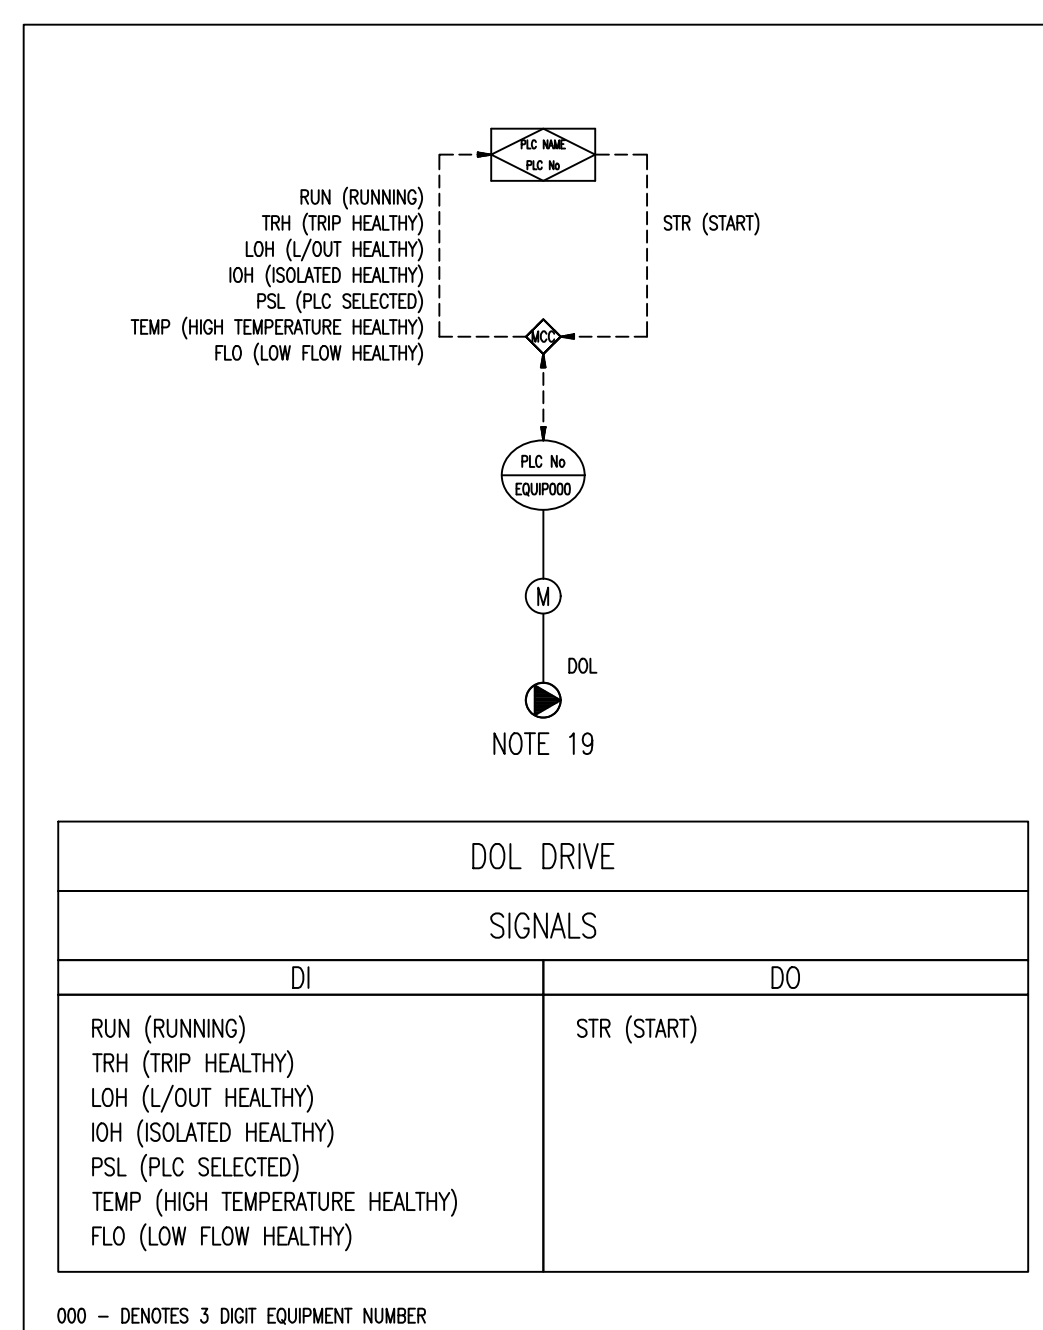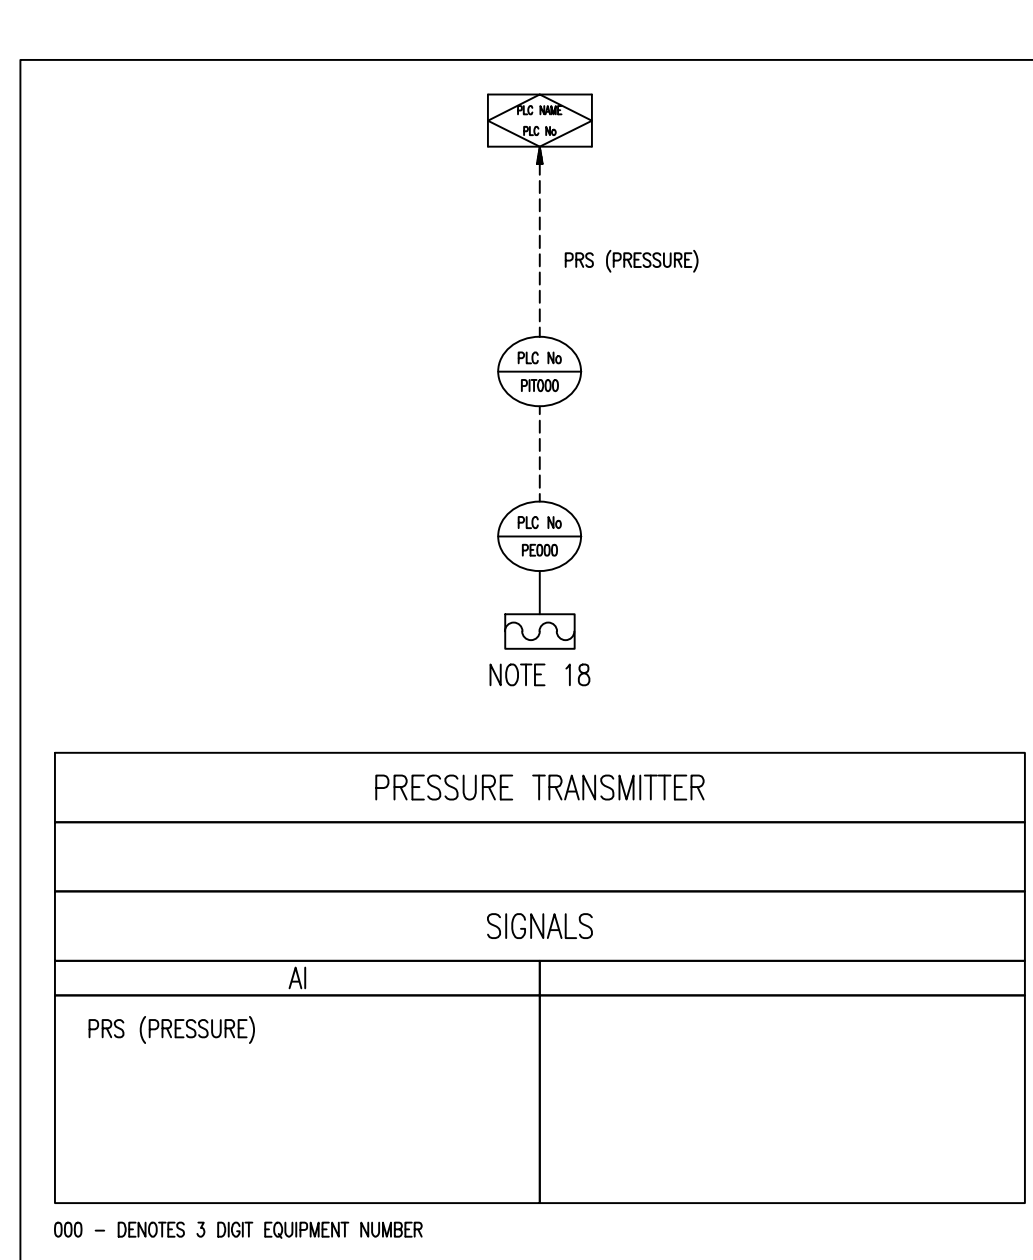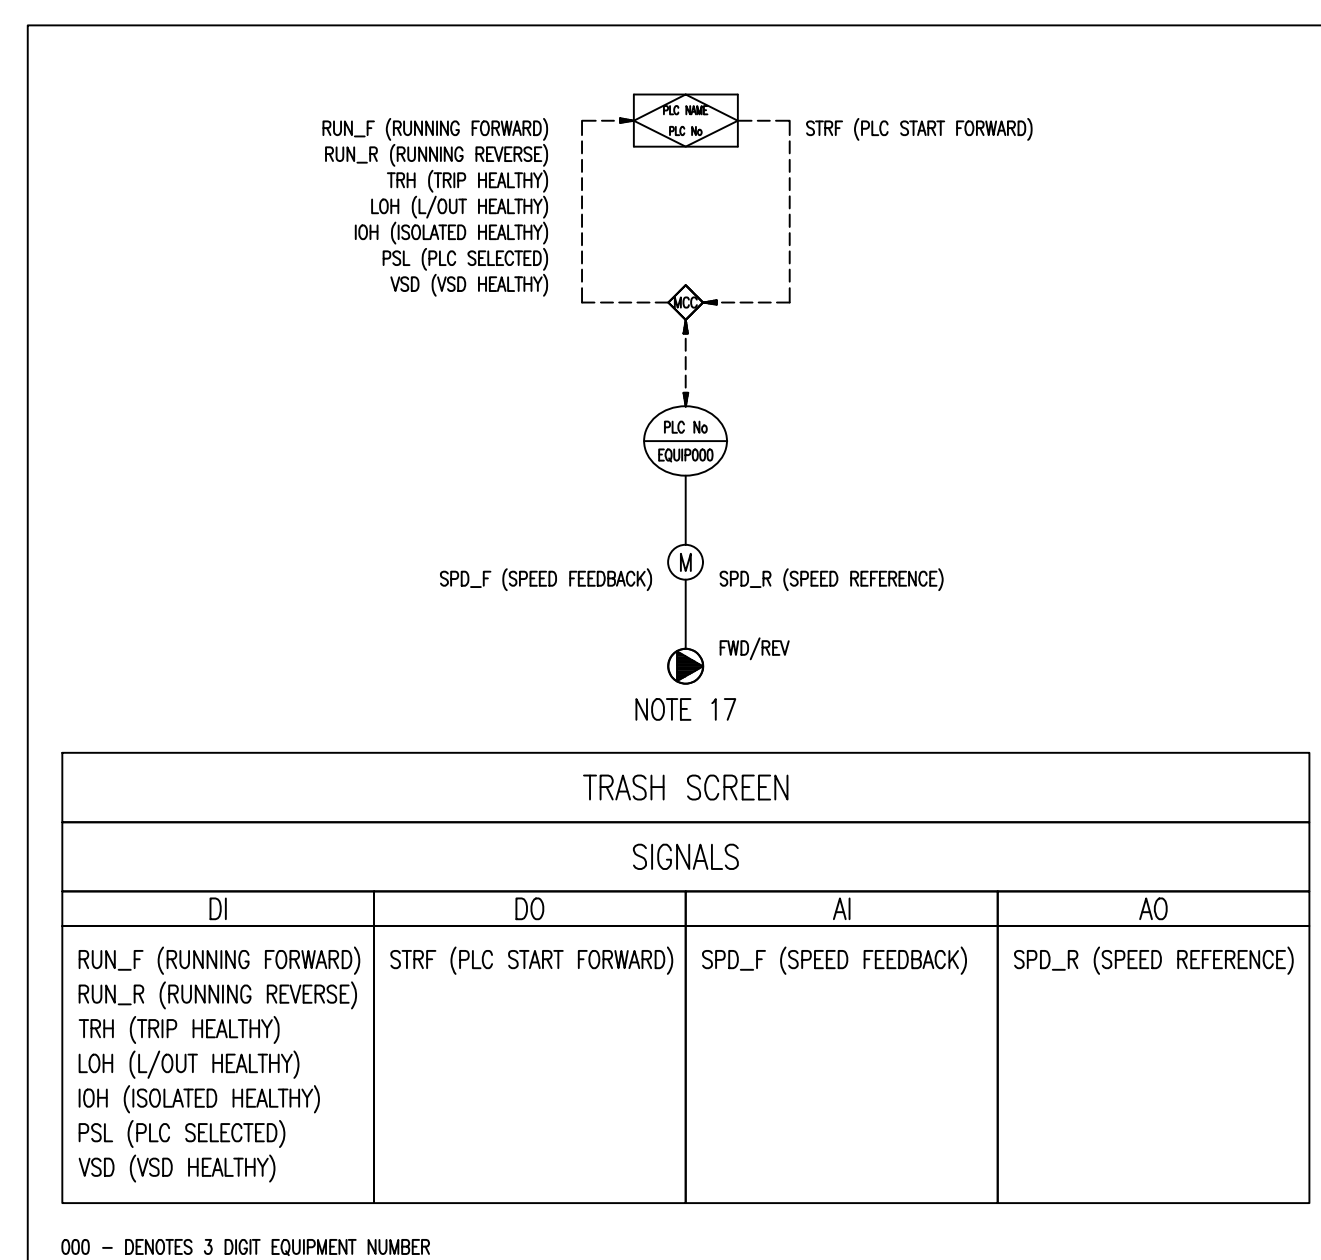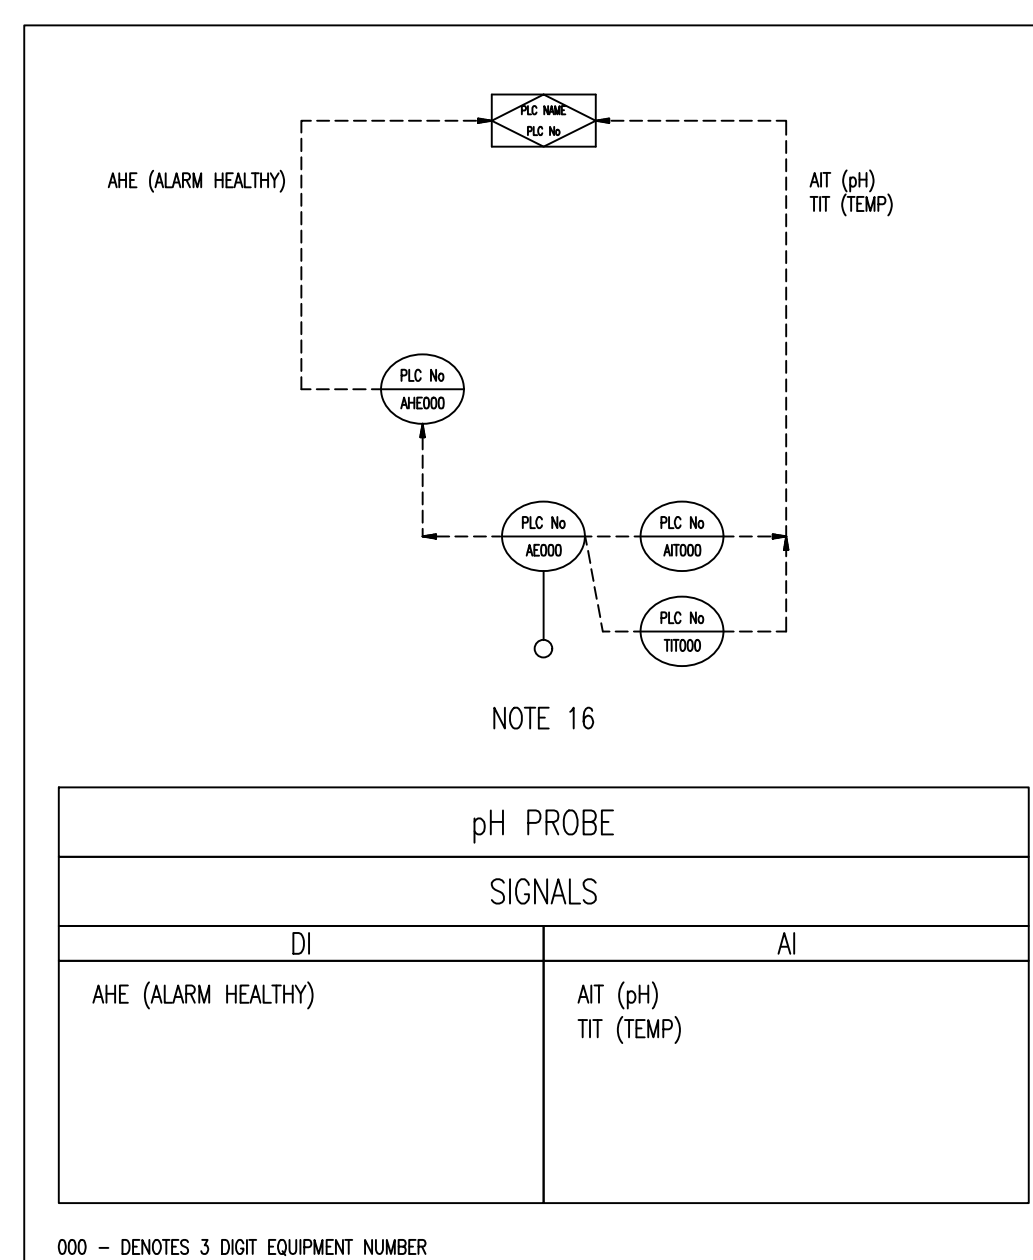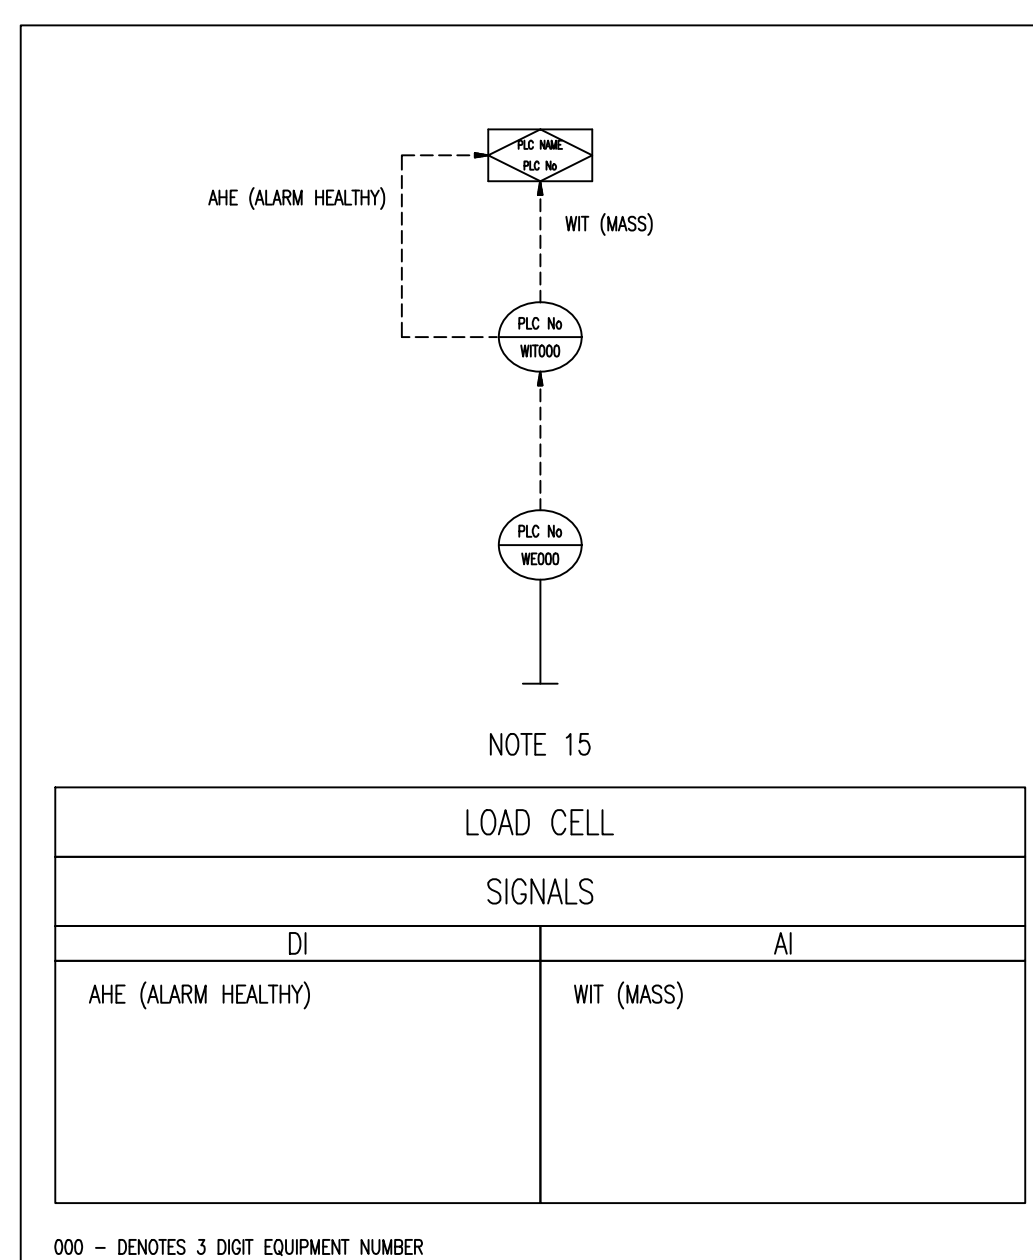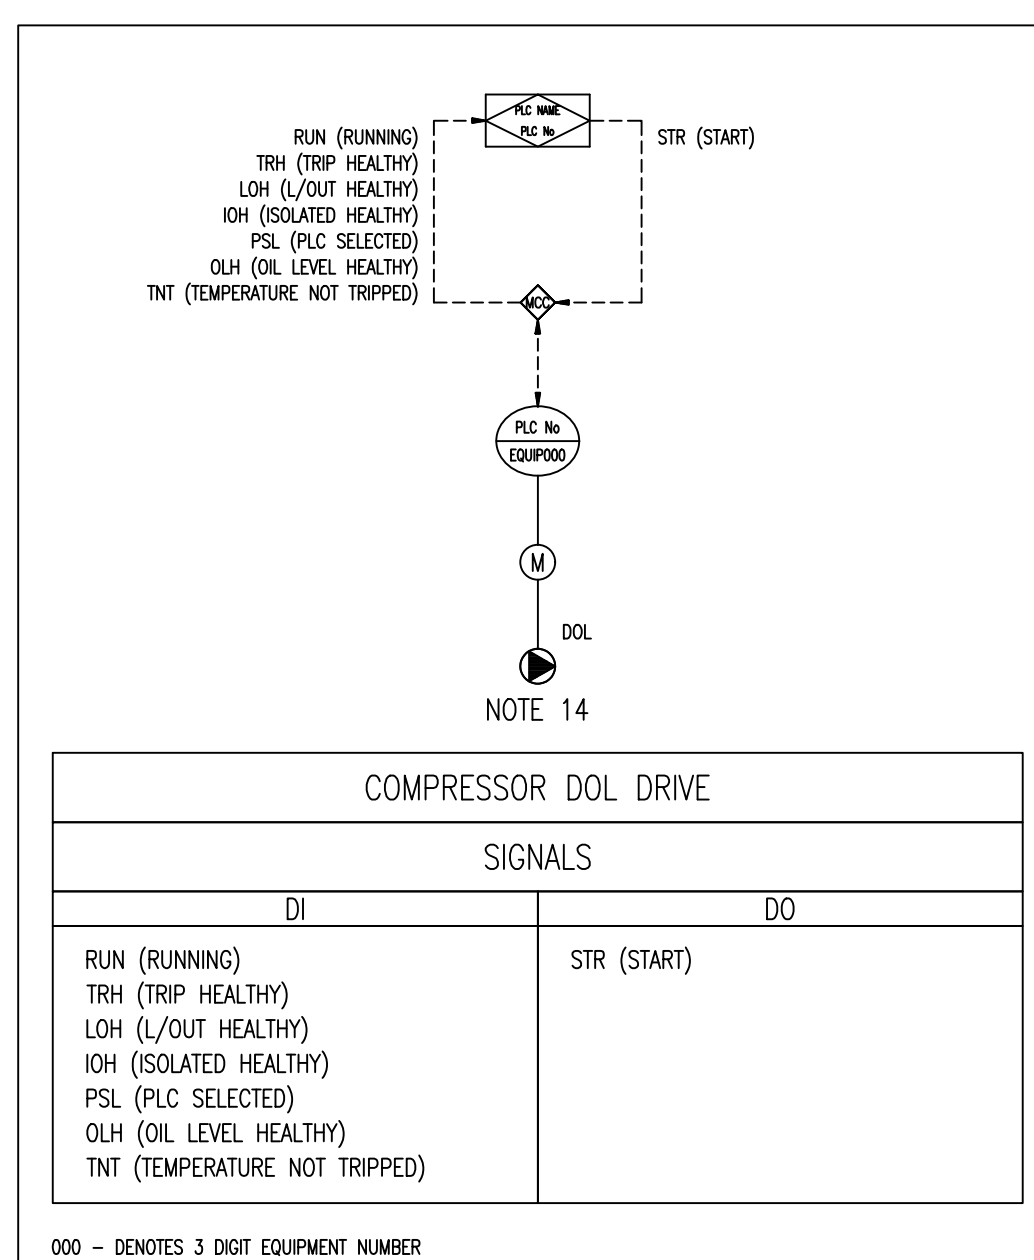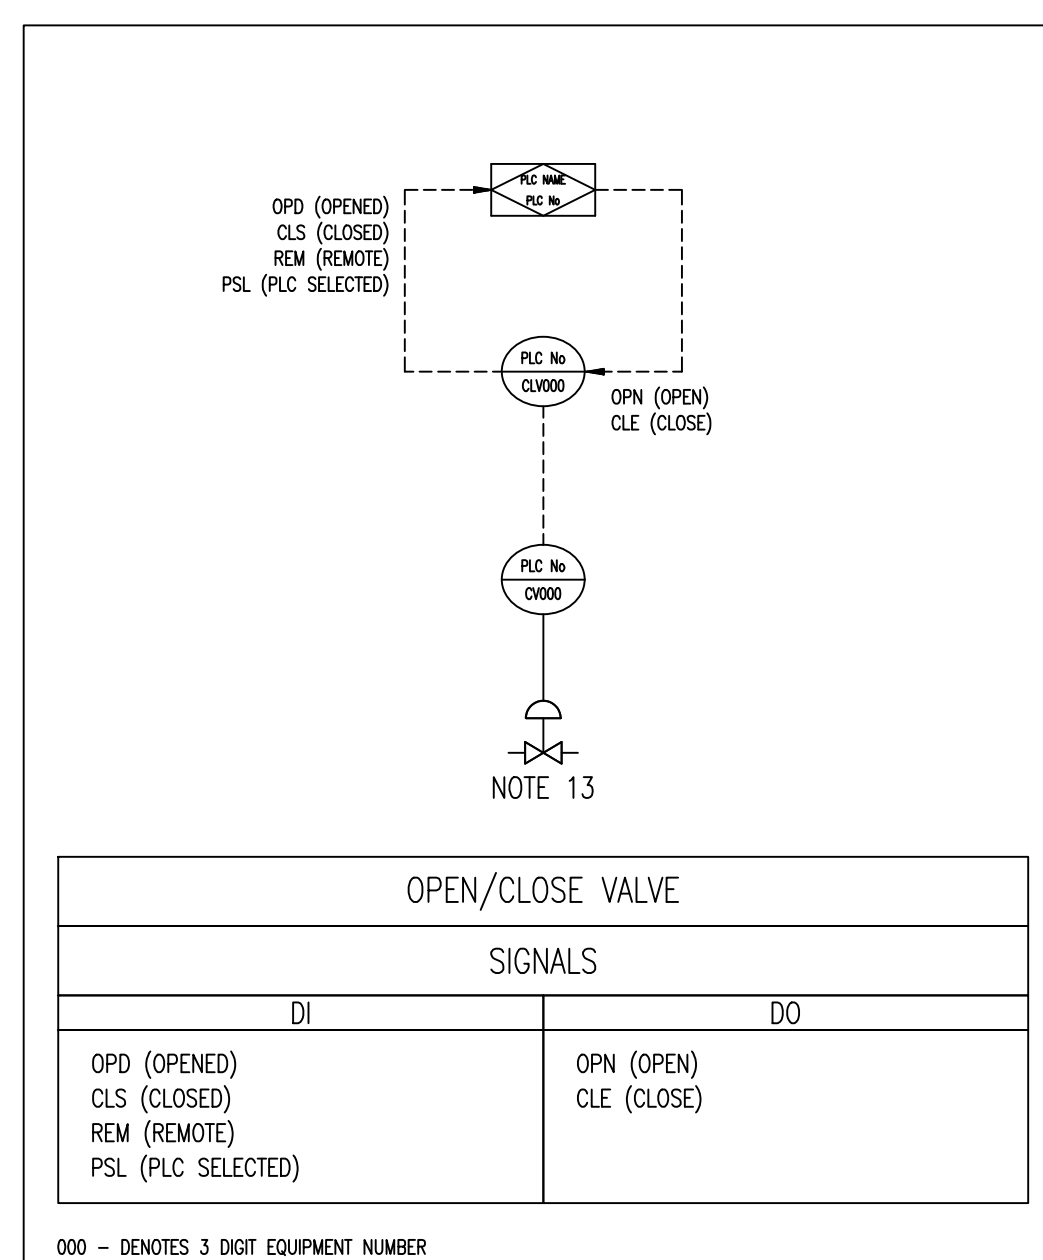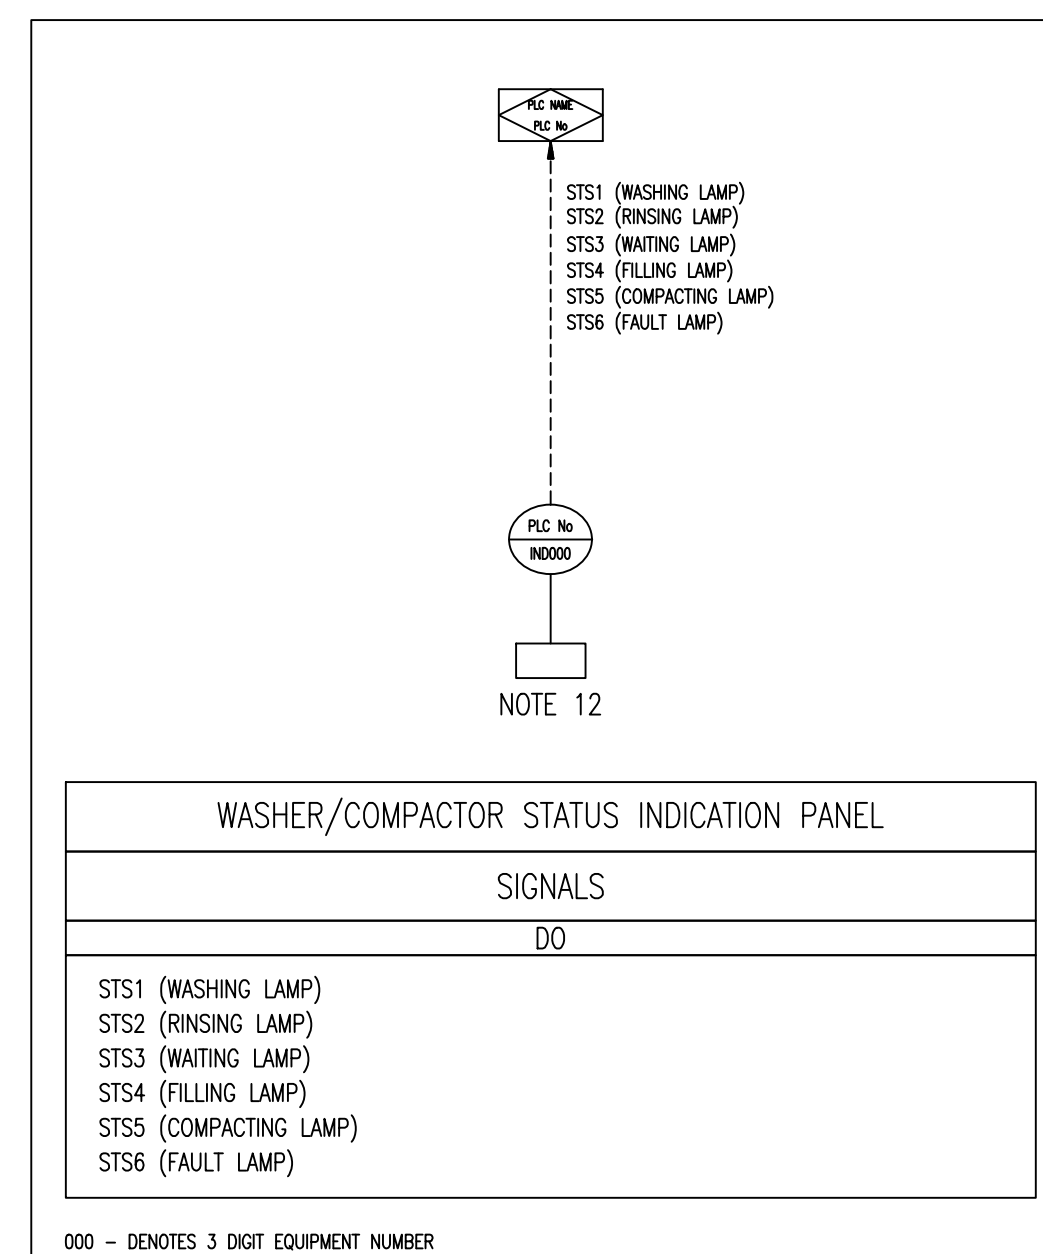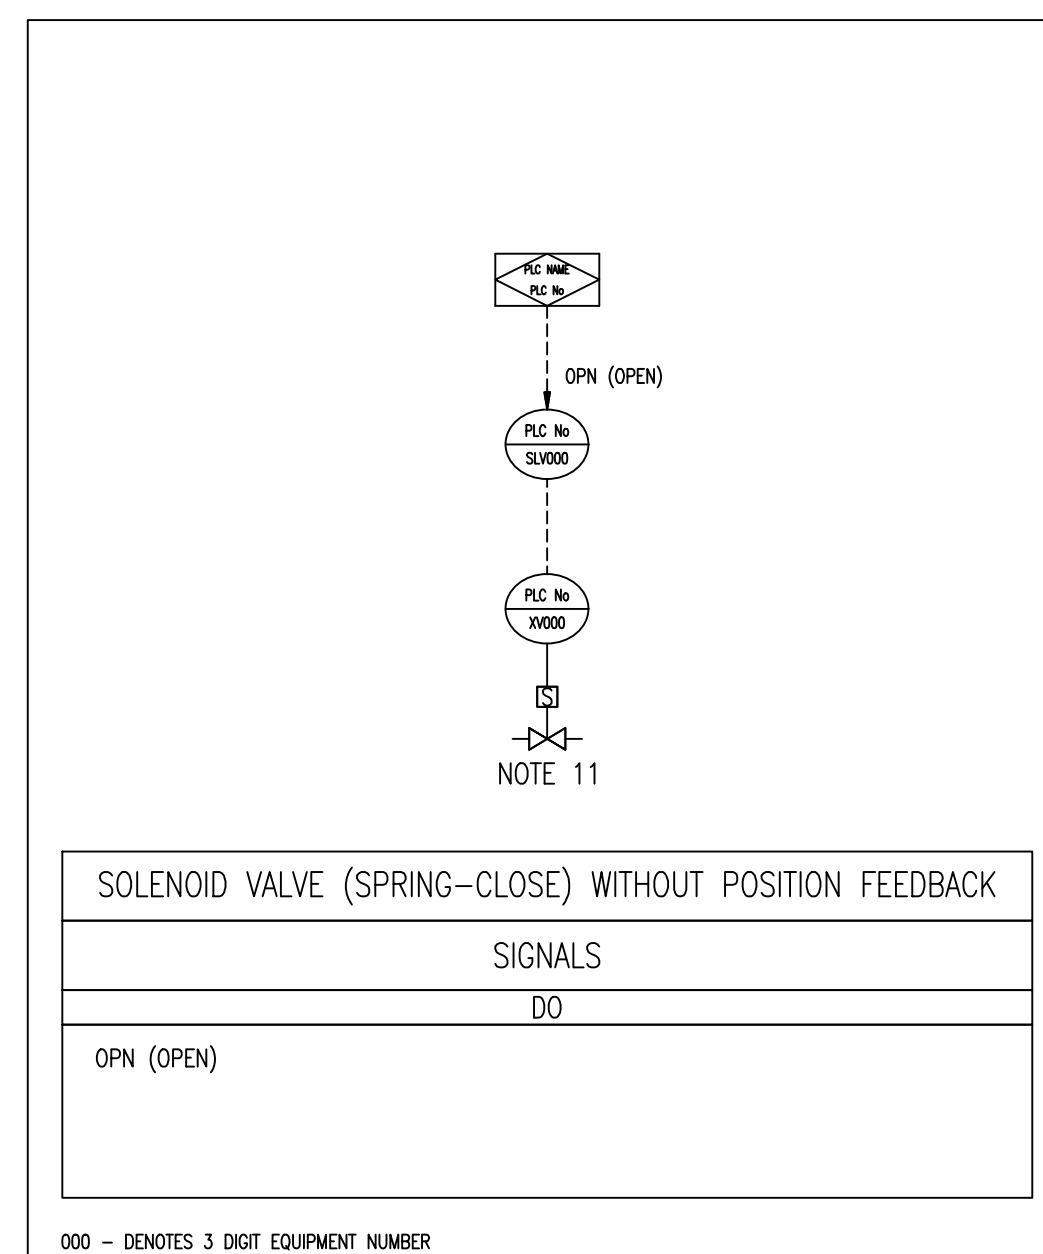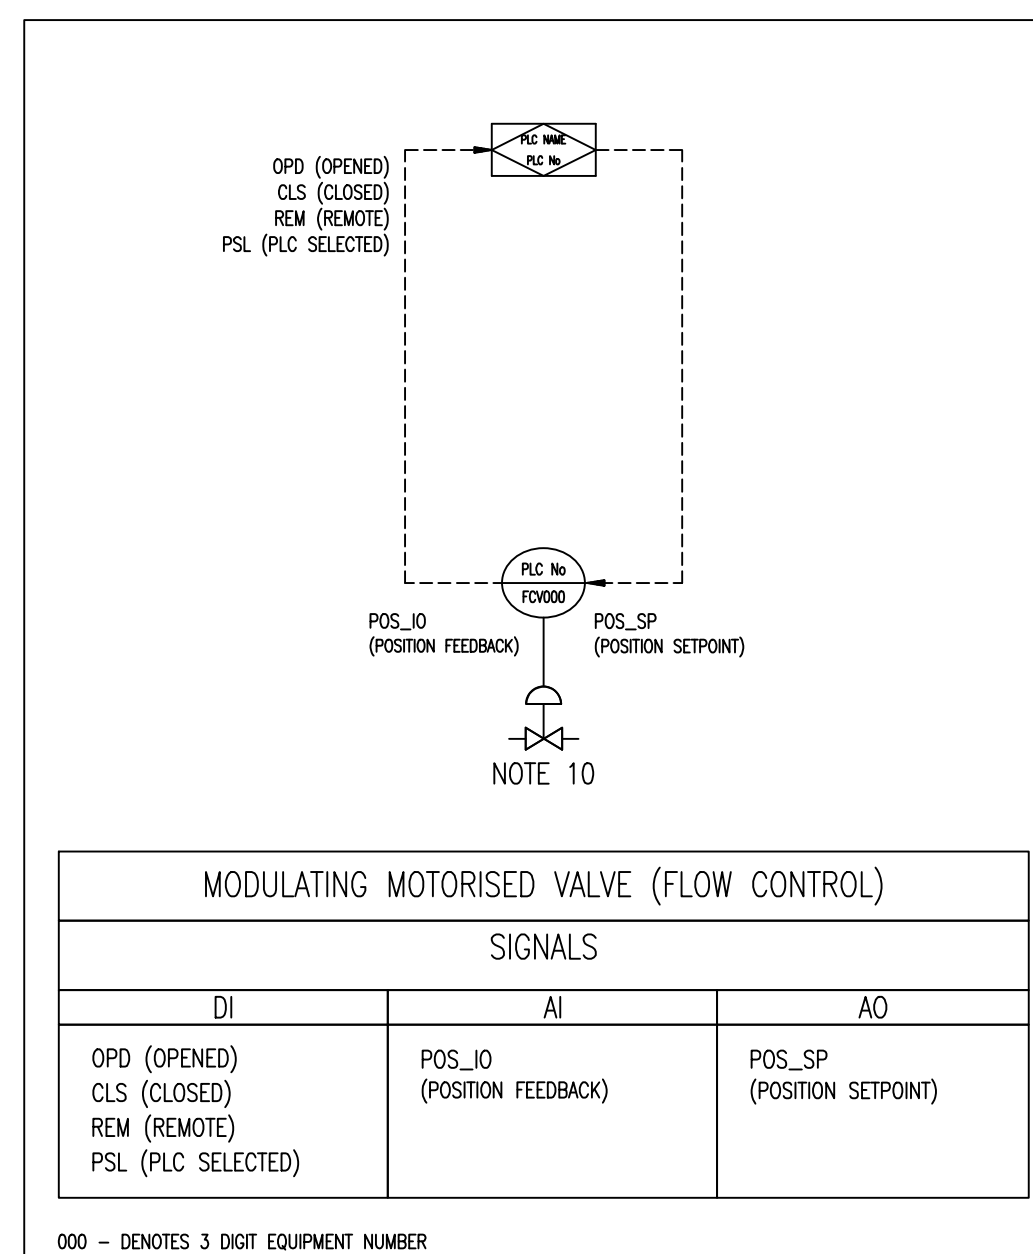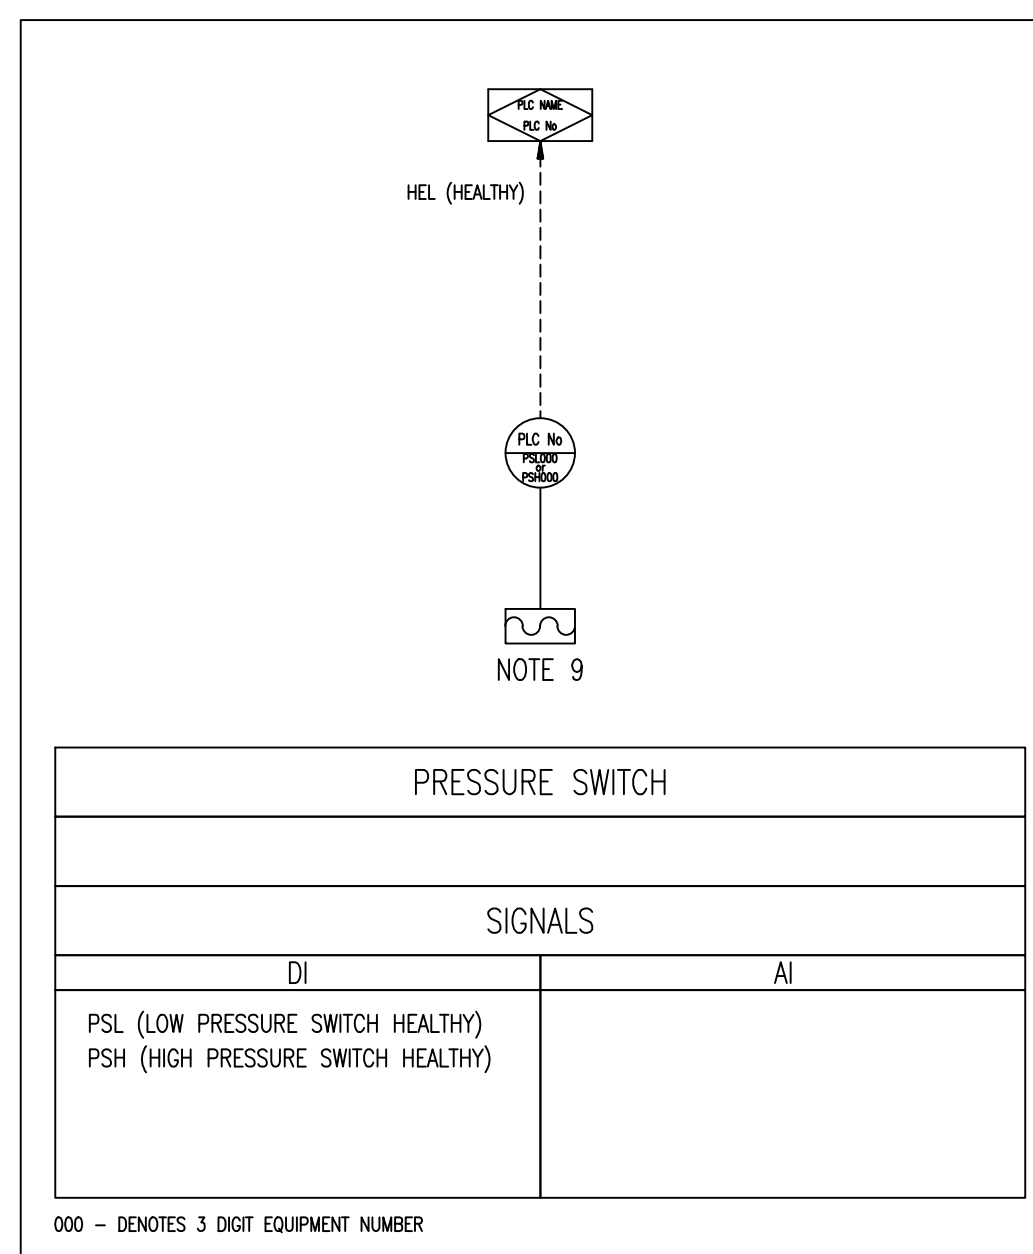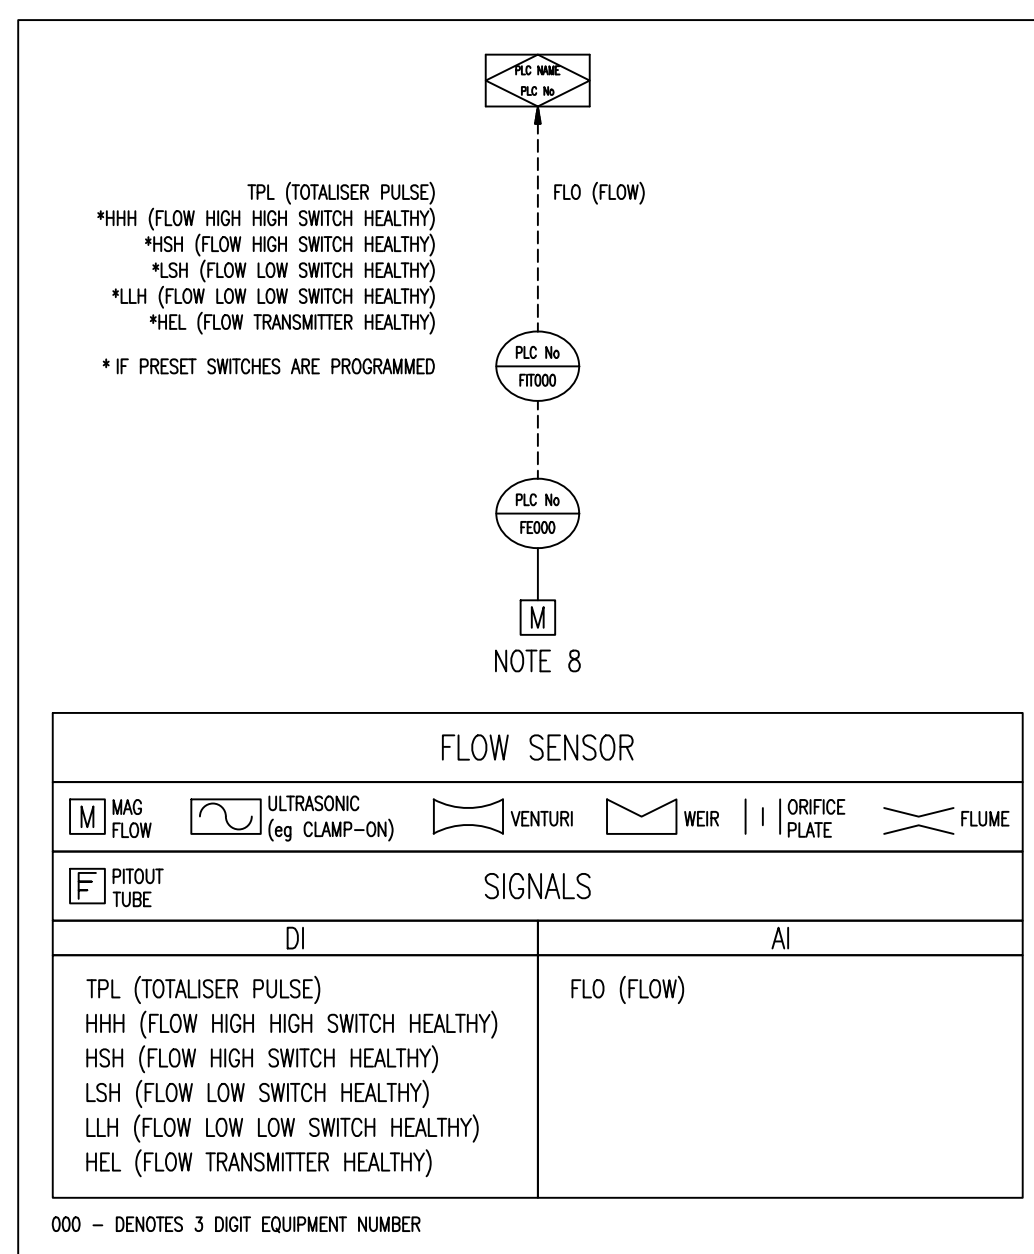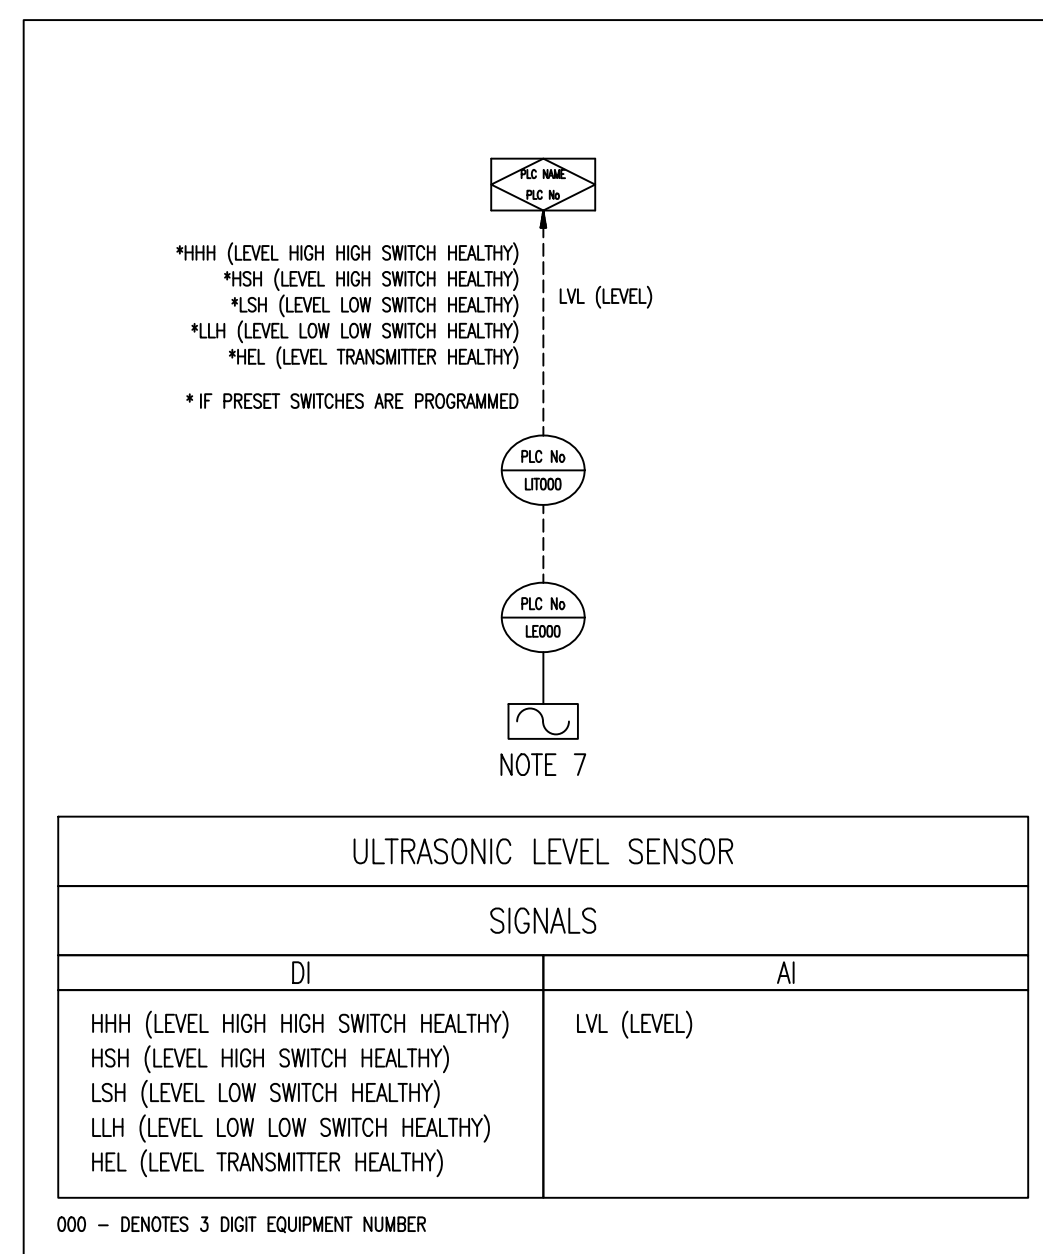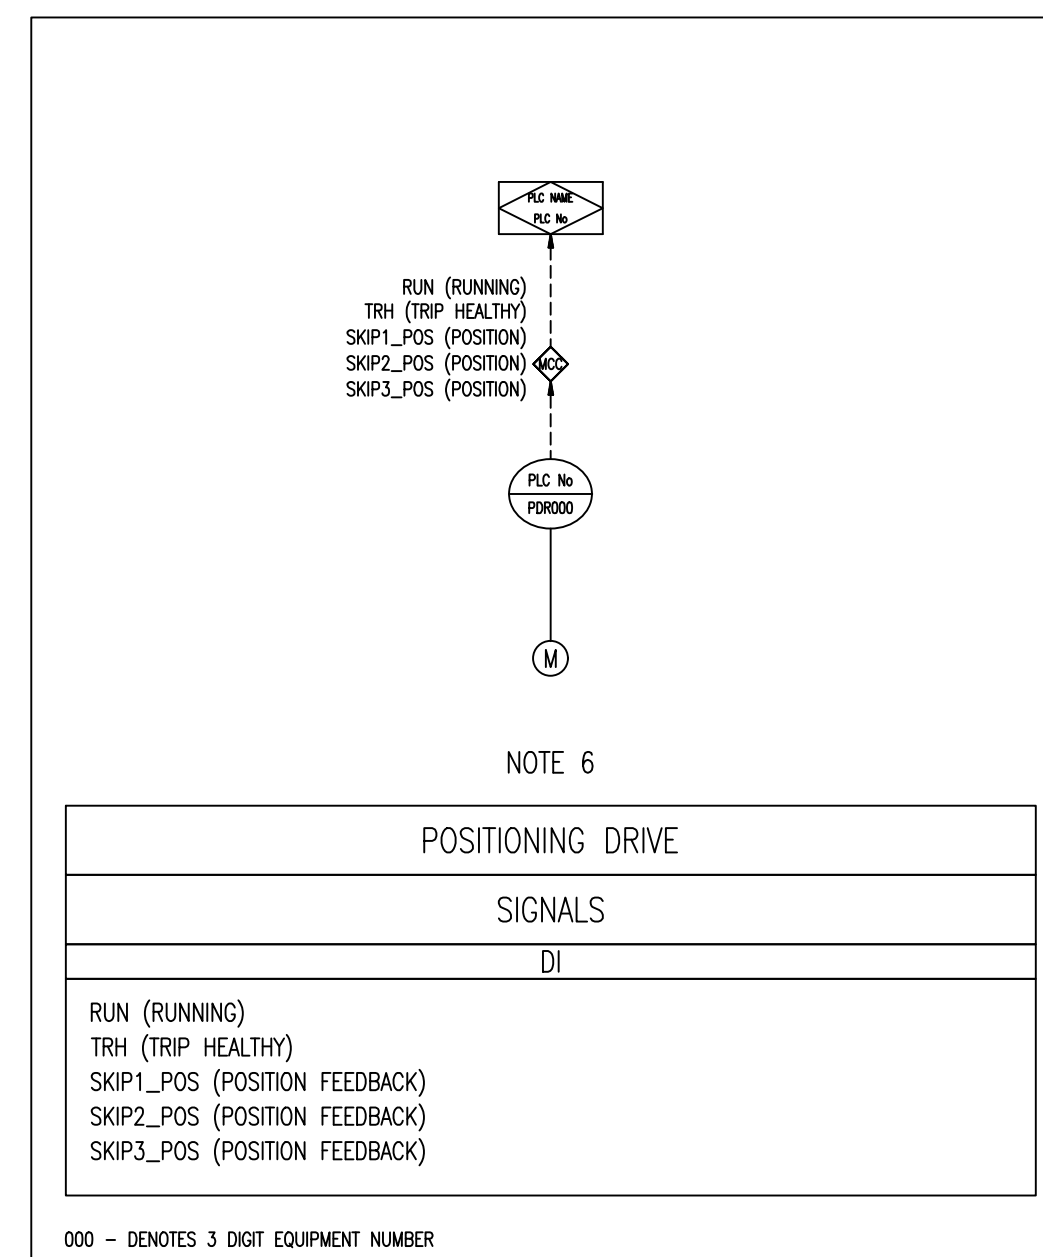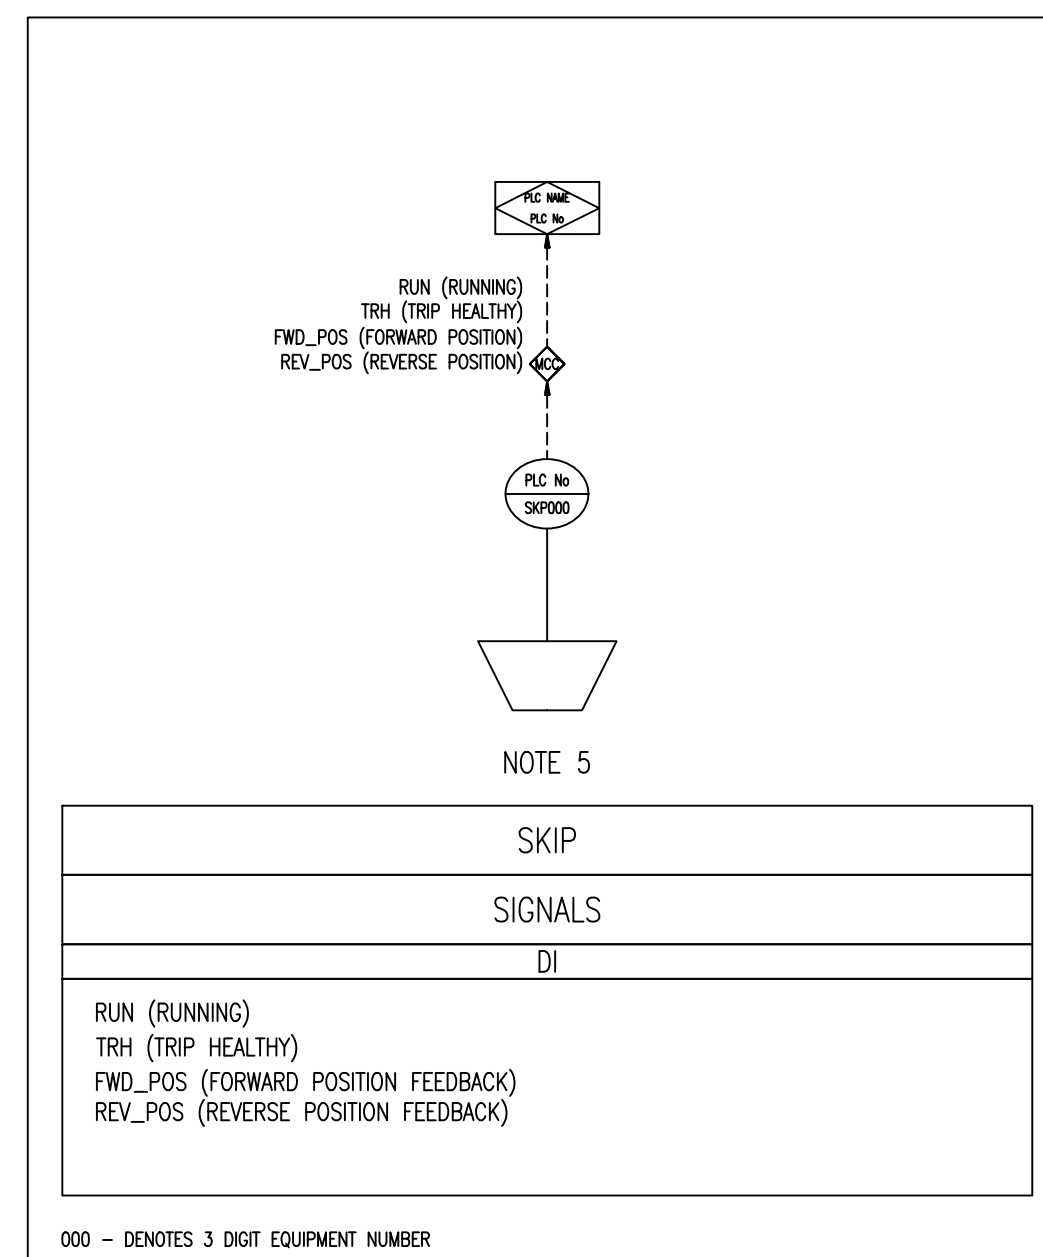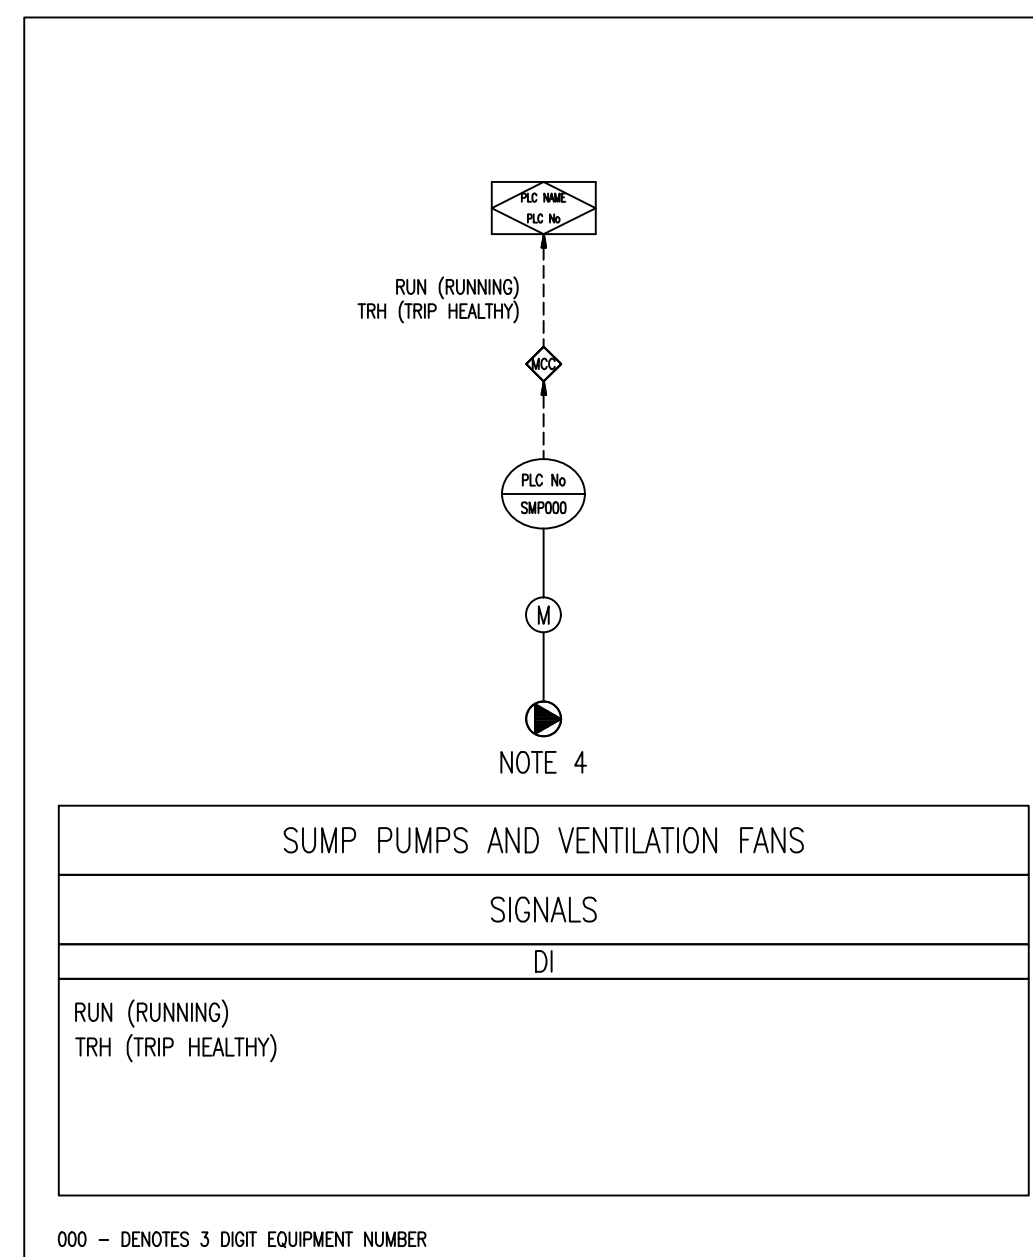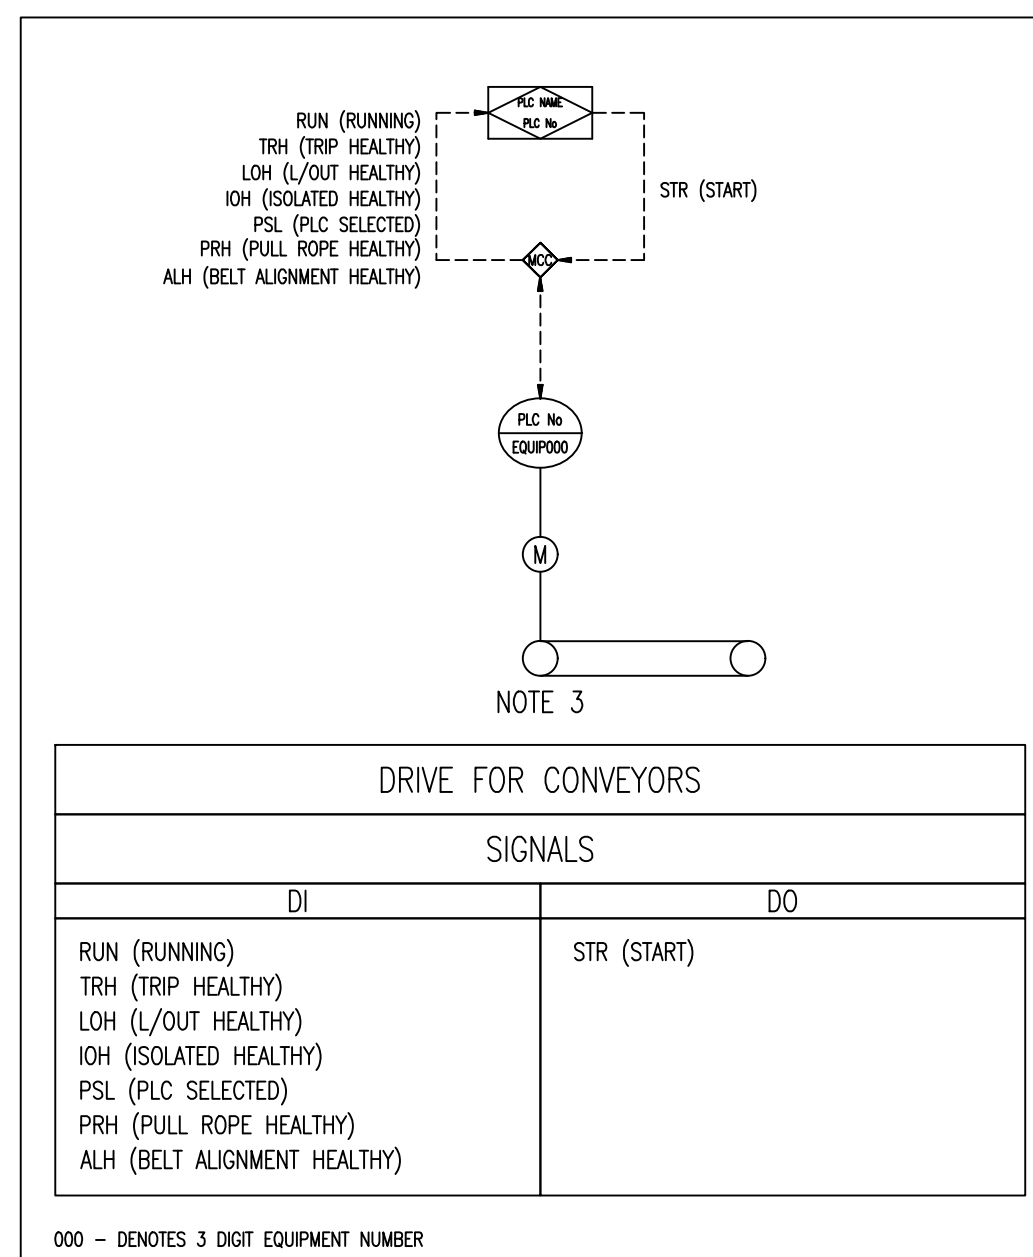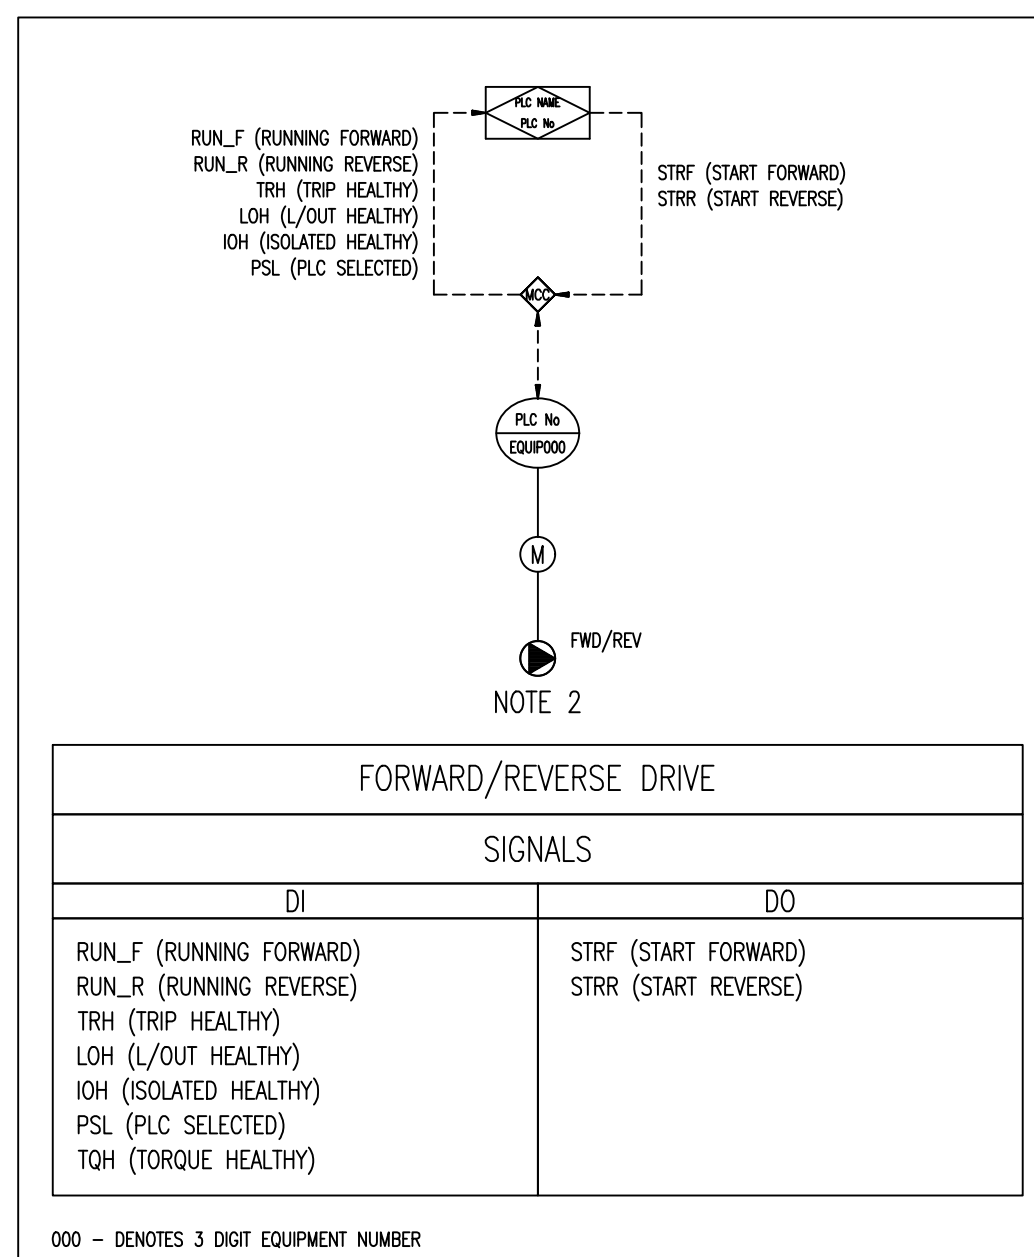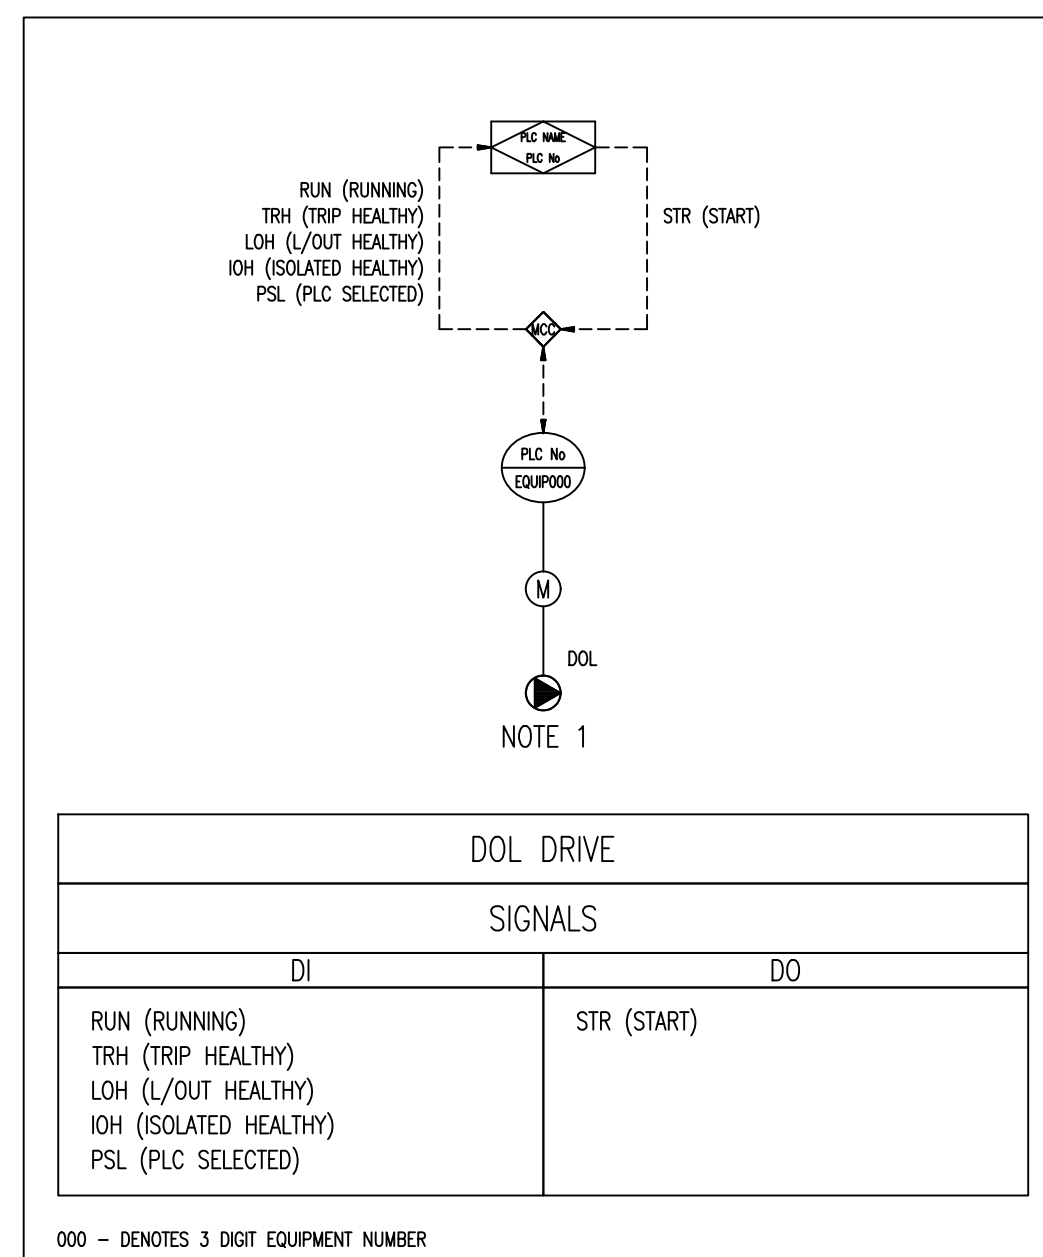




DEPARTMENT	APPROVED	DESIGNATION	DATE

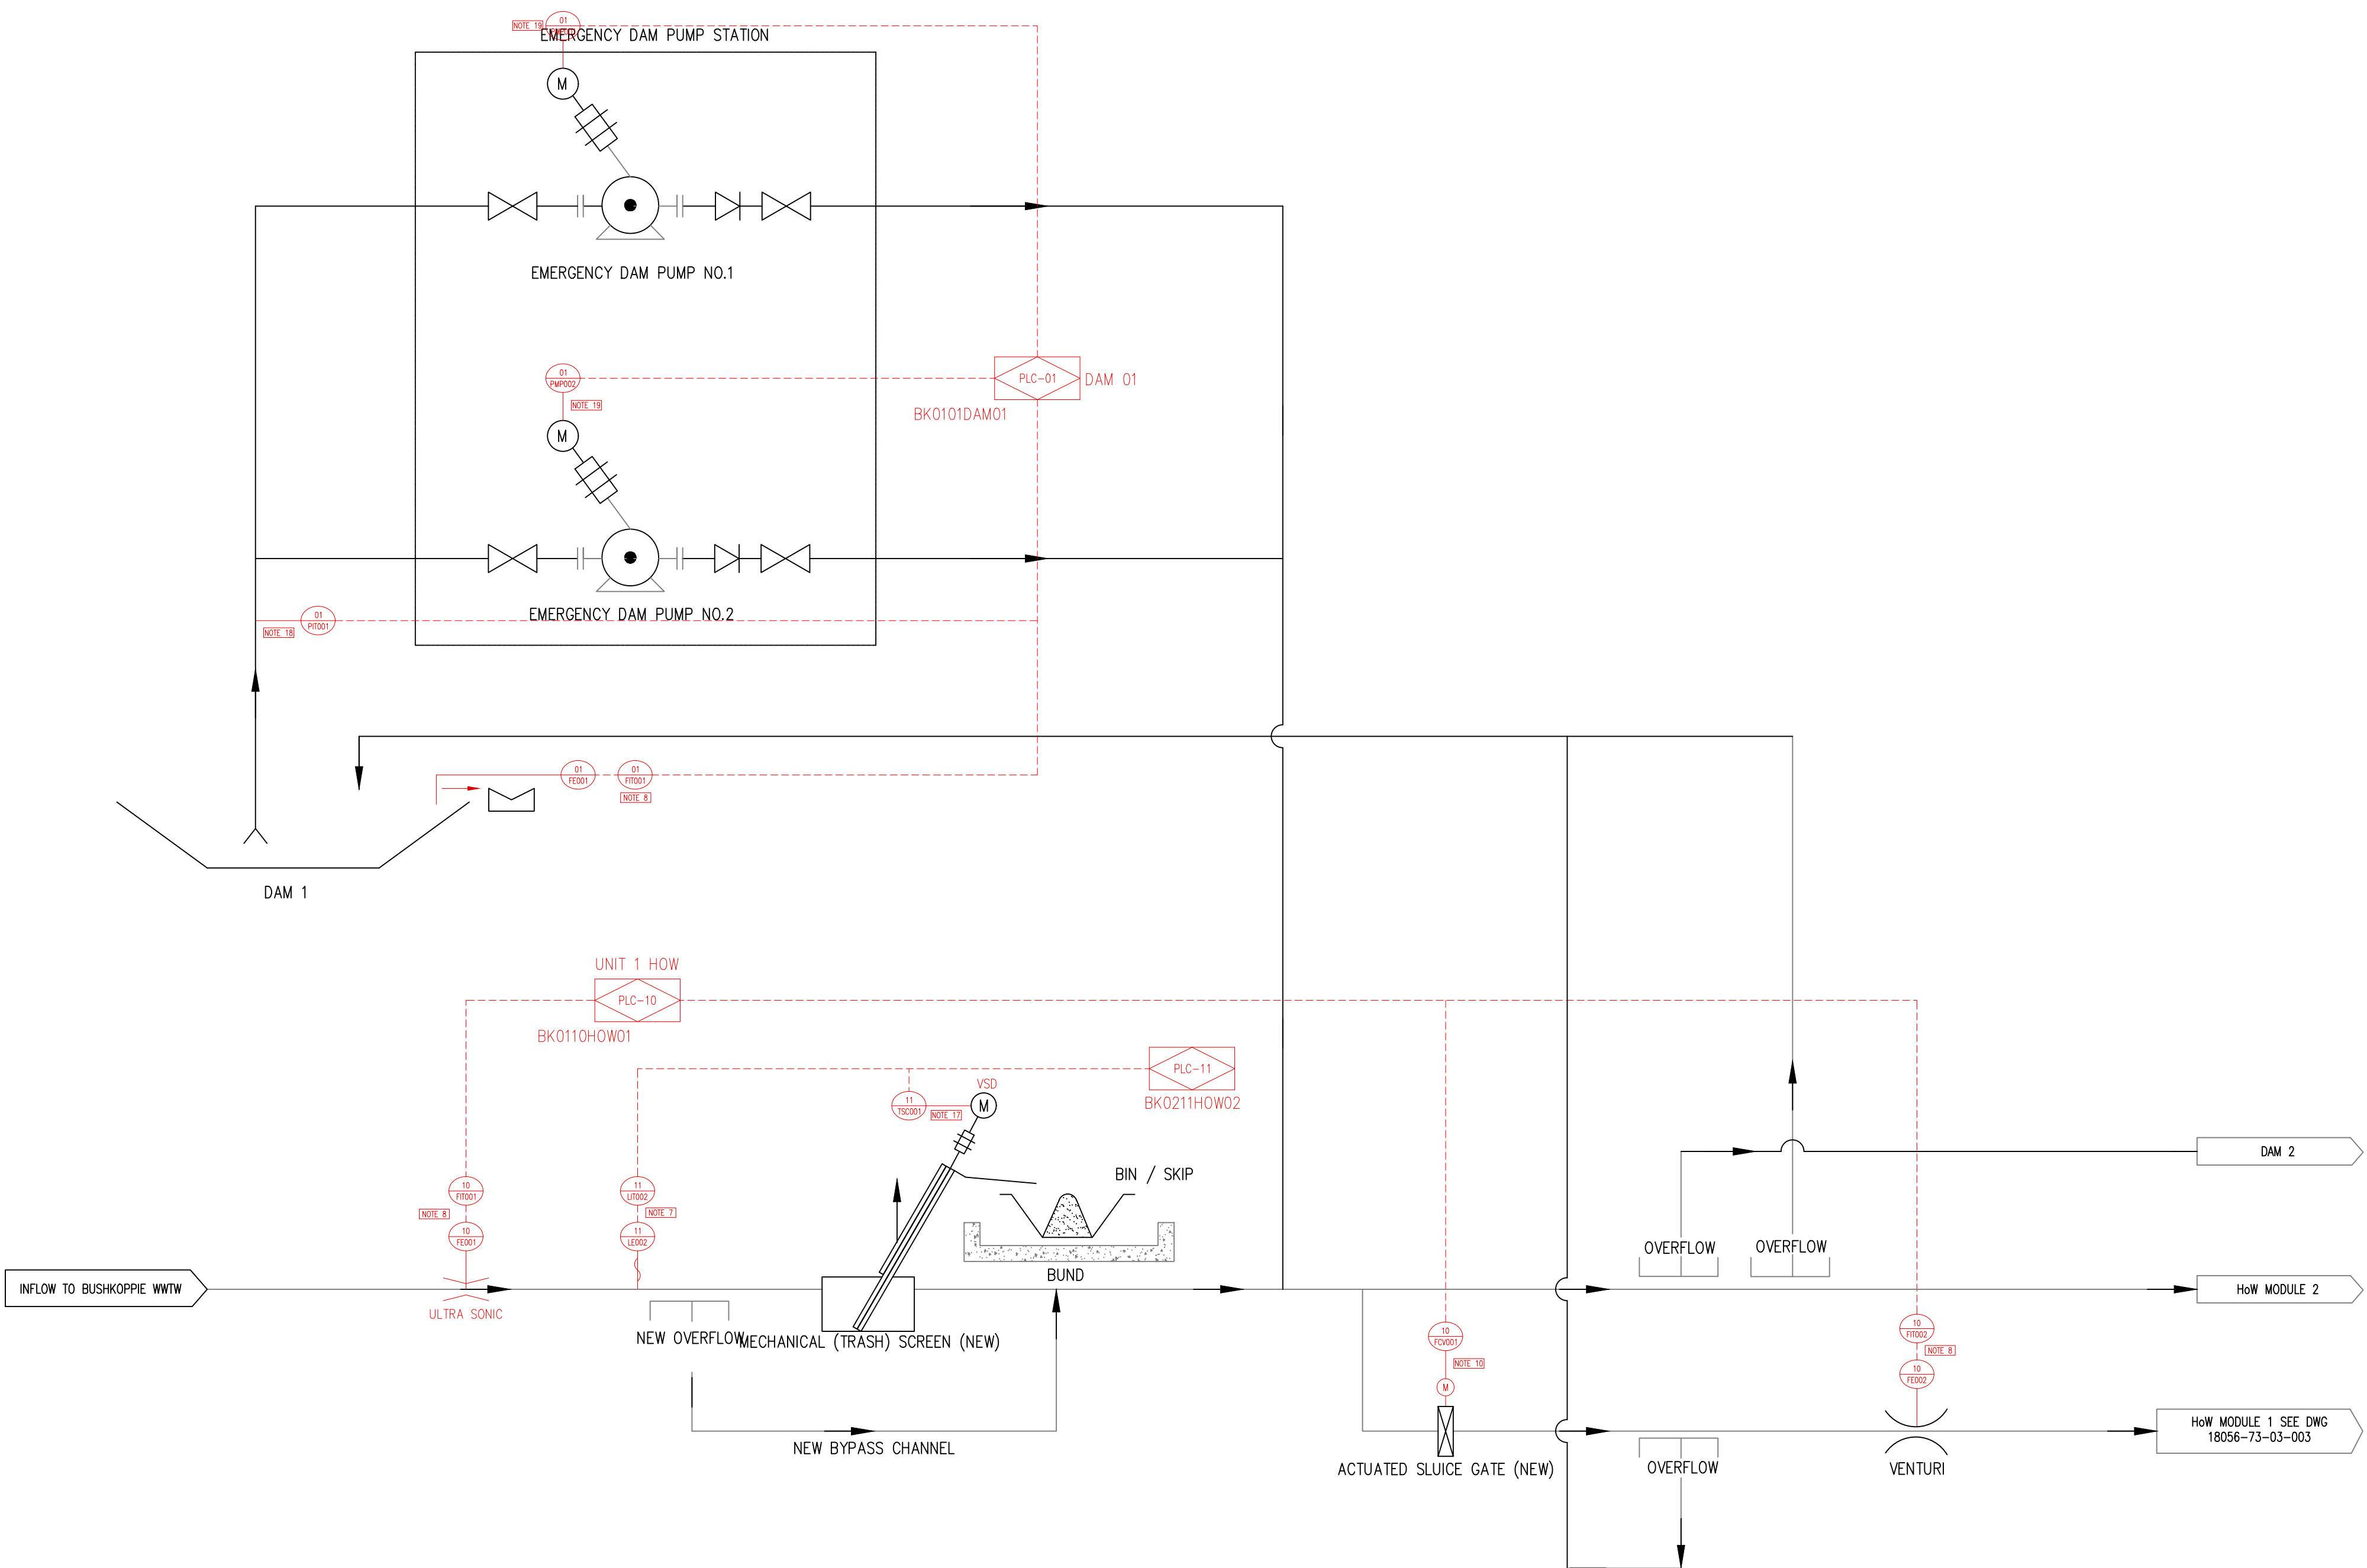


DEPARTMENT	APPROVED	DESIGNATION	DATE

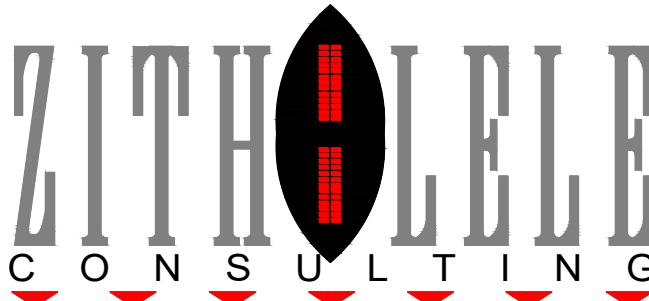
CONSULTING ENGINEERS			JOHANNESBURG WATER (SOC) LTD		CITY OF JOHANNESBURG				DESIGN MANAGER	SCALE	AMENDMENTS		APPROVED	DATE	DRAWING No.								
	ZITHOLELE P.O. BOX 6002 HALFWAY HOUSE 1685 TEL: (011) 207 2060 FAX: (086) 674 6121 EMAIL: mail@zitholele.co.za	 WSP Group Africa (Pty) Ltd Industrial Division Building C, Kingsbridge, 33 Sloane Street, Bryanston, 2191 Tel: +27 11 361 1300 Fax: +27 11 361 1431 www.wsp.com	SURVEYED		 Johannesburg Water	17 HARRISON STREET MARSHALLTOWN 2107 TEL: (011) 688-1400 FAX: (011) 688-1529	BUSHKOPPIE WASTEWATER TREATMENT WORKS INFRASTRUCTURE RENEWAL PLAN HOW INFLOW TO MODULE 1 AND MODULE 2 PROCESS AND INSTRUMENTATION DIAGRAM				NTS	TO	FOR TENDER	WB	16.08.21	JW NUMBER							
			DESIGNED	M. DYKE								T1	RE-ISSUED FOR TENDER	Cdt	07.01.25								
			DRAWN	W. BRITZ								CONSULTANT'S NUMBER CI-PID01 FILE No											
			CHECKED																				
			SERVICES CHECKED																				
GEOTECHNICAL INVESTIGATION																							
SERVICES																							
APPROVED																							
Pr. Eng. No.																							
DATE																							
DATE																							

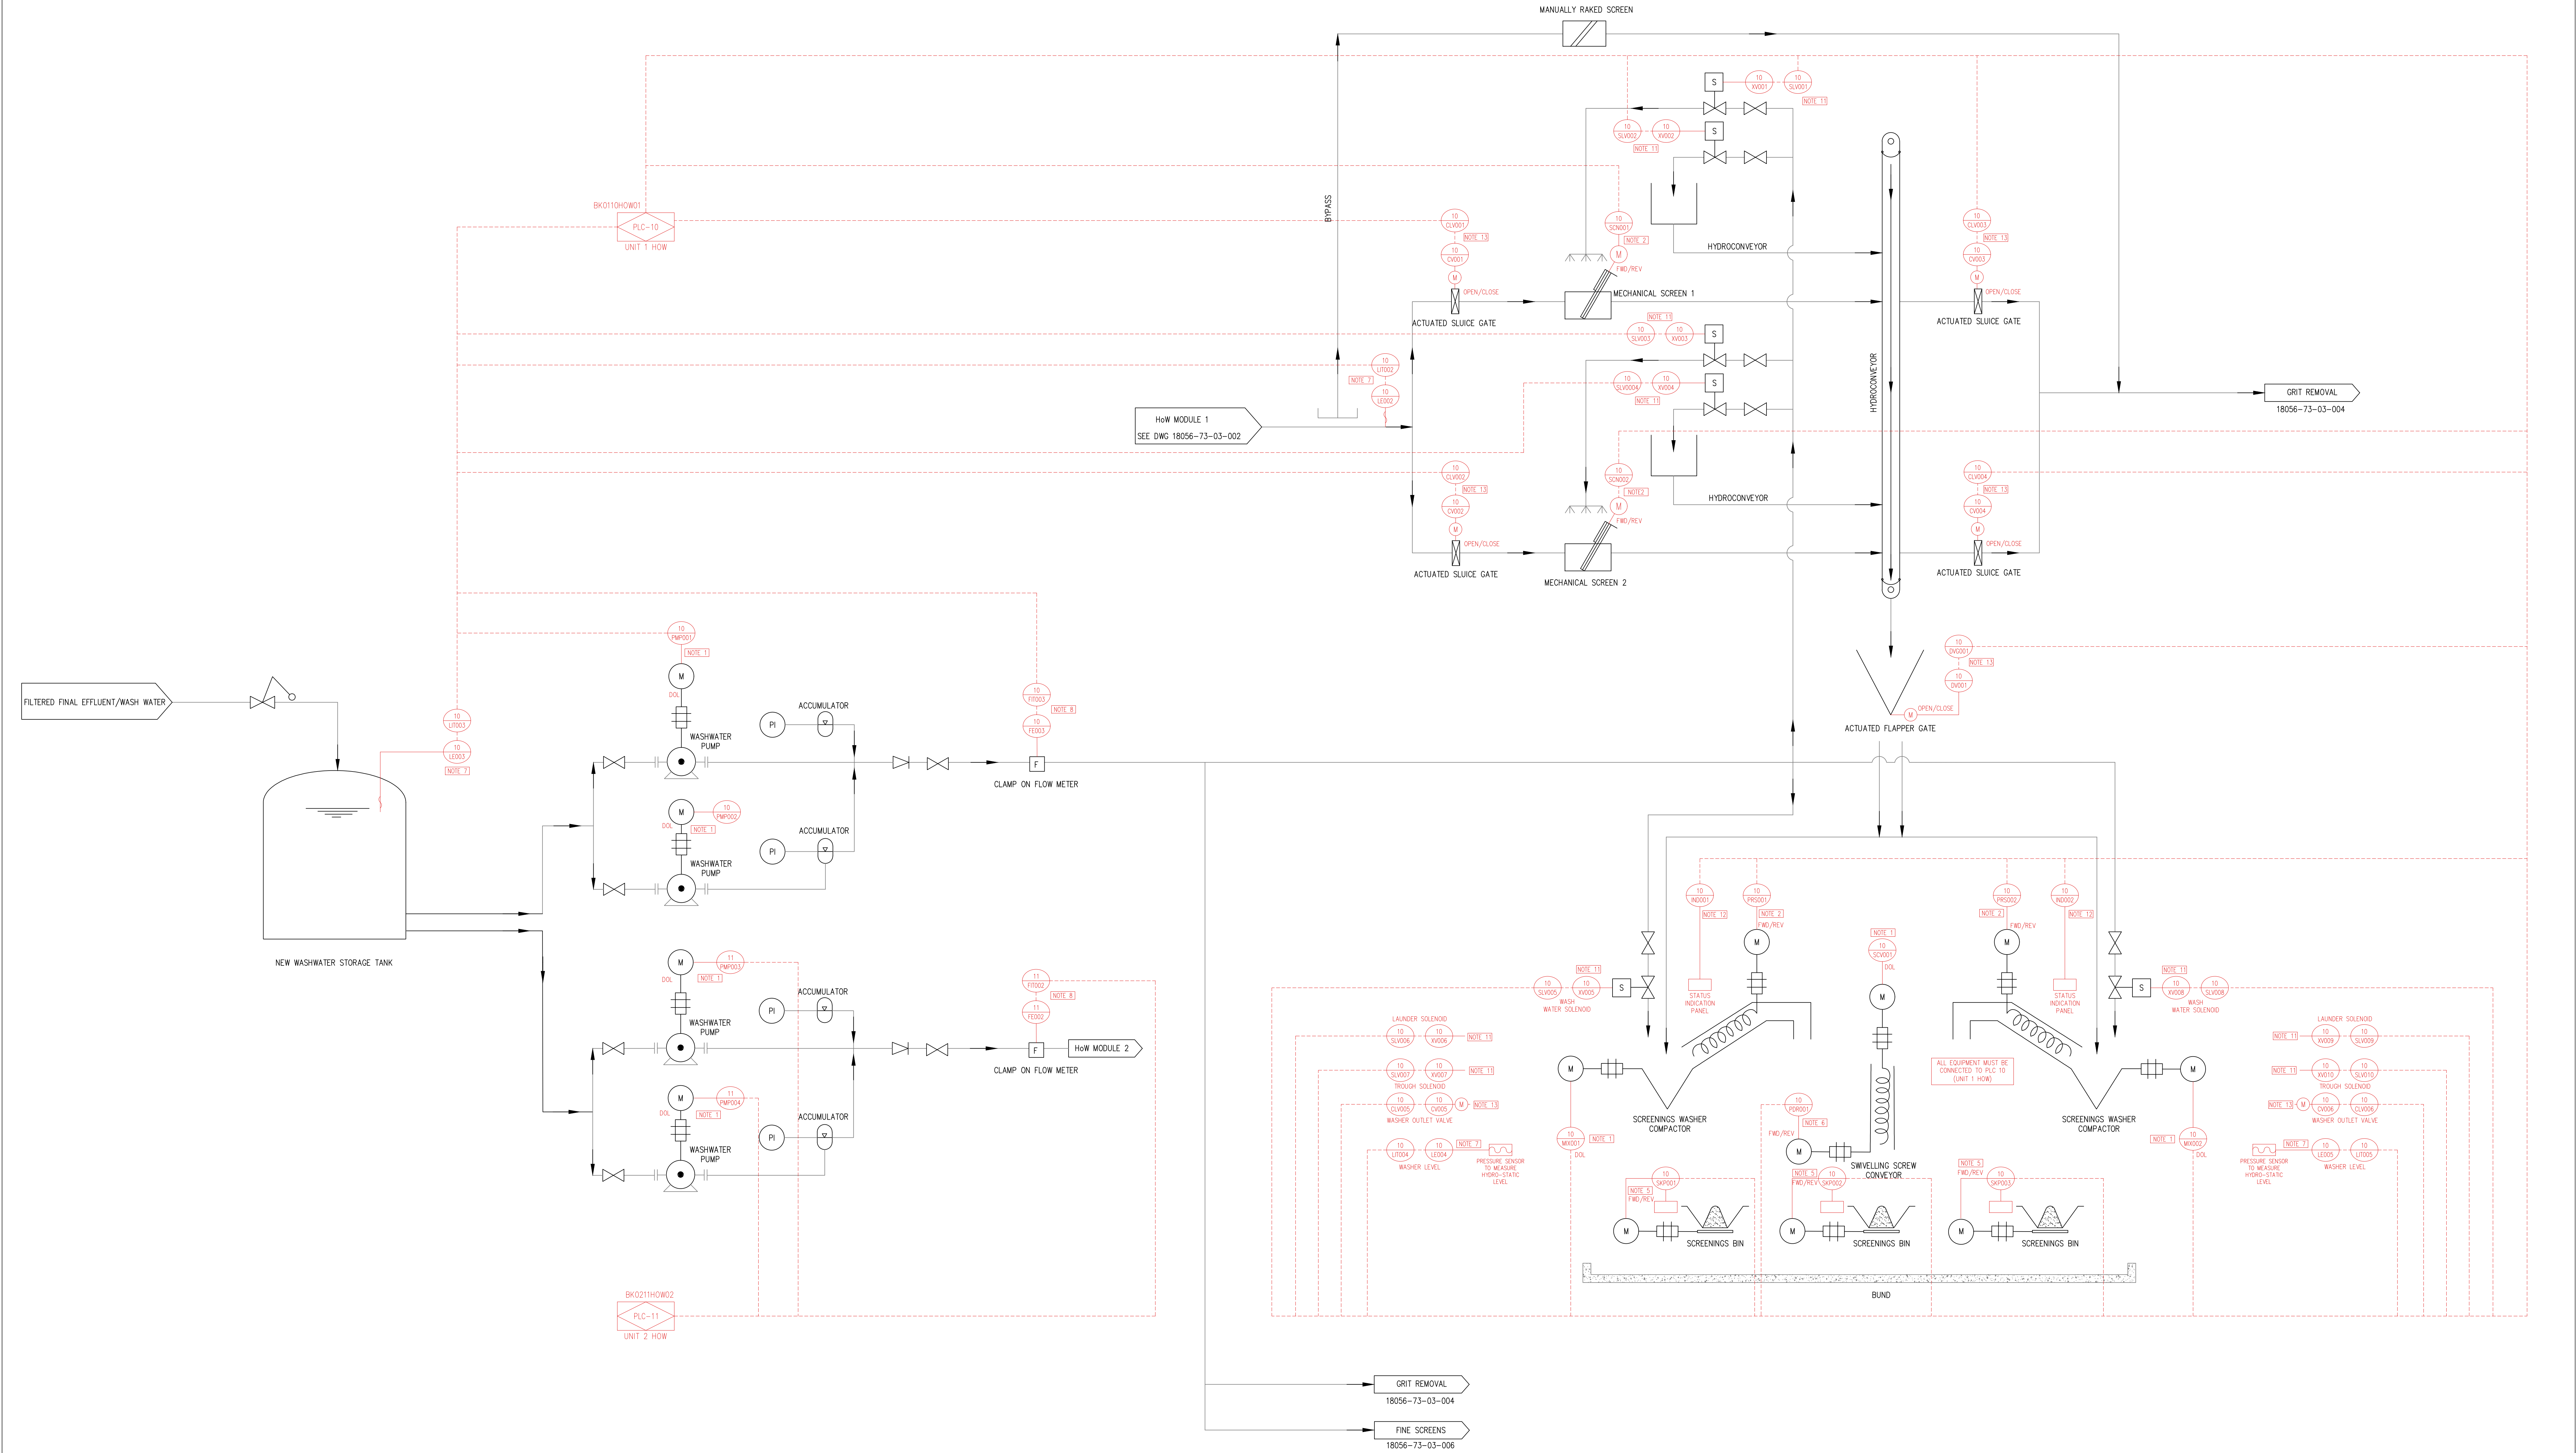

  
CONSULTING ENGINEERS				JOHANNESBURG WATER (SOC) LTD		CITY OF JOHANNESBURG				DESIGN MANAGER	SCALE	AMENDMENTS	APPROVED	DATE	DRAWING No.																																																																																																																																																																																																																																																																																																																																																																																																																																																																																																																																																																																																																																																																																																																																																																																																																																																																																																																																																																																																																																																																																																																																																																																																																																																											
	 WSP Group Africa (Pty) Ltd Industrial Division Building C, Kingsbridge 33 Bosanc Street, Bryanston, 2191 Tel: +27 11 361 1300 Fax: +27 11 361 1431 www.wsp.com		SURVEYED		17 HARRISON STREET MARSHALLTOWN 2107	BUSHKOPPIE WASTEWATER TREATMENT WORKS INFRASTRUCTURE RENEWAL PLAN HOW MODULE 1 – COARSE SCREENS PROCESS AND INSTRUMENTATION DIAGRAM				NTS	TO T1	FOR TENDER	WB	16.08.21	JW NUMBER																																																																																																																																																																																																																																																																																																																																																																																																																																																																																																																																																																																																																																																																																																																																																																																																																																																																																																																																																																																																																																																																																																																																																																																																																																																											
			DESIGNED									M. DYKE	RE-DESIGNED FOR TENDER			CONSULTANT'S NUMBER CI – PID02 FILE No																																																																																																																																																																																																																																																																																																																																																																																																																																																																																																																																																																																																																																																																																																																																																																																																																																																																																																																																																																																																																																																																																																																																																																																																																																																										
			DRAWN									W. BRITZ																																																																																																																																																																																																																																																																																																																																																																																																																																																																																																																																																																																																																																																																																																																																																																																																																																																																																																																																																																																																																																																																																																																																																																																																																																																														
			CHECKED																																																																																																																																																																																																																																																																																																																																																																																																																																																																																																																																																																																																																																																																																																																																																																																																																																																																																																																																																																																																																																																																																																																																																																																																																																																																							
			SERVICES CHECKED																																																																																																																																																																																																																																																																																																																																																																																																																																																																																																																																																																																																																																																																																																																																																																																																																																																																																																																																																																																																																																																																																																																																																																																																																																																																							

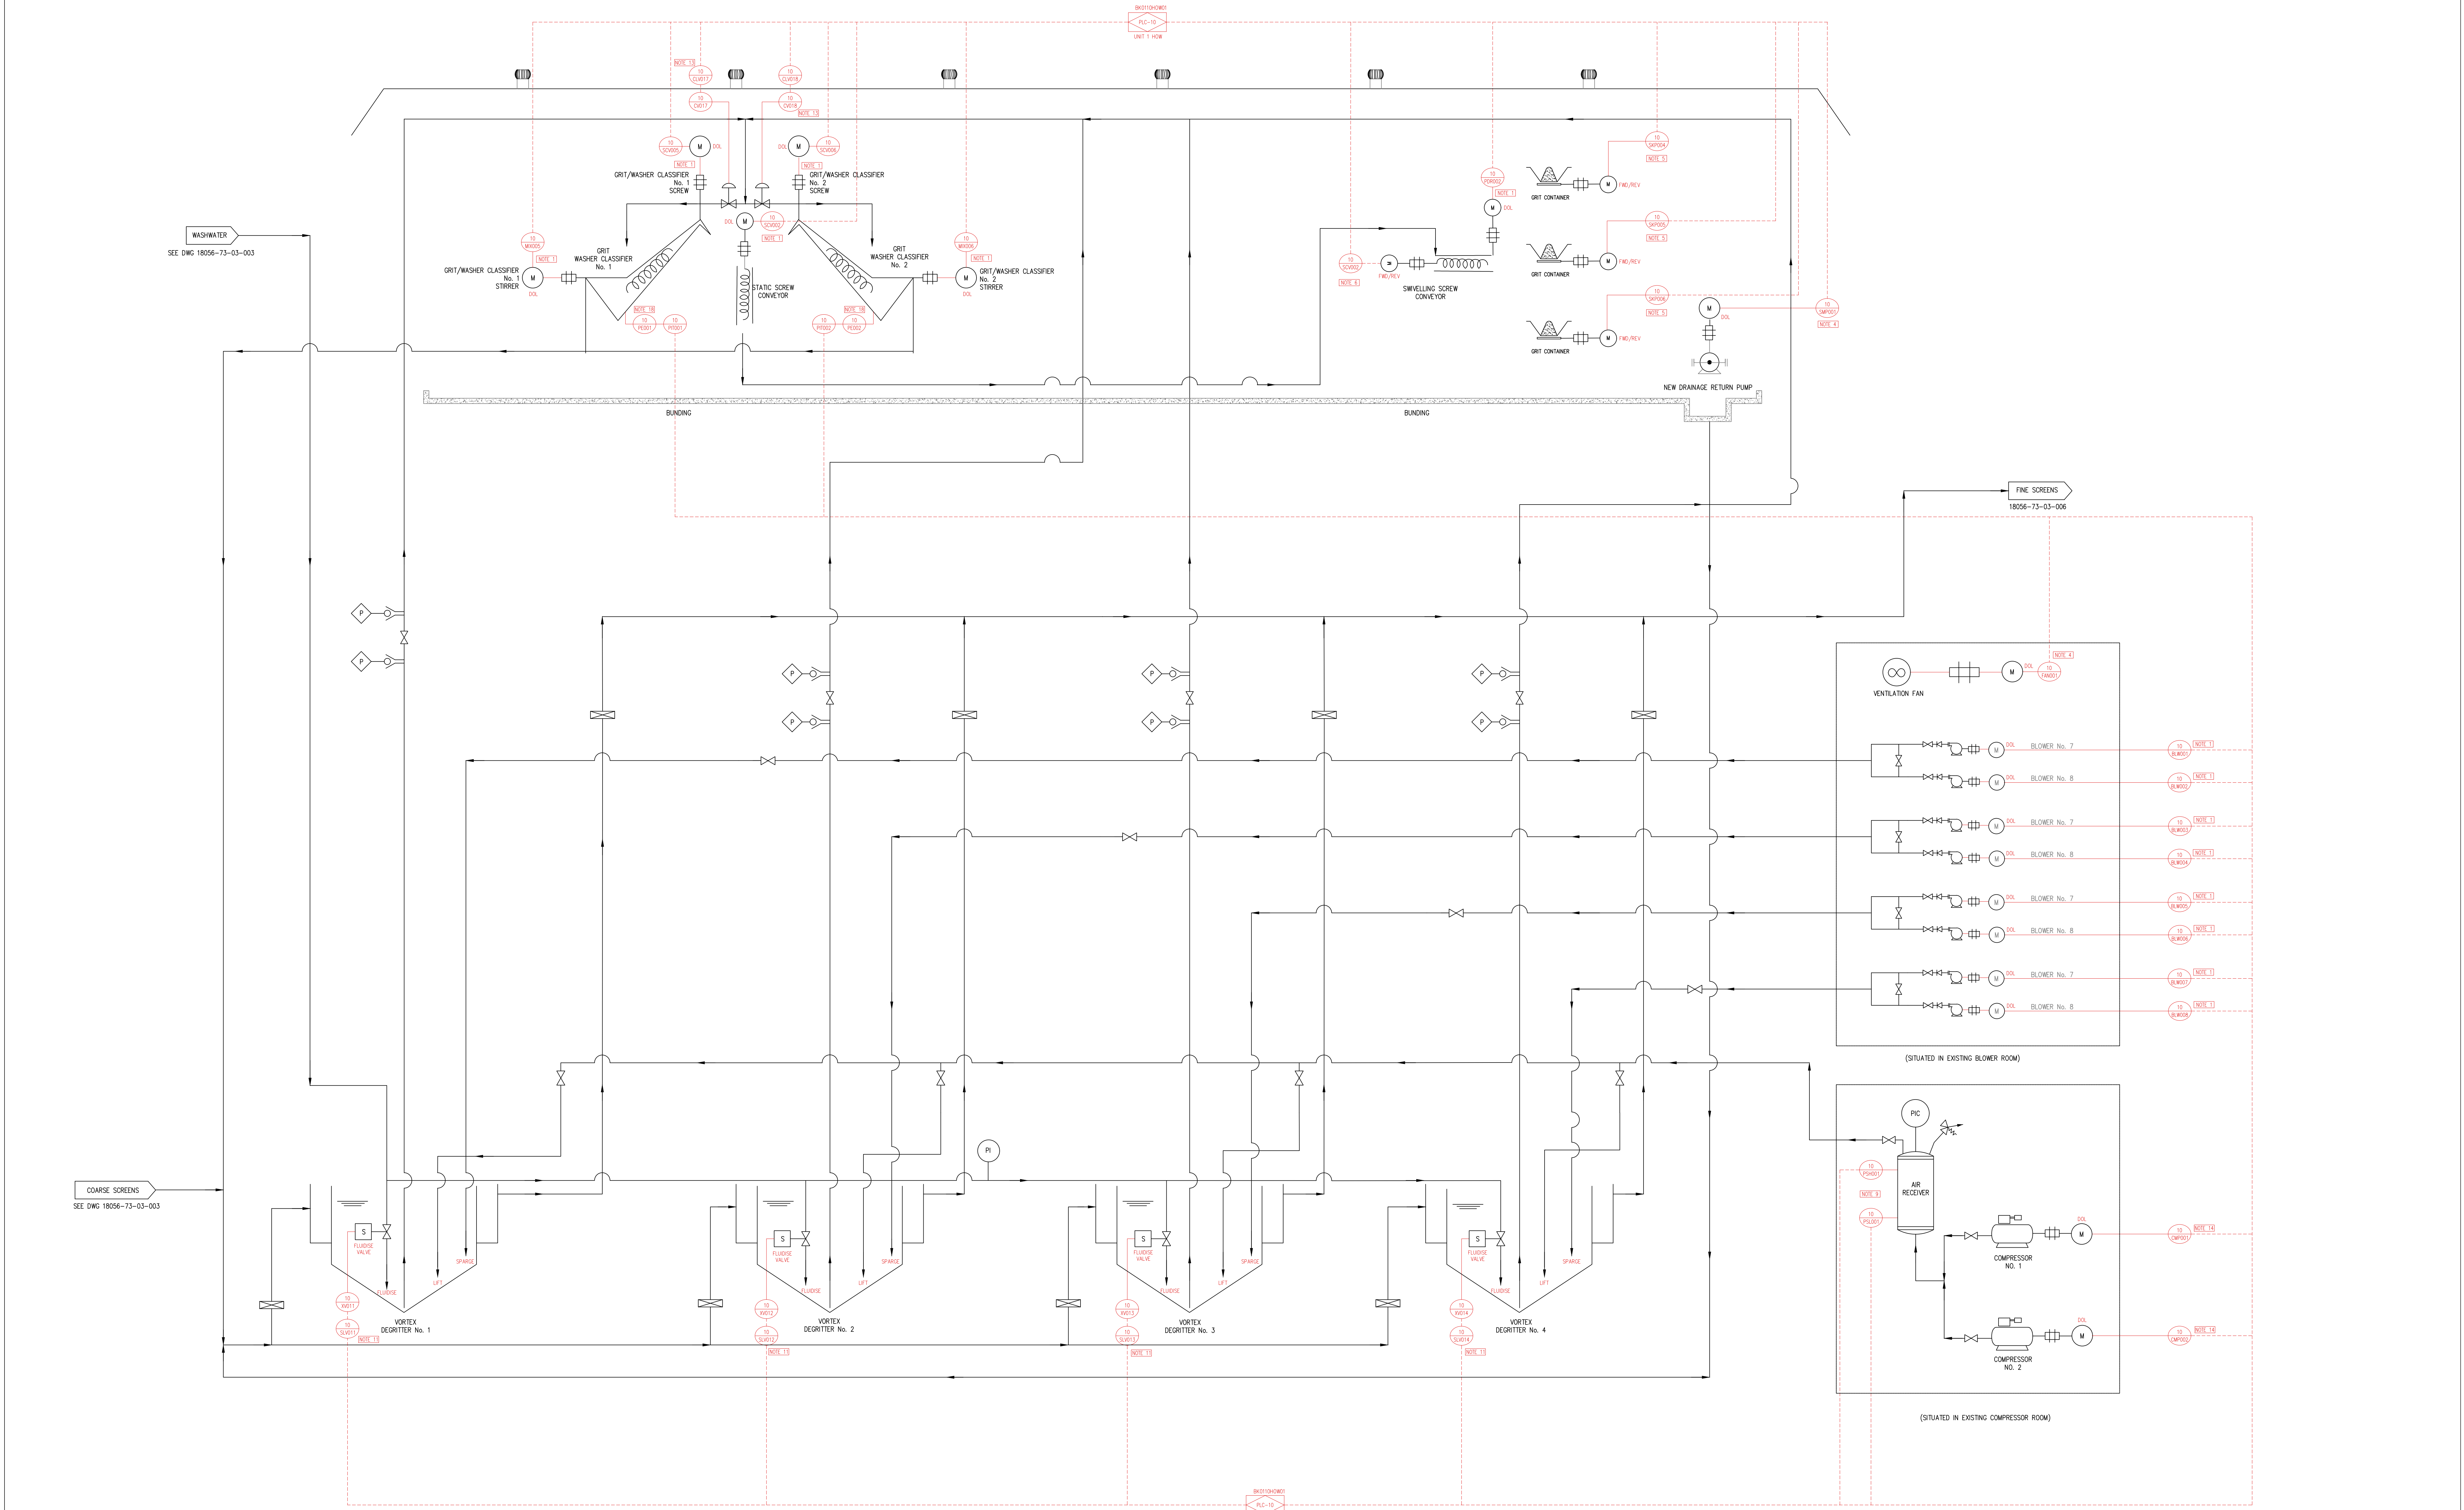


															DEPARTMENT	APPROVED	DESIGNATION	DATE

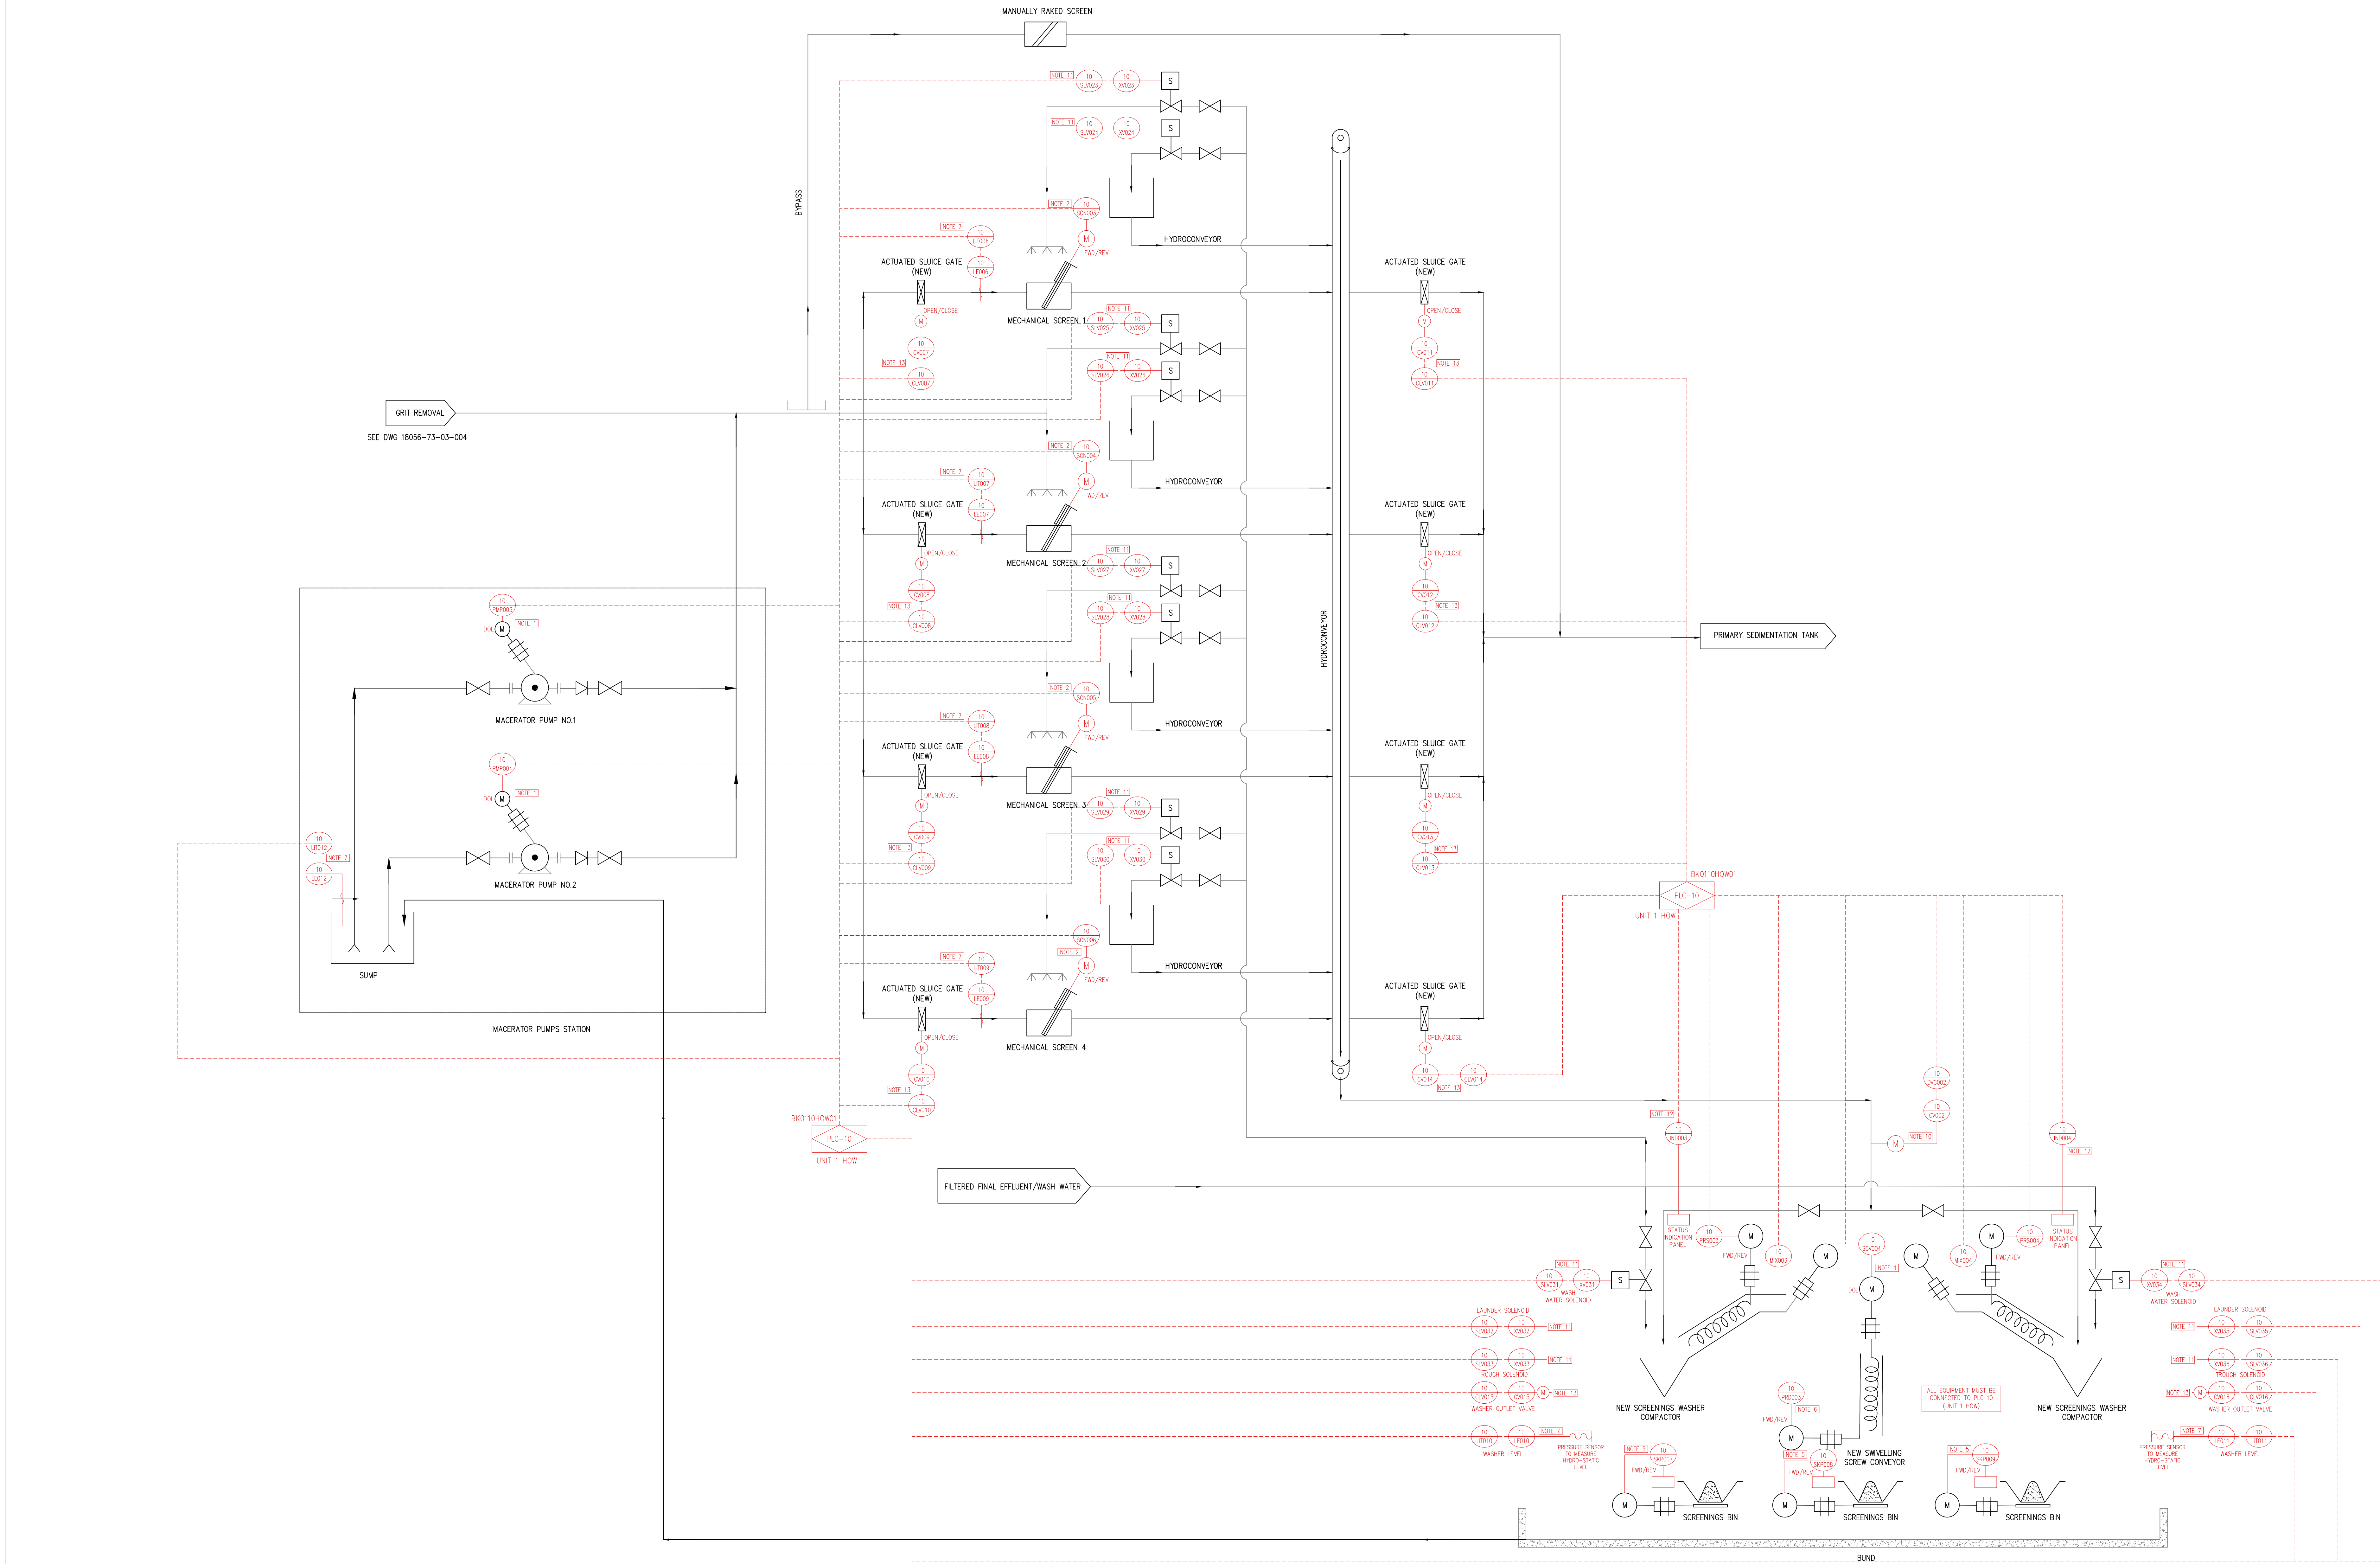


										DEPARTMENT		APPROVED		DESIGNATION		DATE																											
CONSULTING ENGINEERS										SURVEYED						JOHANNESBURG WATER (SOC) LTD		CITY OF JOHANNESBURG						DESIGN MANAGER		SCALE		AMENDMENTS		APPROVED		DATE		DRAWING No.									
 ZITHOLELE P.O. BOX 6002 HALFWAY HOUSE 1685 TEL: (011) 207 2060 FAX: (086) 674 6121 EMAIL: mail@zitholele.co.za  WSP Group Africa (Pty) Ltd Industrial Division Building C, Kingsbridge 33 Bonaire Street, Bryanston, 2191 Tel: +27 11 361 1300 Fax: +27 11 361 1431 www.wsp.com										DESIGNED				 Johannesburg Water		17 HARRISON STREET MARSHALLTOWN 2107		BUSHKOPPIE WASTEWATER TREATMENT WORKS INFRASTRUCTURE RENEWAL PLAN HOW MODULE 1 – FINE SCREENS PROCESS AND INSTRUMENTATION DIAGRAM										NTS		TO		FOR TENDER		WB		16.08.21		JW NUMBER					
										DRAWN		M. DYKE				RE-ISSUED FOR TENDER														C&T		07.11.25		CONSULTANT'S NUMBER									
										CHECKED		W. BRITZ																						CI-PID05									
										SERVICES CHECKED																								FILE No									
										GEOTECHNICAL INVESTIGATION																																	
										APPROVED																								TO T1									
										Pr. Eng. No.																																	
										DATE																																	

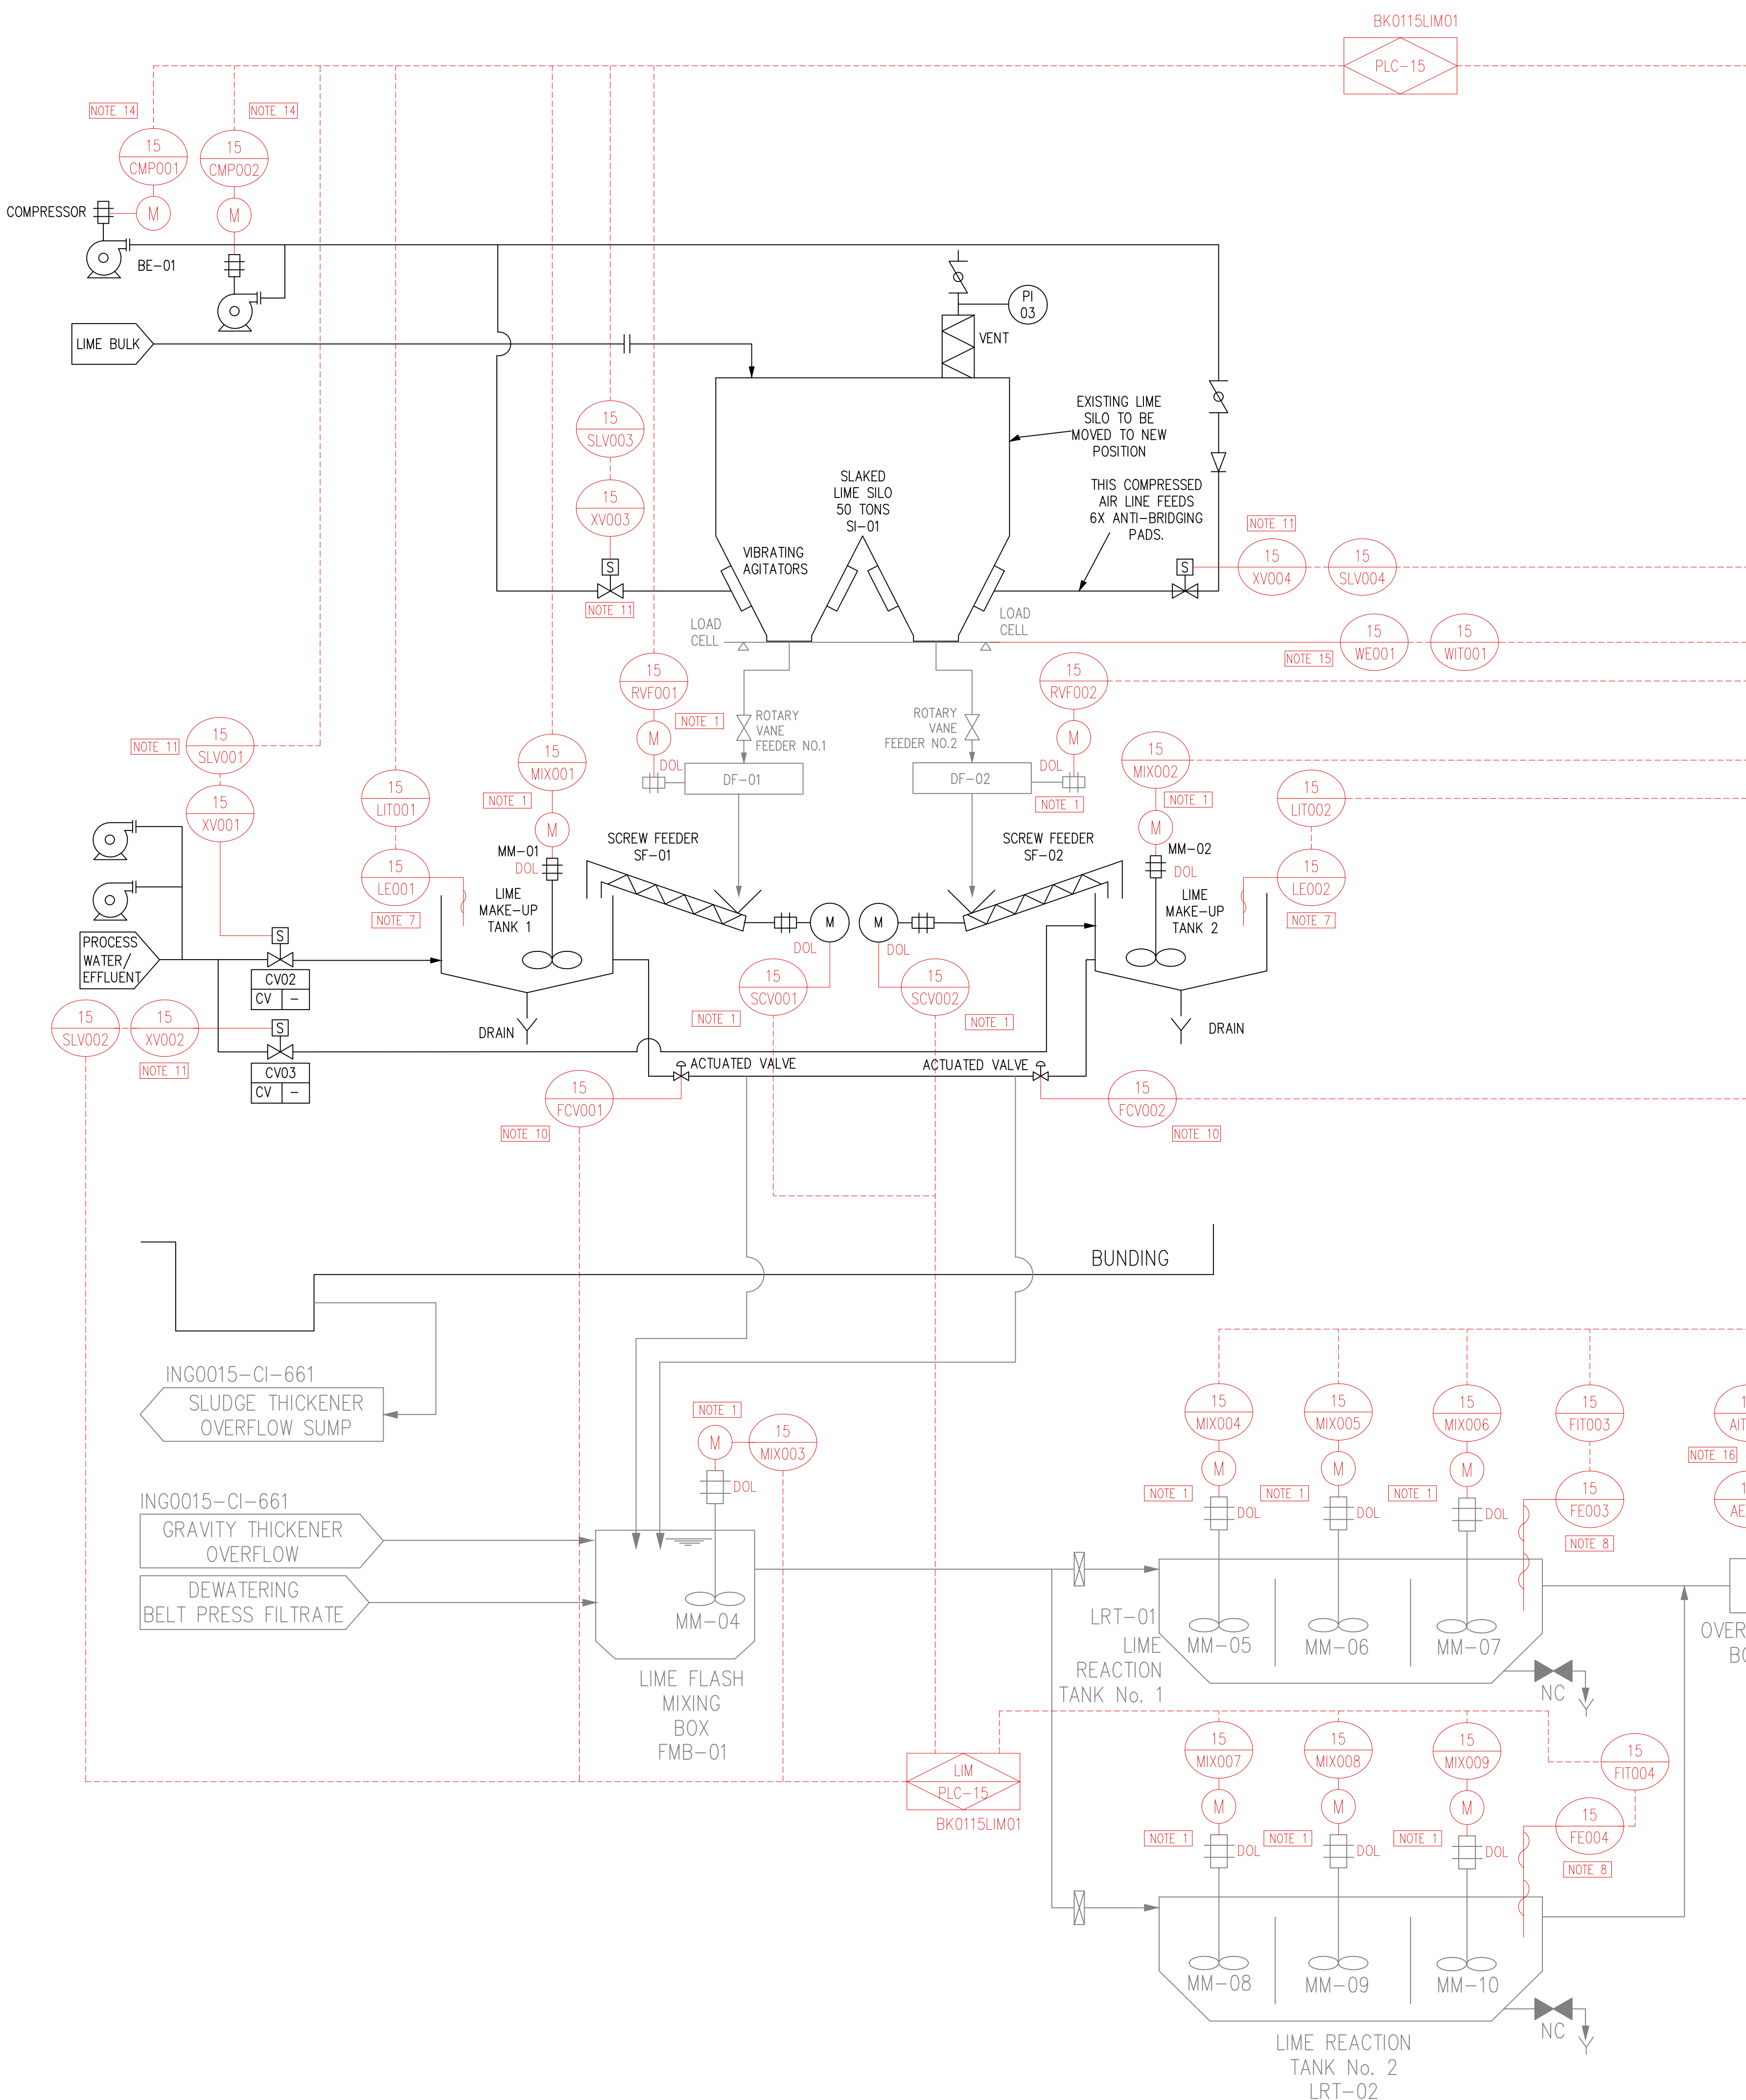



EXISTING

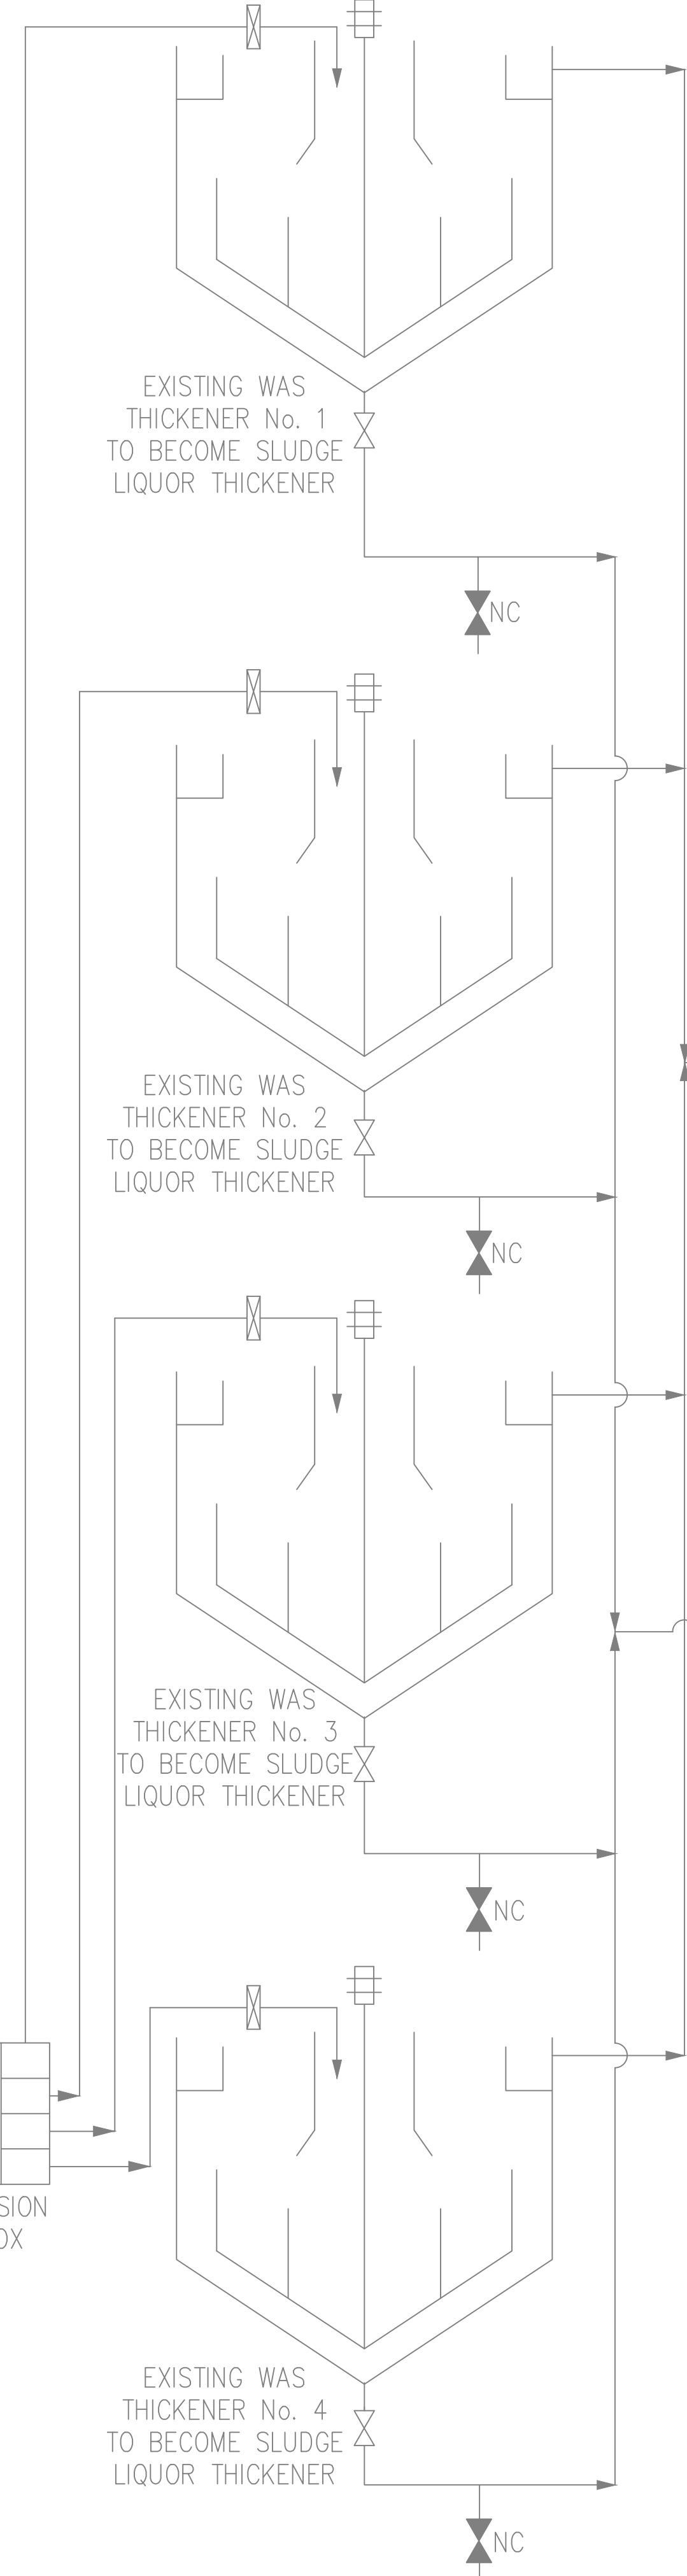


EXISTING

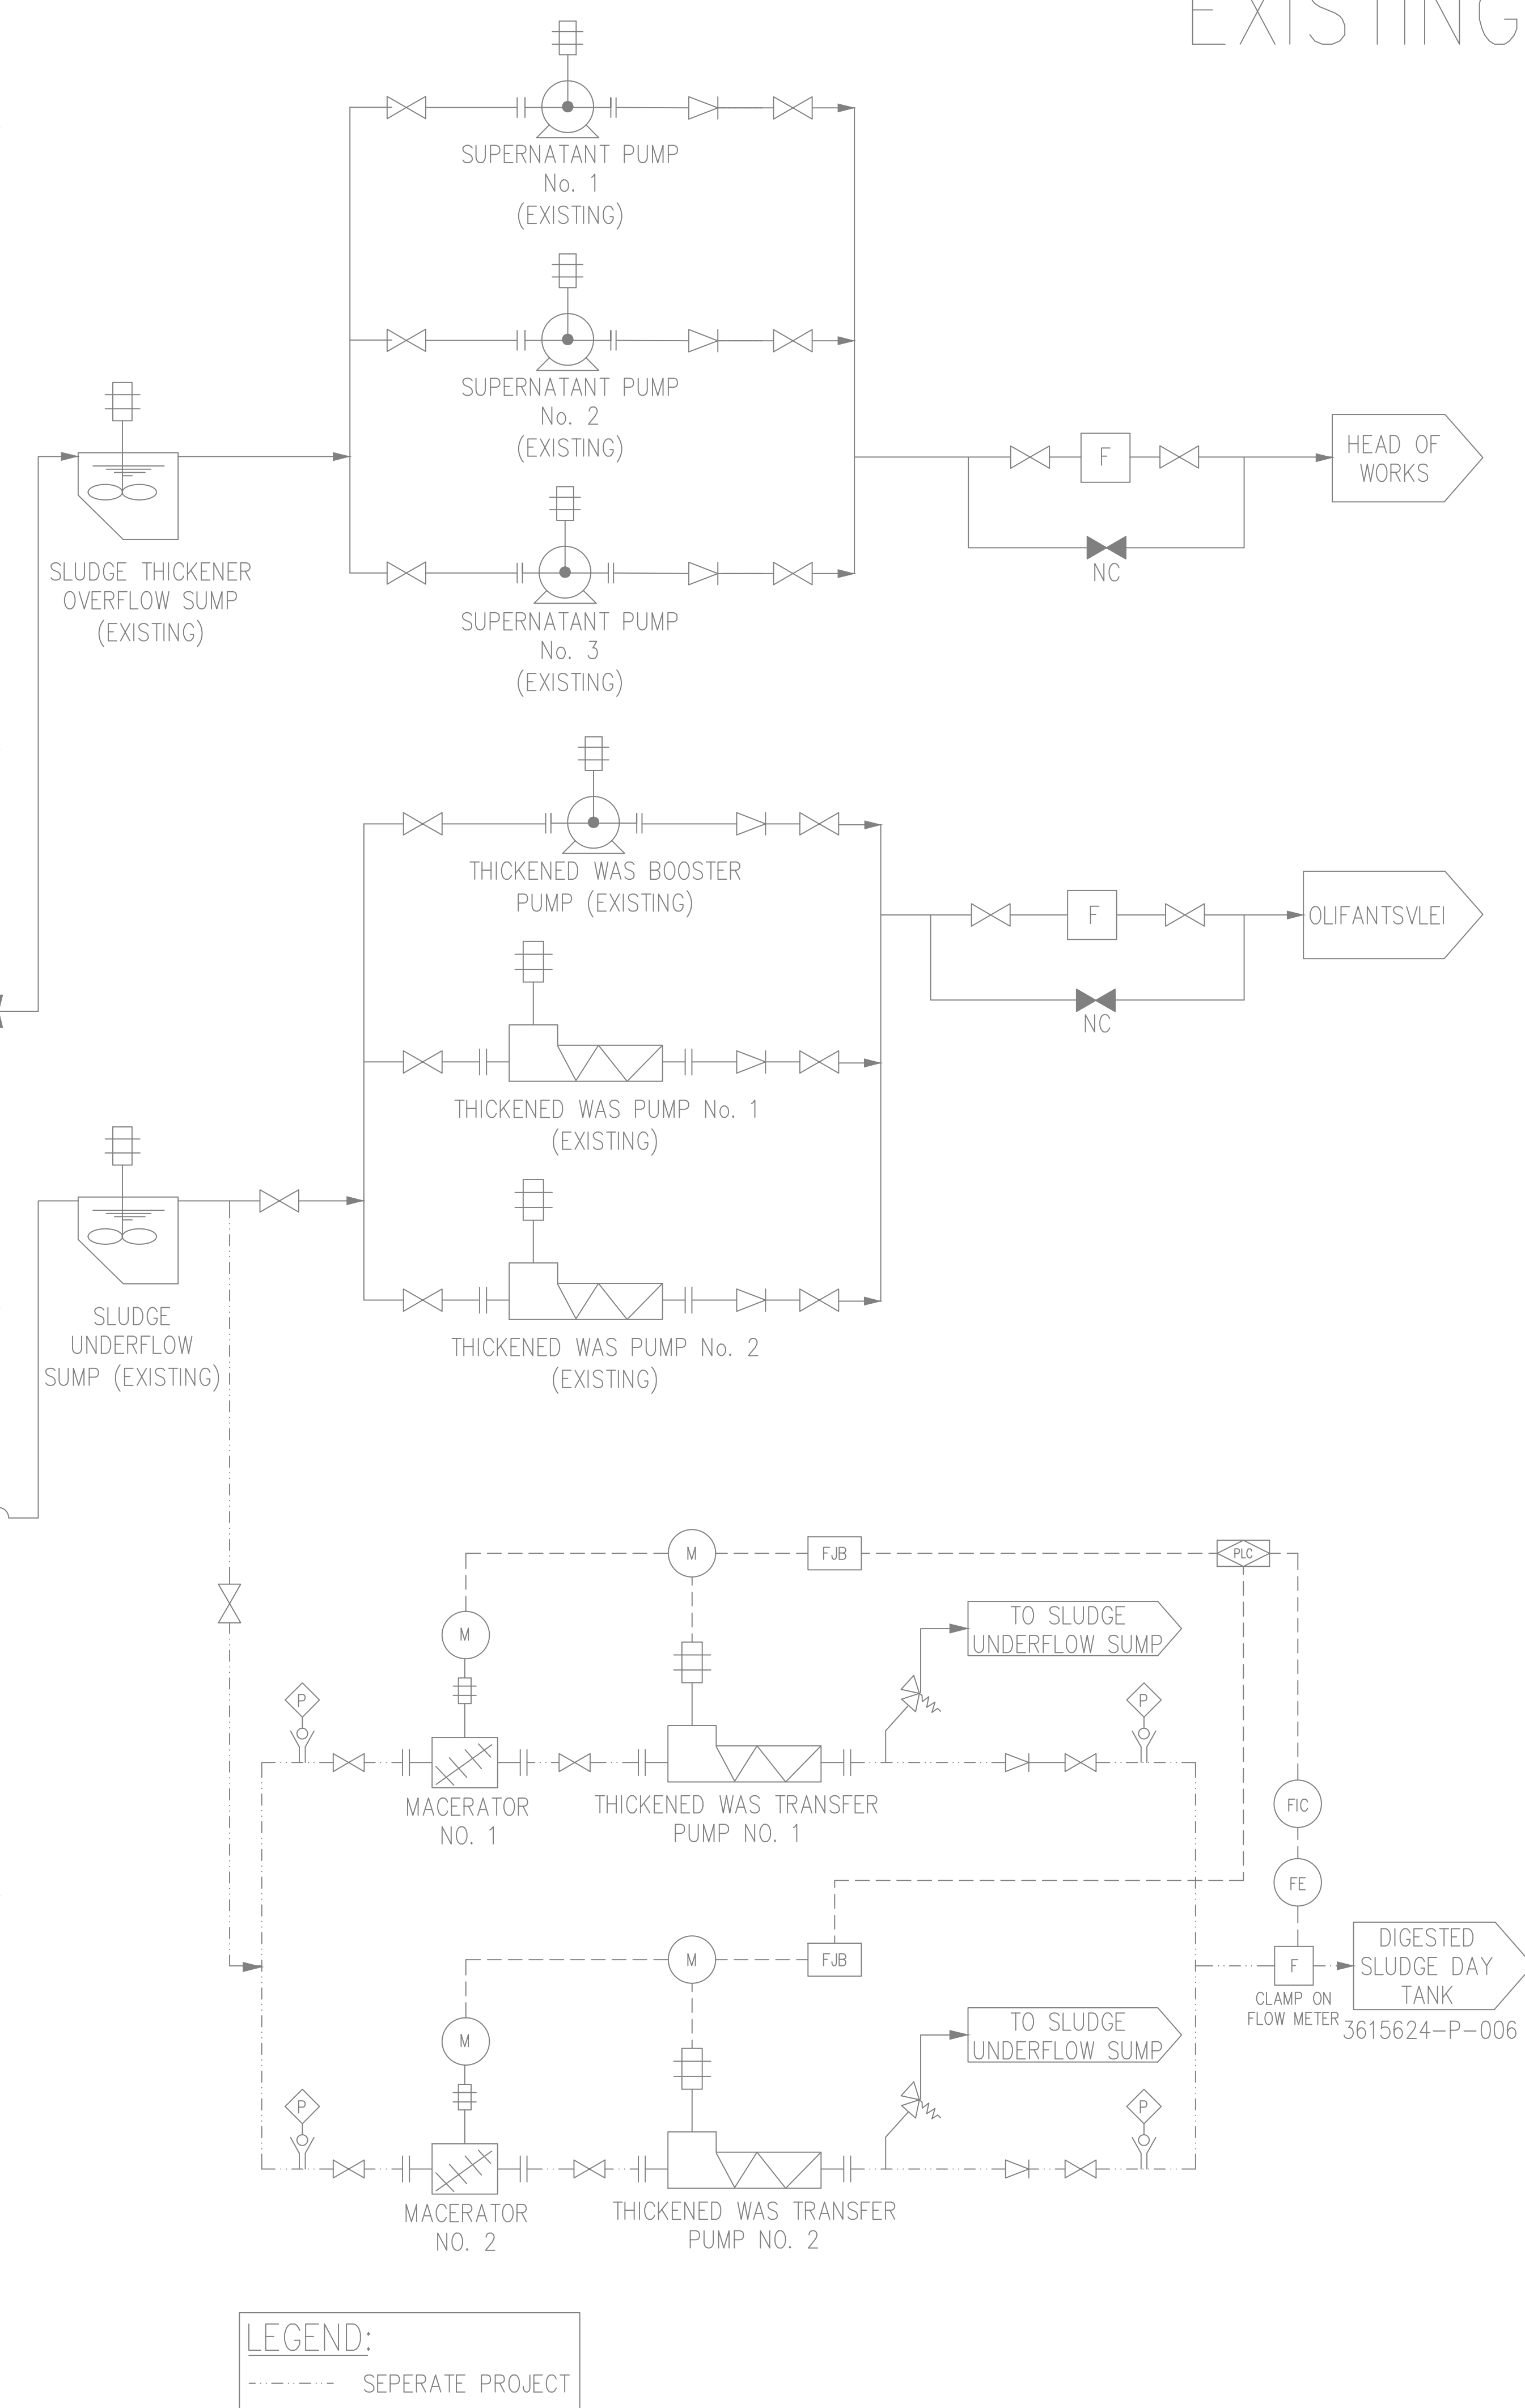

LEGEND:
----- SEPERATE PROJECT

  CONSULTING ENGINEERS			SURVEYED DESIGNED		JOHANNESBURG WATER (SOC) LTD		CITY OF JOHANNESBURG			DESIGN MANAGER	SCALE	AMENDMENTS		APPROVED	DATE	DRAWING No.				
	ZITHOLELE P.O. BOX 6002 HALFWAY HOUSE 1685 TEL: (011) 207 2060 FAX: (086) 674 6121 EMAIL: mail@zitholele.co.za	 WSP Group Africa (Pty) Ltd Industrial Division Building C, Kingsmead 33 Bosman Street, Bryanston, 2191 Tel: +27 11 361 1300 Fax: +27 11 361 1431 www.wsp.com	 Johannesburg Water	17 HARRISON STREET MARSHALLTOWN 2107 TEL: (011) 688-1400 FAX: (011) 688-1529	BUSHKOPPIE WASTEWATER TREATMENT WORKS INFRASTRUCTURE RENEWAL PLAN LIME DOSING PLANT PROCESS AND INSTRUMENTATION DIAGRAM				TO			FOR TENDER	WB			16.08.21	JW NUMBER			
									T1	RE-ISSUED FOR TENDER	CdT	07.01.25	CONSULTANT'S NUMBER CI-PID06							
												FILE No								
												TO T1								
			DATE						DATE											

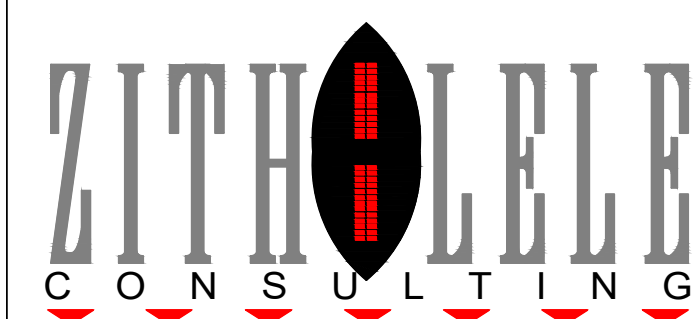

**ZITHOLELE
P.O. BOX 6002
HALFWAY HOUSE
1685
TEL: (011) 207 2060
FAX: (086) 674 6121
EMAIL: mail@zitholele.co.za**

wsp
WSP Group Africa (Pty) Ltd
Industrial Division
Building C, Knightsbridge,
33 Sloane Street, Bryanston, 2191
Tel: +27 11 361 1300 Fax: +27 11 361 1431 www.wsp.com

JOHANNESBURG WATER (SOC) LTD

**17 HARRISON STREET
MARSHALLTOWN
2107**

**TEL: (011) 688-1400
FAX: (011) 688-1529**

**DESIGN
MANAGER**

SCALING

AMENDMENTS

APPROVED

DATE _____

DRAWING No.

DATE _____

NTS

TO	FOR TENDER
----	------------

WB

16.08.21


JW NUMBER


CONSULTANT'S NUMBER

FILE No.

--	--	--	--	--	--

DEPARTMENT	APPROVED	DESIGNATION	DATE

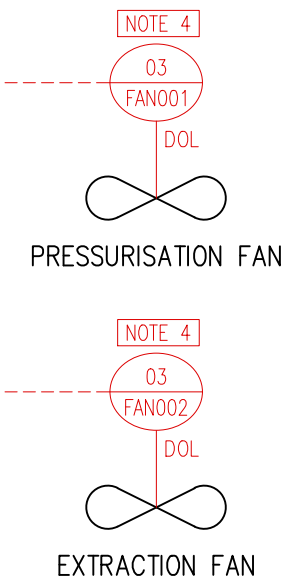

 CONSULTING ENGINEERS			SURVEYED		JOHANNESBURG WATER (SOC) LTD		CITY OF JOHANNESBURG			DESIGN MANAGER	SCALE	AMENDMENTS		APPROVED	DATE	DRAWING No.					
	ZITHOLELE P.O. BOX 6002 HALFWAY HOUSE 1685 TEL: (011) 207 2060 FAX: (086) 674 6121 EMAIL: mail@zitholele.co.za	 WSP Group Africa (Pty) Ltd Industrial Division Building C, Kingsbridge, 32 Slocane Street, Bryanston, 2191 Tel: +27 11 361 1300 Fax: +27 11 361 1431 www.wsp.com	DESIGNED		 17 HARRISON STREET MARSHALLTOWN 2107 TEL: (011) 688-1400 FAX: (011) 688-1529	BUSHKOPPIE WASTEWATER TREATMENT WORKS INFRASTRUCTURE RENEWAL PLAN EXISTING WASH WATER PUMP STATION PROCESS AND INSTRUMENTATION DIAGRAM			NTS			TO	FOR TENDER	MB	16.08.21	JW NUMBER					
			T1	RE-ISSUED FOR TENDER								C&T	07.01.25	CONSULTANT'S NUMBER							
														CI-PID08							
														FILE No							
			APPROVED						DATE							TO	T1				

FIELD

TYPICAL DOL DRIVE

R-L2-2	1	R-L2-2 c1	
ISOLATED HEALTHY	IO.2.0	2	IO.2.0 c2
LOCKED OUT HEALTHY	IO.2.1	3	IO.2.1 c3
PLC SELECTED	IO.2.2	4	IO.2.2 c4
RUNNING	IO.2.3	5	IO.2.3 c5
TRIP HEALTHY	IO.2.4	6	IO.2.4 c6

TYPICAL FWD/REV DRIVE

R-L2-3	1	R-L2-3 c7	
RUNNING FORWARD	IO.2.5	2	IO.2.5 c8
RUNNING REVERSE	IO.2.6	3	IO.2.6 c9
TRIP HEALTHY	IO.2.7	4	IO.2.7 c10
LOCKED OUT HEALTHY	IO.2.8	5	IO.2.8 c11
ISOLATED HEALTHY	IO.2.9	6	IO.2.9 c12
PLC SELECTED	IO.2.10	7	IO.2.10 c13
TORQUE HEALTHY	IO.2.11	8	IO.2.11 c14

CABLE No.

IDM01-TYP-MCC 1.5mm² 37c
PVC PVC SWA PVC

PLC MARSHALLING

230V AC SUPPLY

R-L1

R-N1

Q2.A
C-CURVE I-2A

R-L2

R-L2-1

R-L2-2 c1

R-L2-3 c7

R-N2-1

R-N2

200

100

201

101

202

102

203

103

204

104

205

105

206

106

207

107

208

108

209

109

210

110

211

111

212

112

213

113

214

114

215

115

ABE-7S16E2M0

+24V

R-P2

R-C2

Q3.0
C-CURVE I-2A DC

R-P3-1

R-C3-1

10

wh

11

brn

12

grn

13

yl

14

grey

15

prnk

16

blu

17

rd

18

blk

19

violet

20

grey prnk

21

rd blu

22

wh grn

23

brn grn

24

wh yl

25

yl brn

wh grey

grey brn

wh prnk

prnk brn

CONNECTING CABLE
BMX FCC 303

BMX DDI 6402K
DIGITAL INPUT
RACK 0/SLOT 2A

TO
DIGITAL INPUT
RACK 0/SLOT 2B

DIGITAL INPUT

TO DIGITAL OUTPUT
RACK 0/SLOT 3A

NOTES:

1. EARTH CORE MUST BE YELLOW/GREEN OR IT MUST BE FITTED WITH A YELLOW/GREEN SLEEVE.

2. SUB-BASE 1: ABE-7S16E2M0: 230V AC DIGITAL INPUT

3. SUB-BASE 2: ABE-7CPA02: 8ch ANALOG INPUT

4. SUB-BASE 3: ABE-7R16S210: RELAY OUTPUT

5. SUB-BASE 4: ABE-7CPA21: 4ch ANALOG OUTPUT

6. SPD 1: DEHNguard DG M TN 275

7. SPD 2: DEHNguard DG S 275 VA

8. SPD 3: BLITZDUCTOR BXT ML4 BD 24 + BASE BXT BAS

9. SPD 4: BLITZDUCTOR BXT ML2 BD S 24 + BASE BXT BAS

10. SPD 5: BLITZDUCTOR BXT ML4 BE 24 + BASE BXT BAS

11. SPD 6: BLITZDUCTOR BXT ML2 BE S 24 + BASE BXT BAS


* FUSED TERMINAL (500mA)



LINK TERMINAL


DEPARTMENT	APPROVED	DESIGNATION	DATE

CONSULTING ENGINEERS		SURVEYED		JOHANNESBURG WATER SOC LTD		CITY OF JOHANNESBURG		DESIGN MANAGER	SCALE	AMENDMENTS		APPROVED	DATE	DRAWING No.	
 P.O. BOX 221 RIVONIA 2128 TEL. 011-806 7111 FAX. 011-806 7100 EMAIL enquiries@kprsa.co.za	 WSP Group Africa (Pty) Ltd Industrial Division Building C, Knightsbridge, 33 Sloane Street, Bryanston, 2191 Tel: +27 11 361 1300 Fax: +27 11 361 1431 www.wsp.com	DESIGNED	W BRITZ	 Johannesburg Water	17 HARRISON STREET MARSHALLTOWN 2107 TEL: (011) 688-1400 FAX: (011) 688-1529	BUSHKOPPIE WASTEWATER TREATMENT WORKS INFRASTRUCTURE RENEWAL PLAN HEAD OF WORKS PLC-TYP DIGITAL INPUT MODULE: SUB-BASE 1 OF 4 RACK 0 / SLOT 2A		DATE	NTS	T0 ISSUED FOR TENDER		W BRITZ	08.08.19	JW NUMBER	
		T1 RE-ISSUED FOR TENDER								CdT	07.01.25	CONSULTANT'S NUMBER			
												TYP-ROS2A-DI			
												FILE No			
												TO T1			

  Z:\461000xx\46100563 - Bushkoppie WWTW HOW\51 C\02-CADD\01-Current\03-Drawings\Typical Wiring\NG06450-TYP-ROS2A-DI rev11.dwg Jan 09, 2025 - 12:53pm

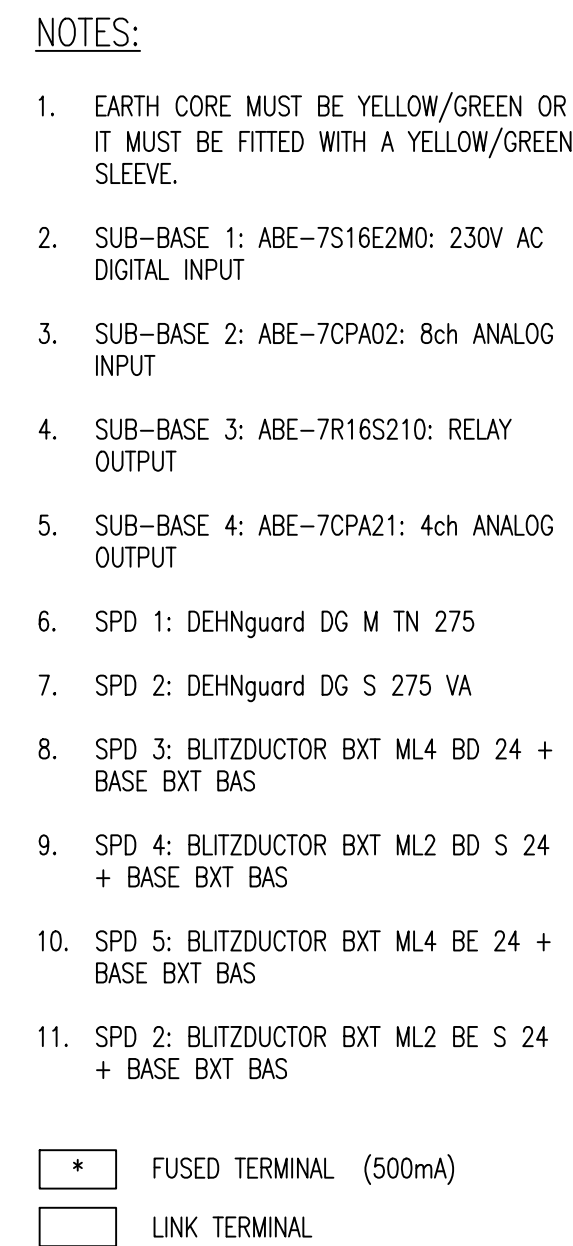

CONSULTING ENGINEERS			SURVEYED		JOHANNESBURG WATER SOC LTD		CITY OF JOHANNESBURG		DESIGN MANAGER	SCALE	AMENDMENTS	APPROVED	DATE	DRAWING No.													
 Knight Piésold CONSULTING P.O. BOX 221 RIVONIA 2128 TEL: 011-806 7111 FAX: 011-806 7100 EMAIL: enquiries@kprsa.co.za	 WSP WSP Group Africa (Pty) Ltd Industrial Division Building C, Knightsbridge, 33 Sloane Street, Bryanston, 2191 Tel: +27 11 361 1300 Fax: +27 11 361 1431 www.wsp.com	DESIGNED	W BRITZ	 Johannesburg Water	17 HARRISON STREET MARSHALLTOWN 2107 TEL: (011) 688-1400 FAX: (011) 688-1529	BUSHKOPPIE WASTEWATER TREATMENT WORKS INFRASTRUCTURE RENEWAL PLAN HEAD OF WORKS PLC-TYP DIGITAL INPUT MODULE: SUB-BASE 2 OF 4 RACK 0 / SLOT 2B		DATE						NTS	T0	ISSUED FOR TENDER	W BRITZ	08.08.19	JW NUMBER								
		T1	RE-ISSUED FOR TENDER						CdT	07.01.25	CONSULTANT'S NUMBER																
												TYP-R0S2B-DI															
												FILE No															
												T0 T1															

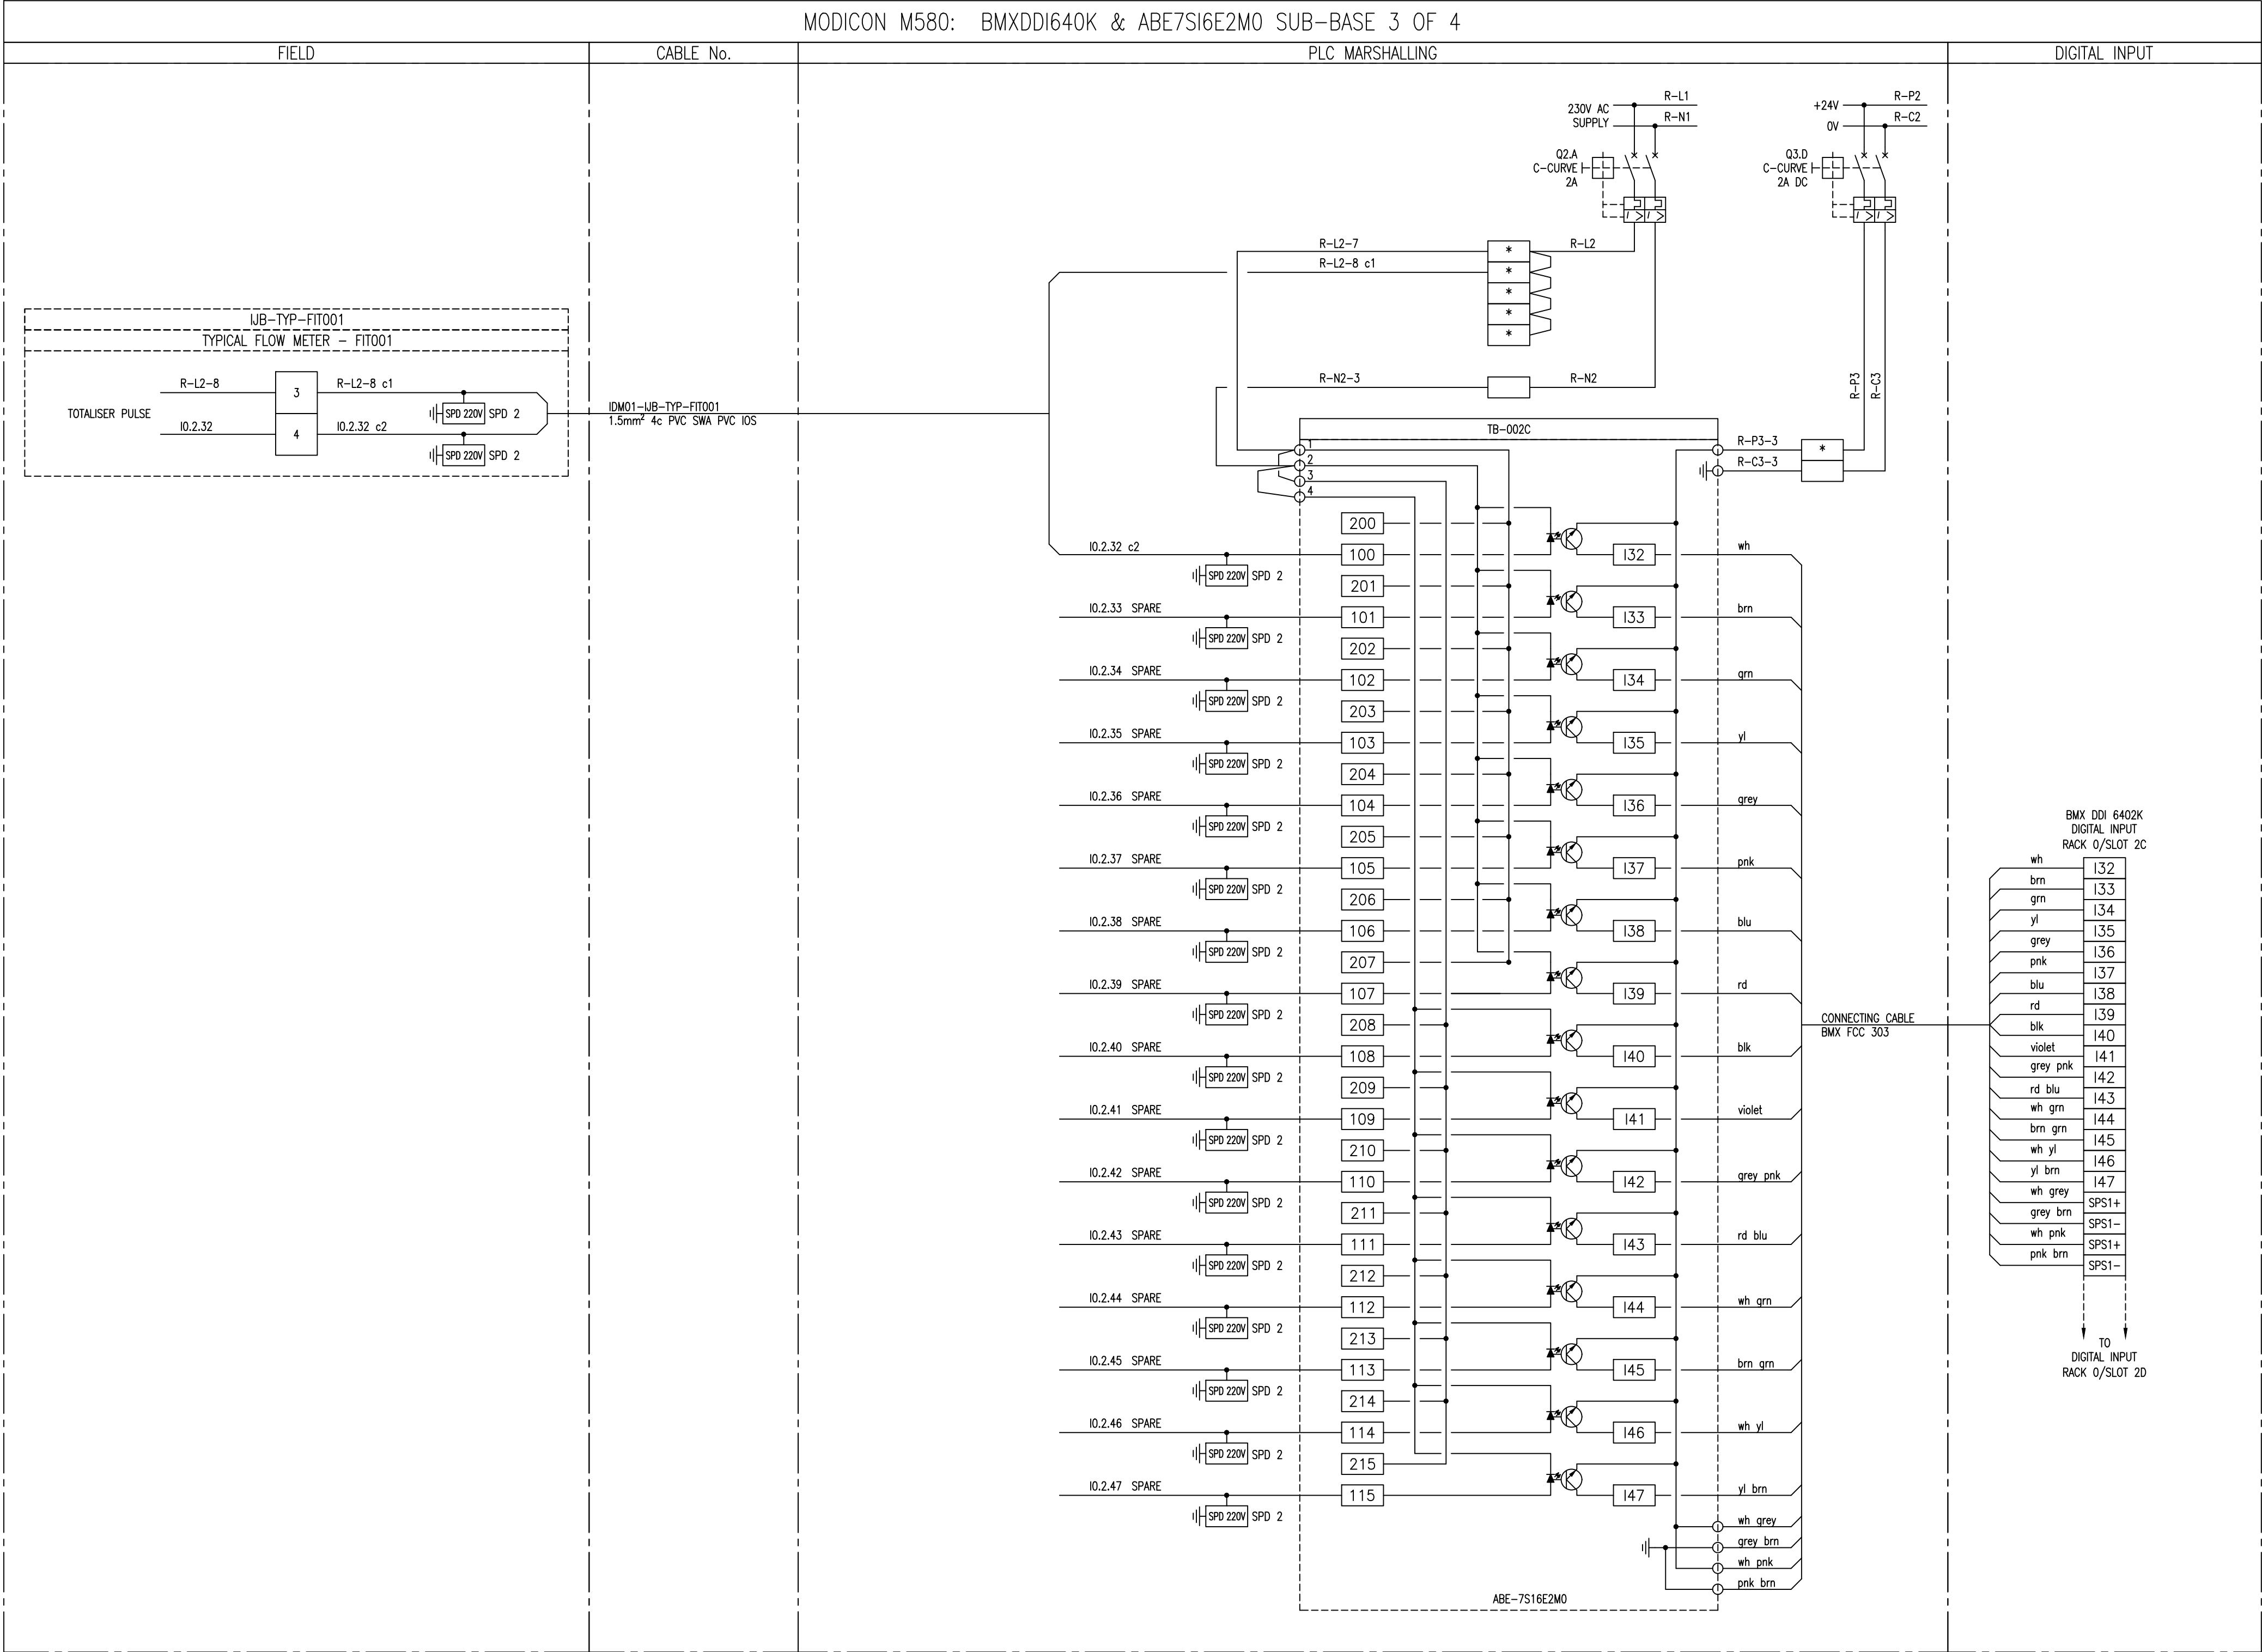


NOTES:

- EARTH CORE MUST BE YELLOW/GREEN OR IT MUST BE FITTED WITH A YELLOW/GREEN SLEEVE.
- SUB-BASE 1: ABE-7S16E2M0: 230V AC DIGITAL INPUT
- SUB-BASE 2: ABE-7CPA02: 8ch ANALOG INPUT
- SUB-BASE 3: ABE-7R16S210: RELAY OUTPUT
- SUB-BASE 4: ABE-7CPA21: 4ch ANALOG OUTPUT
- SPD 1: DEHNguard DG M TN 275
- SPD 2: DEHNguard DG S 275 VA
- SPD 3: BLITZDUCTOR BXT ML4 BD 24 + BASE BXT BAS
- SPD 4: BLITZDUCTOR BXT ML2 BD S 24 + BASE BXT BAS
- SPD 5: BLITZDUCTOR BXT ML4 BE 24 + BASE BXT BAS
- SPD 2: BLITZDUCTOR BXT ML2 BE S 24 + BASE BXT BAS

- * FUSED TERMINAL (500mA)
- LINK TERMINAL

DEPARTMENT	APPROVED	DESIGNATION	DATE

CONSULTING ENGINEERS		SURVEYED		JOHANNESBURG WATER SOC LTD		CITY OF JOHANNESBURG		DESIGN MANAGER	SCALE	AMENDMENTS	APPROVED	DATE	DRAWING No.									
 P.O. BOX 221 RIVONIA 2128 TEL: 011-806 7111 FAX: 011-806 7100 EMAIL: enquiries@kprsa.co.za	 WSP Group Africa (Pty) Ltd Industrial Division Building C, Knightsbridge, 33 Sloane Street, Bryanston, 2191 Tel: +27 11 361 1300 Fax: +27 11 361 1431 www.wsp.com	DESIGNED	W BRITZ	 Johannesburg Water	17 HARRISON STREET MARSHALLTOWN 2107 TEL: (011) 688-1400 FAX: (011) 688-1529	BUSHKOPPIE WASTEWATER TREATMENT WORKS INFRASTRUCTURE RENEWAL PLAN HEAD OF WORKS PLC-TYP DIGITAL INPUT MODULE: SUB-BASE 3 OF 4 RACK 0 / SLOT 2C	DATE						NTS	T0	ISSUED FOR TENDER	W BRITZ	08.08.19	JW NUMBER				
		DRAWN	M DYKE					T1	RE-ISSUED FOR TENDER	CdT	07.01.25	CONSULTANT'S NUMBER										
		CHECKED	W BRITZ					TYP-ROS2C-DI														
		SERVICES CHECKED						FILE No														
		GEOTECHNICAL INVESTIGATION						TO T1														
		SERVITUDES																				
		APPROVED																				
		Pr. Eng. No.																				
		DATE																				

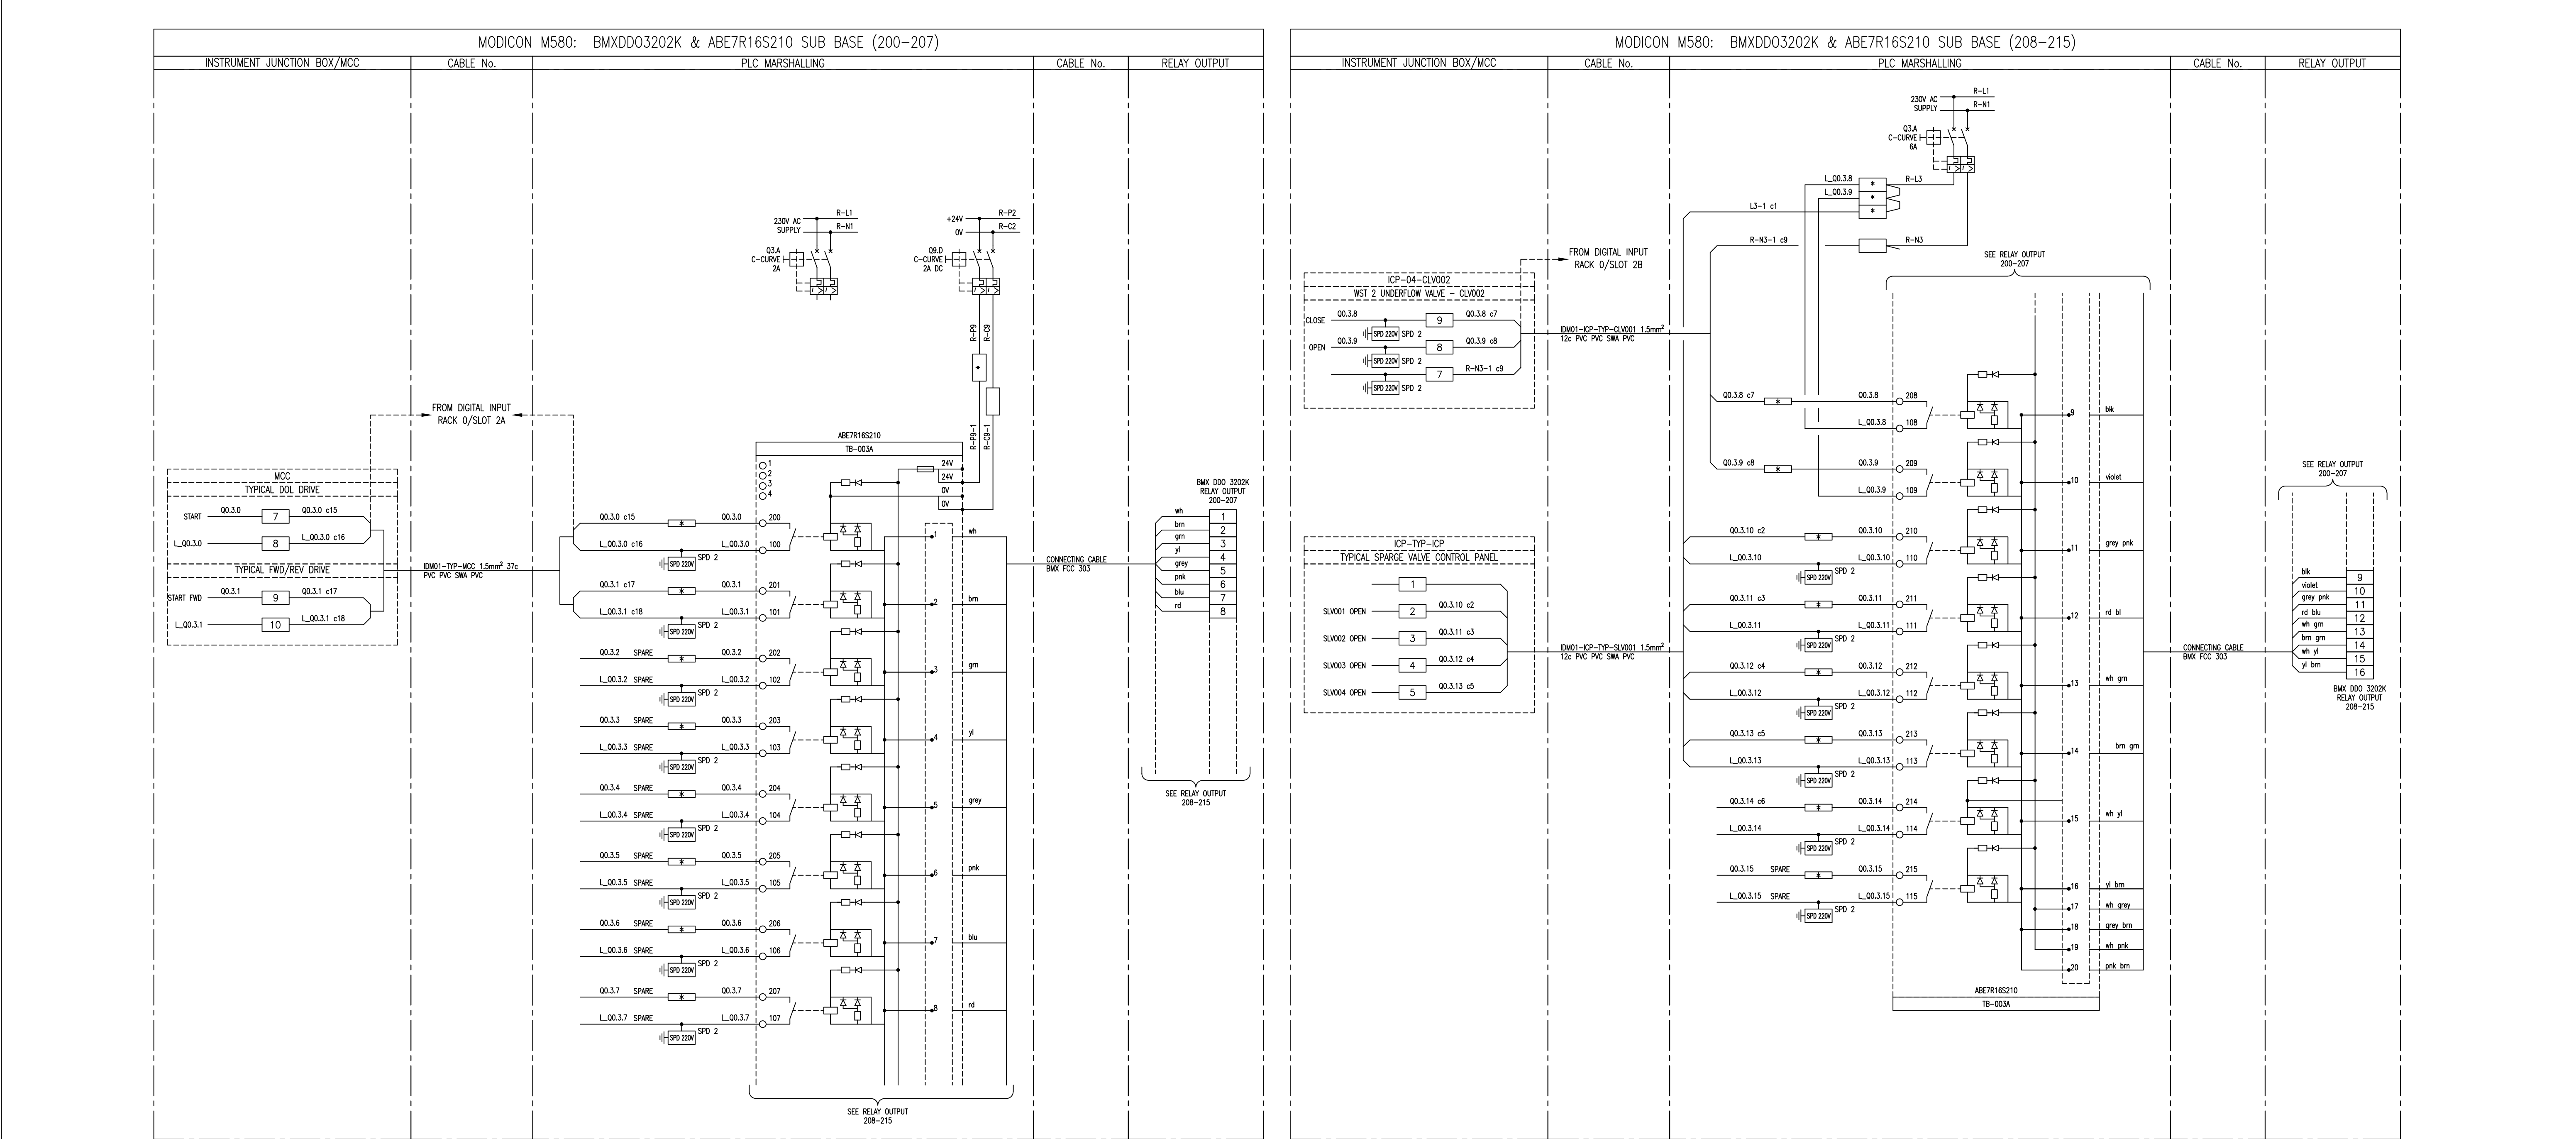

DEPARTMENT	APPROVED	DESIGNATION	DATE

NOTES:

1. EARTH CORE MUST BE YELLOW/GREEN OR IT MUST BE FITTED WITH A YELLOW/GREEN SLEEVE.

2. SUB-BASE 1: ABE-7S16E2M0: 230V AC DIGITAL OUTPUT

3. SUB-BASE 2: ABE-7CPA02: 8ch ANALOG OUTPUT

4. SUB-BASE 3: ABE-7R16S210: RELAY OUTPUT

5. SUB-BASE 4: ABE-7CPA21: 4ch ANALOG OUTPUT

6. SPD 1: DEHNguard DG M TN 275

7. SPD 2: DEHNguard DG S 275 VA

8. SPD 3: BLITZDUCTOR BXT ML4 BD 24 + BASE BXT BAS

9. SPD 4: BLITZDUCTOR BXT ML2 BD S 24 + BASE BXT BAS

10. SPD 5: BLITZDUCTOR BXT ML4 BE 24 + BASE BXT BAS

11. SPD 6: BLITZDUCTOR BXT ML2 BE S 24 + BASE BXT BAS

* FUSED TERMINAL (500mA)

□ LINK TERMINAL

CONSULTING ENGINEERS			JOHANNESBURG WATER SOC LTD		CITY OF JOHANNESBURG		DESIGN MANAGER	SCALE	AMENDMENTS	APPROVED	DATE	DRAWING No.								
Knight Piésold CONSULTING P.O. BOX 221 RIVONIA 2128 TEL: 011-806 7111 FAX: 011-806 7100 EMAIL: enquiries@kprsa.co.za WSP WSP Group Africa (Pty) Ltd Industrial Division Building C, Knightsbridge, 33 Sloane Street, Bryanston, 2191 Tel: +27 11 361 1300 Fax: +27 11 361 1431 www.wsp.com		SURVEYED		Johannesburg Water	17 HARRISON STREET MARSHALLTOWN 2107	BUSHKOPPIE WASTEWATER TREATMENT WORKS INFRASTRUCTURE RENEWAL PLAN HEAD OF WORKS PLC-TYP DIGITAL OUTPUT MODULE: SUB-BASE 1 OF 2 RACK 0 / SLOT 3A (200-215)						DATE	NTS	T0	ISSUED FOR TENDER	W BRITZ	08.08.19	JW NUMBER		
		T1	RE-ISSUED FOR TENDER		CdT			07.01.25	CONSULTANT'S NUMBER											
		TYP-ROS3A-DO																		
		FILE No																		
		T0	T1																	
		APPROVED	Pr. Eng. No.		TEL: (011) 688-1400															
		DATE			FAX: (011) 688-1529															

